


DRAWING SET for the CULTURAL LANDSCAPE REPORT

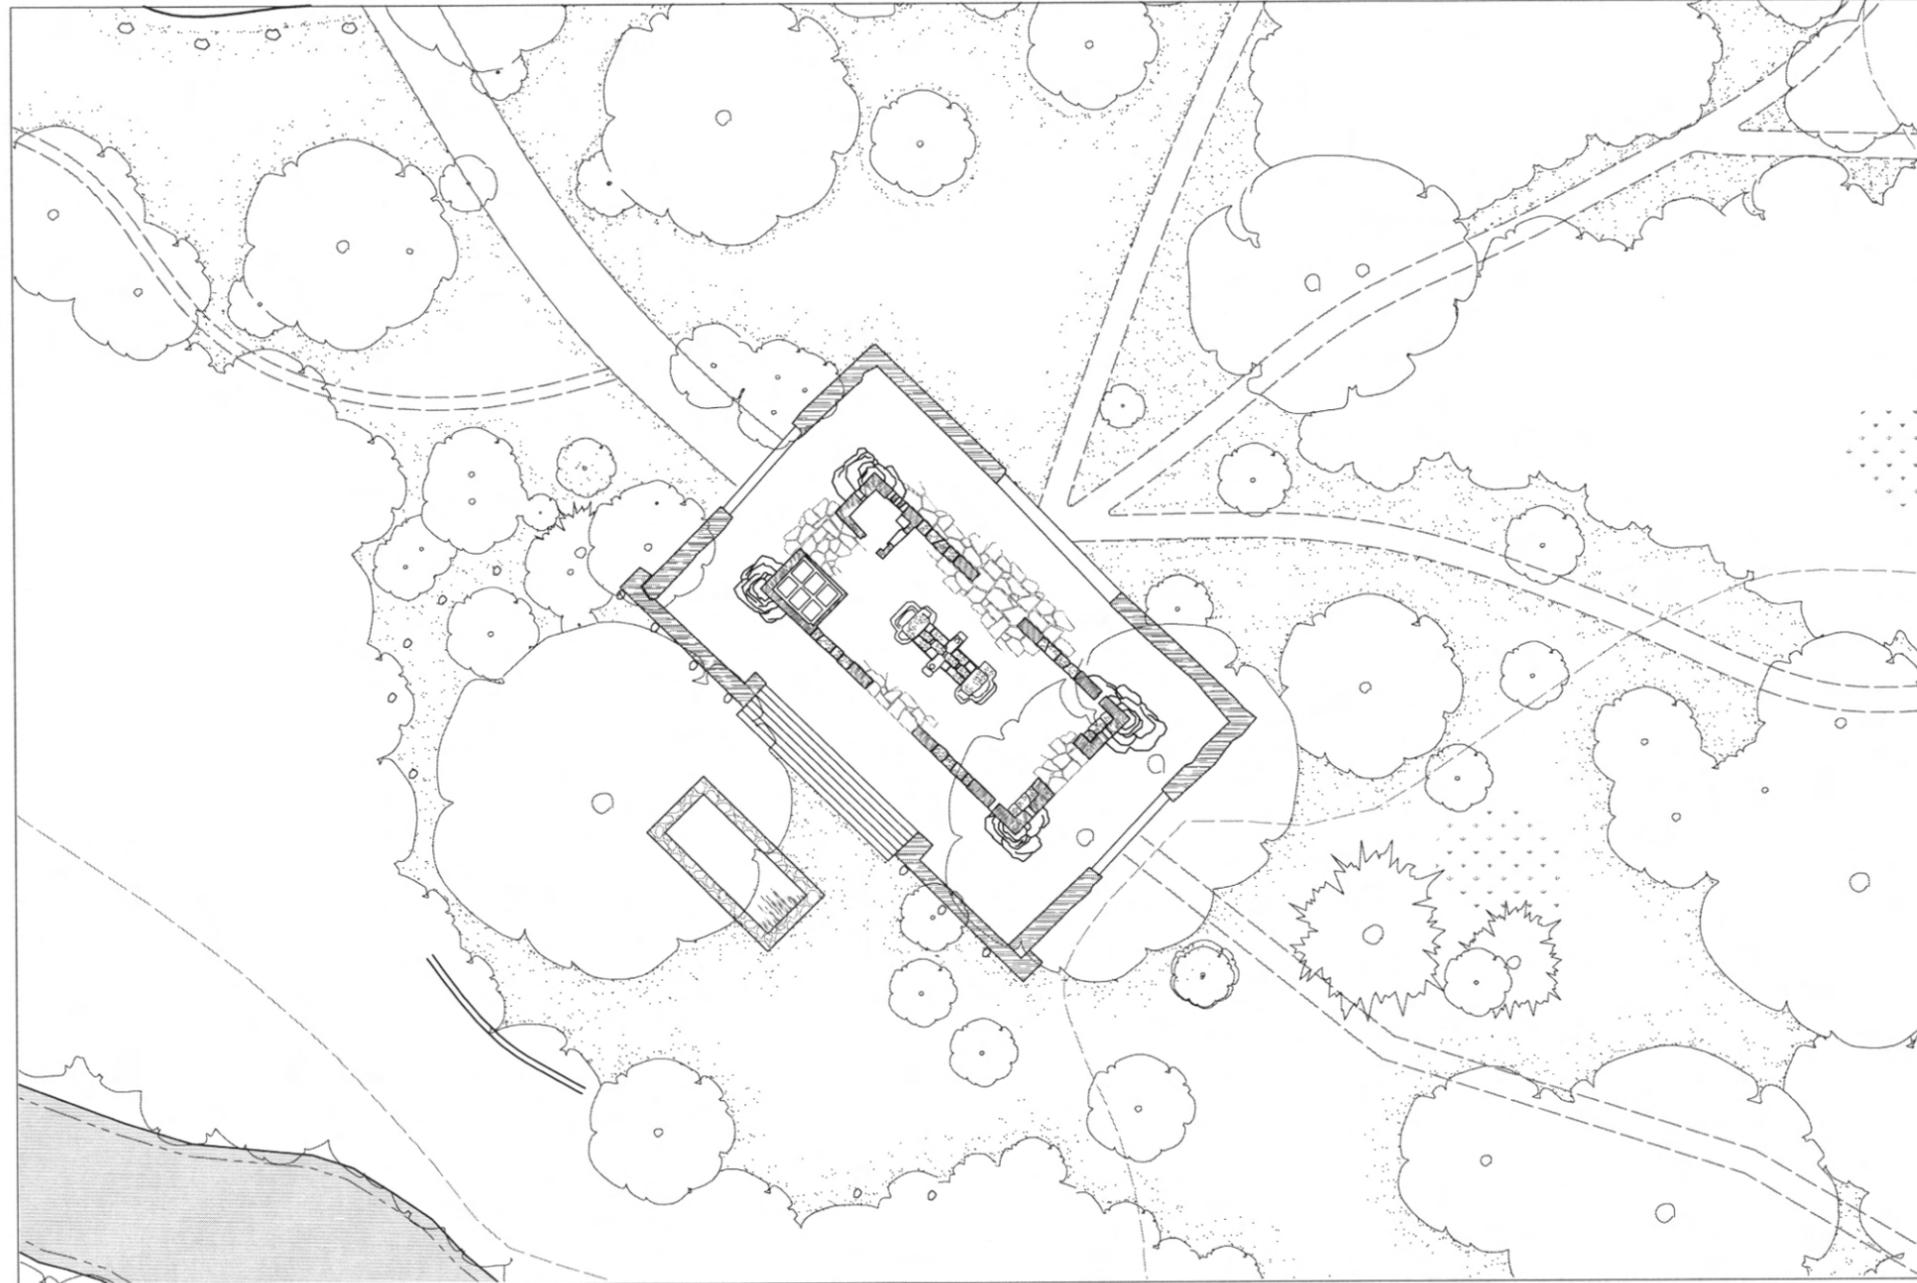

PLATT DISTRICT

Chickasaw National Recreation Area

Cultural Landscape Report

Iowa State University, Landscape Architecture Department

10/7/2002

PLATT DISTRICT

Cultural Landscape Report

Drawing List

Figure 3-3. Map of Platt National Park. United States Department of the Interior, 1909

Drawing 1. 1933 PERIOD PLAN Platt National Park

Drawing 2. 1940 PERIOD PLAN Platt National Park

Drawing 3. 1940 PERIOD PLAN Bromide Springs and Bromide Hall

Drawing 4. 1940 PERIOD PLAN Walnut Grove

Drawing 5. 1940 PERIOD PLAN Flower Park

Drawing 6. 1940 PERIOD PLAN Buffalo Pasture & Prairie Uplands

Drawing 7. 1940 PERIOD PLAN Pavilion Springs/Hillside Springs/Headquarters and Maintenance Area

Drawing 8. 1940 PERIOD PLAN Central Campground

Drawing 9. 1940 PERIOD PLAN Cold Springs Campground

Drawing 10. 1940 PERIOD PLAN Little Niagara & Travertine Island

Drawing 11. 1940 PERIOD PLAN Antelope Springs & Buffalo Springs

Drawing 12. 1950 PERIOD PLAN Rock Creek

Drawing 13. 1969 PERIOD PLAN Platt National Park

Drawing 14. EXISTING CONDITIONS Platt District 2002

Drawing 15. EXISTING CONDITIONS 2002 Bromide Springs and Bromide Hall

Drawing 16. EXISTING CONDITIONS 2002 Walnut Grove

Drawing 17. EXISTING CONDITIONS 2002 Flower Park

Drawing 18. EXISTING CONDITIONS 2002 Buffalo Pasture & Prairie Uplands

Drawing 19. EXISTING CONDITIONS 2002 Pavilion Springs/Hillside Springs/Headquarters and Maintenance Area

Drawing 20. EXISTING CONDITIONS 2002 Central Campground

Drawing 21. EXISTING CONDITIONS 2002 Cold Springs Campground

Drawing 22. EXISTING CONDITIONS 2002 Little Niagara & Travertine Island

Drawing 23. EXISTING CONDITIONS 2002 Antelope Springs & Buffalo Springs

Drawing 24. EXISTING CONDITIONS 2002 Rock Creek

Drawing 25. TREATMENT PROJECTS Bromide Springs and Bromide Hall

Drawing 26. TREATMENT PROJECTS Walnut Grove

Drawing 27. TREATMENT PROJECTS Flower Park

Drawing 28. TREATMENT PROJECTS Buffalo Pasture & Prairie Uplands

Drawing 29. TREATMENT PROJECTS Pavilion Springs/Hillside Springs/Headquarters and Maintenance Area

Drawing 30. TREATMENT PROJECTS Central Campground

Drawing 31. TREATMENT PROJECTS Cold Springs Campground






















Drawing 32. TREATMENT PROJECTS Little Niagara & Travertine Island


Drawing 33. TREATMENT PROJECTS Antelope Springs & Buffalo Springs

Drawing 34. TREATMENT PROJECTS Rock Creek


Drawing 35. Proposed Overall Vegetation Management Plan

                     
Legend:

 10' contour	 road	 stone boulders	 directional sign	 drainage swale	 trash enclosure	 fall/dam	 woodline
 creek	 parking areas	 guiderail	 interpretive sign	 manhole	 lantern hanger	 steps	 grass cover
 chain link fence	 underpass	 stone firepit	 park entry sign	 hydrant	 picnic table	 steps w/ stone edge	 flower bed
 stone wall	 bridge	 campsite firepit	 reunion post	 water source	 concrete picnic table	 stepping stones	 beach
 building	 curb	 standing grill	 electrical box	 telephone box	 campsite number	 information kiosk	 erosion
 '40 comfort station	 path/trail	 spring	 electrical pole	 gate	 bench	 deciduous tree	
 entry piers	 volunteer path	 pump house	 culvert	 trash can	 flagstones	 evergreen tree	

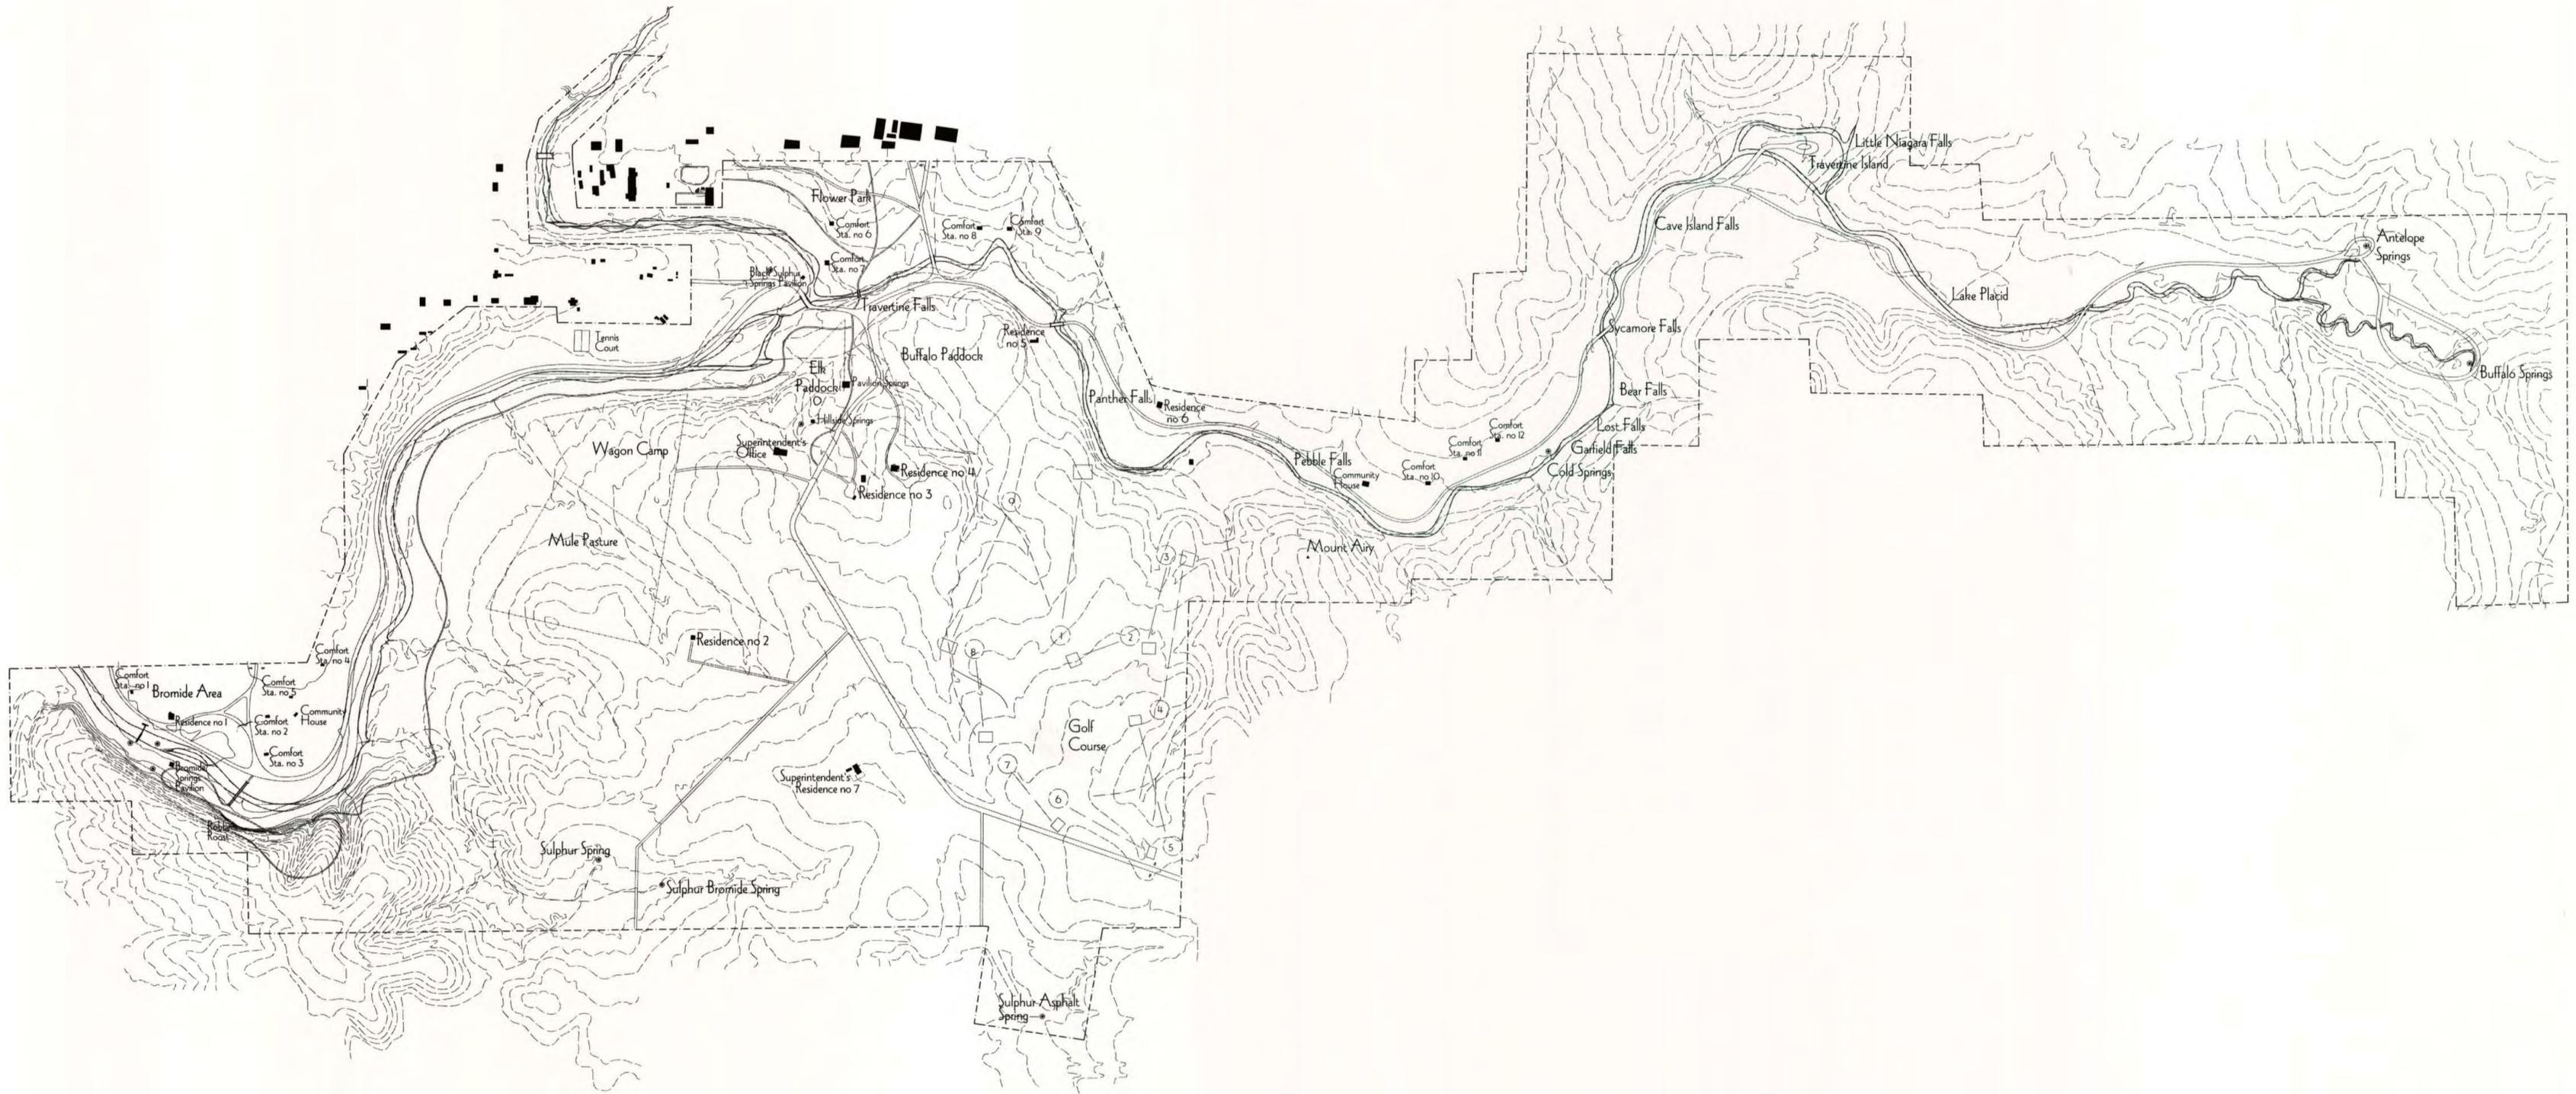

PLATT DISTRICT
 Chickasaw National Recreation Area
 Cultural Landscape Report
 Iowa State University, Landscape Architecture Department
 Date 10/7/02

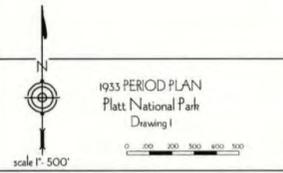


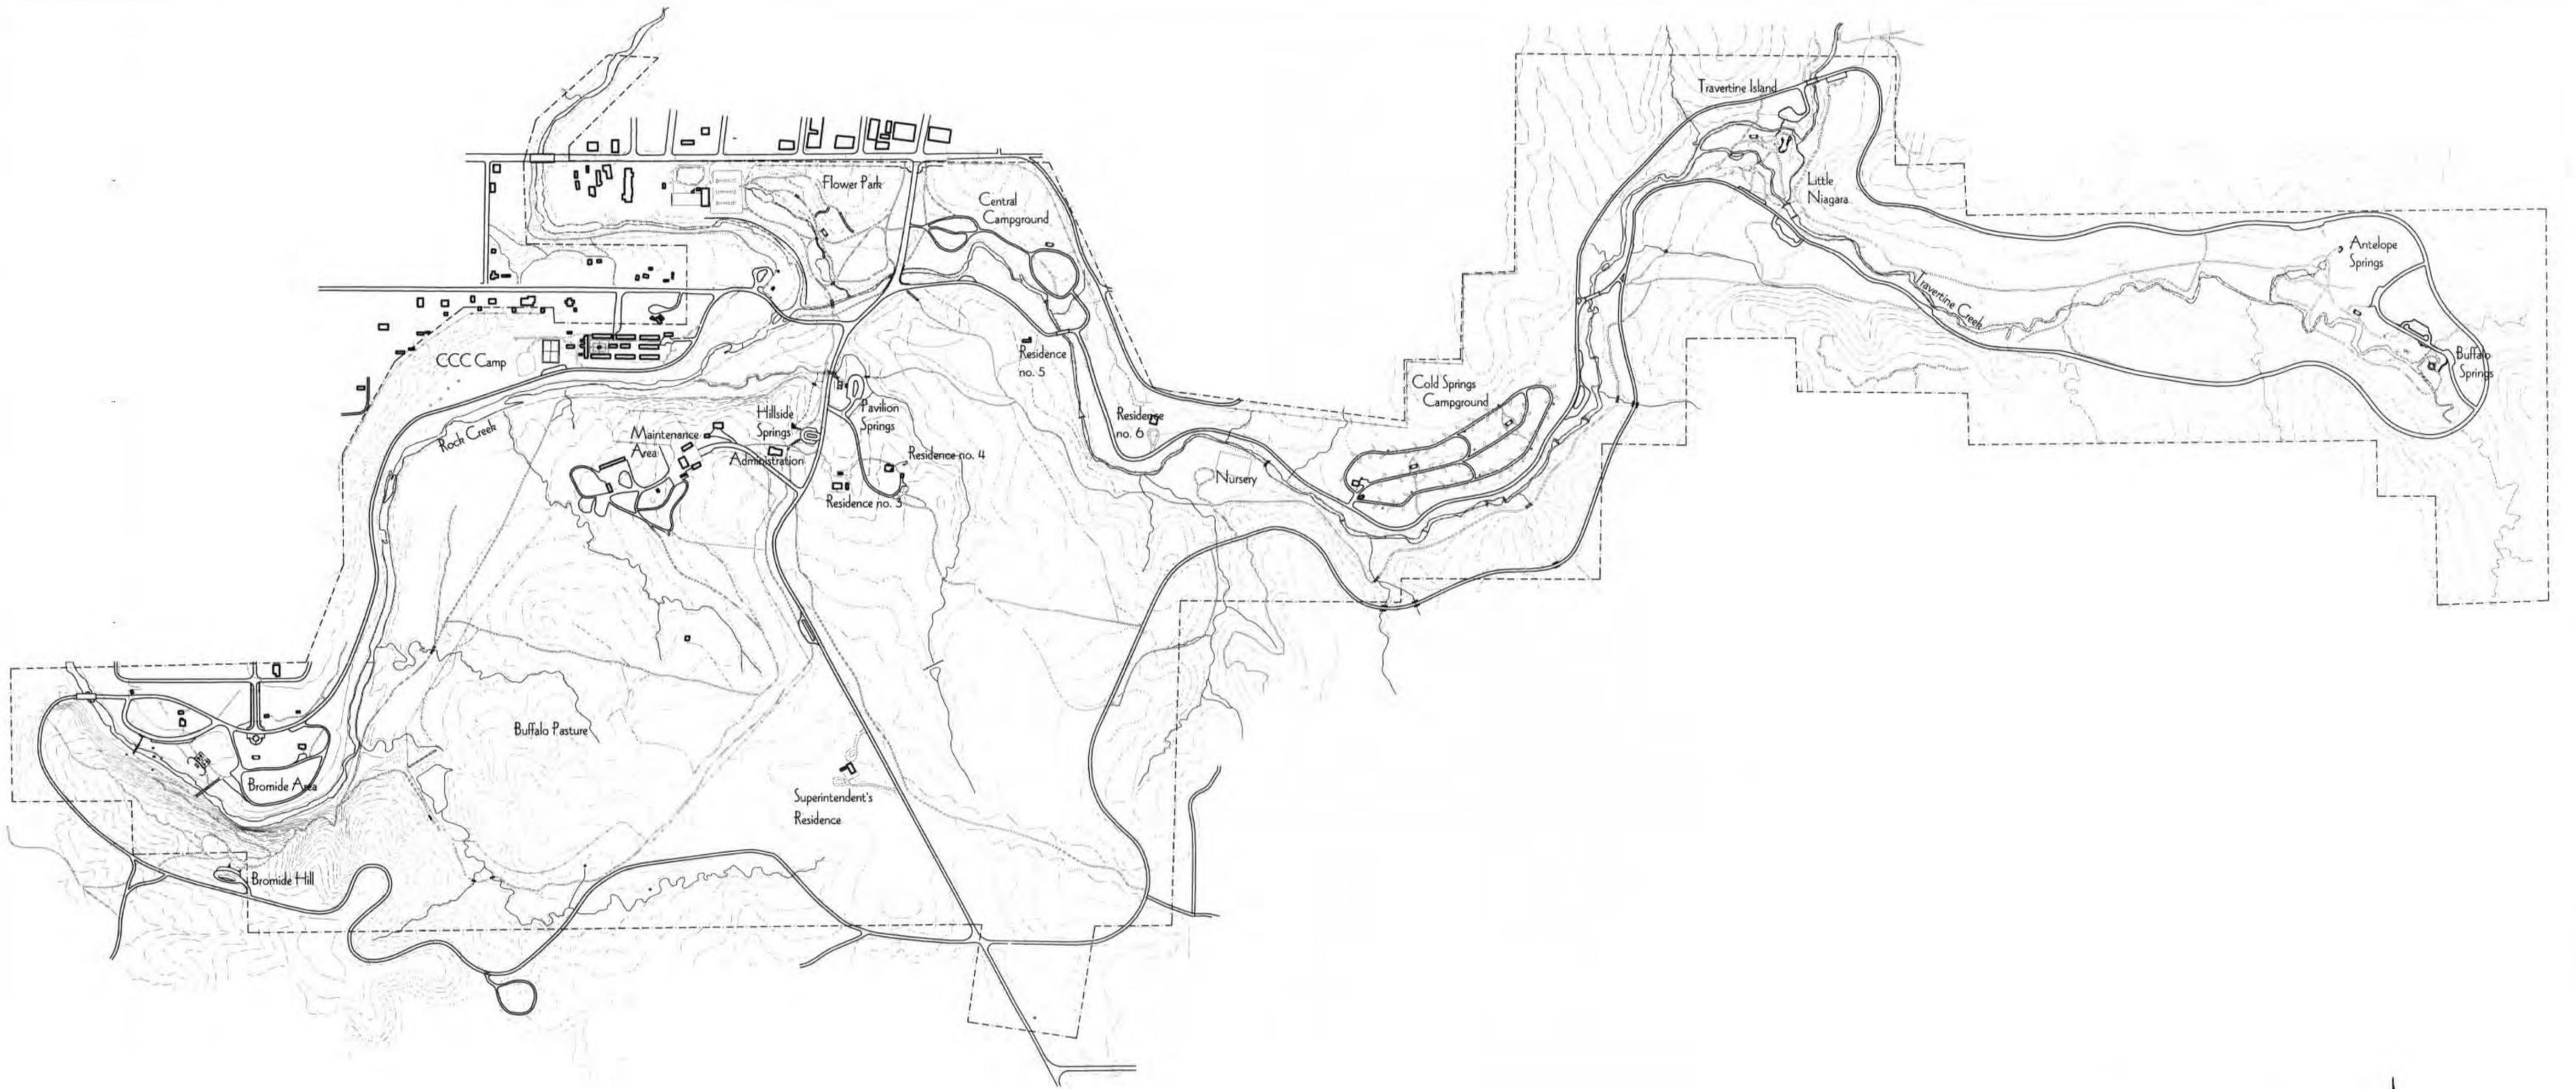

PLATT DISTRICT
 Chichasaw National Recreation Area
 Cultural Landscape Report
 Iowa State University, Landscape Architecture Department
 Date 10/7/02

1940 PERIOD PLAN
 Platt National Park
 Drawing 2


scale 1" = 500'

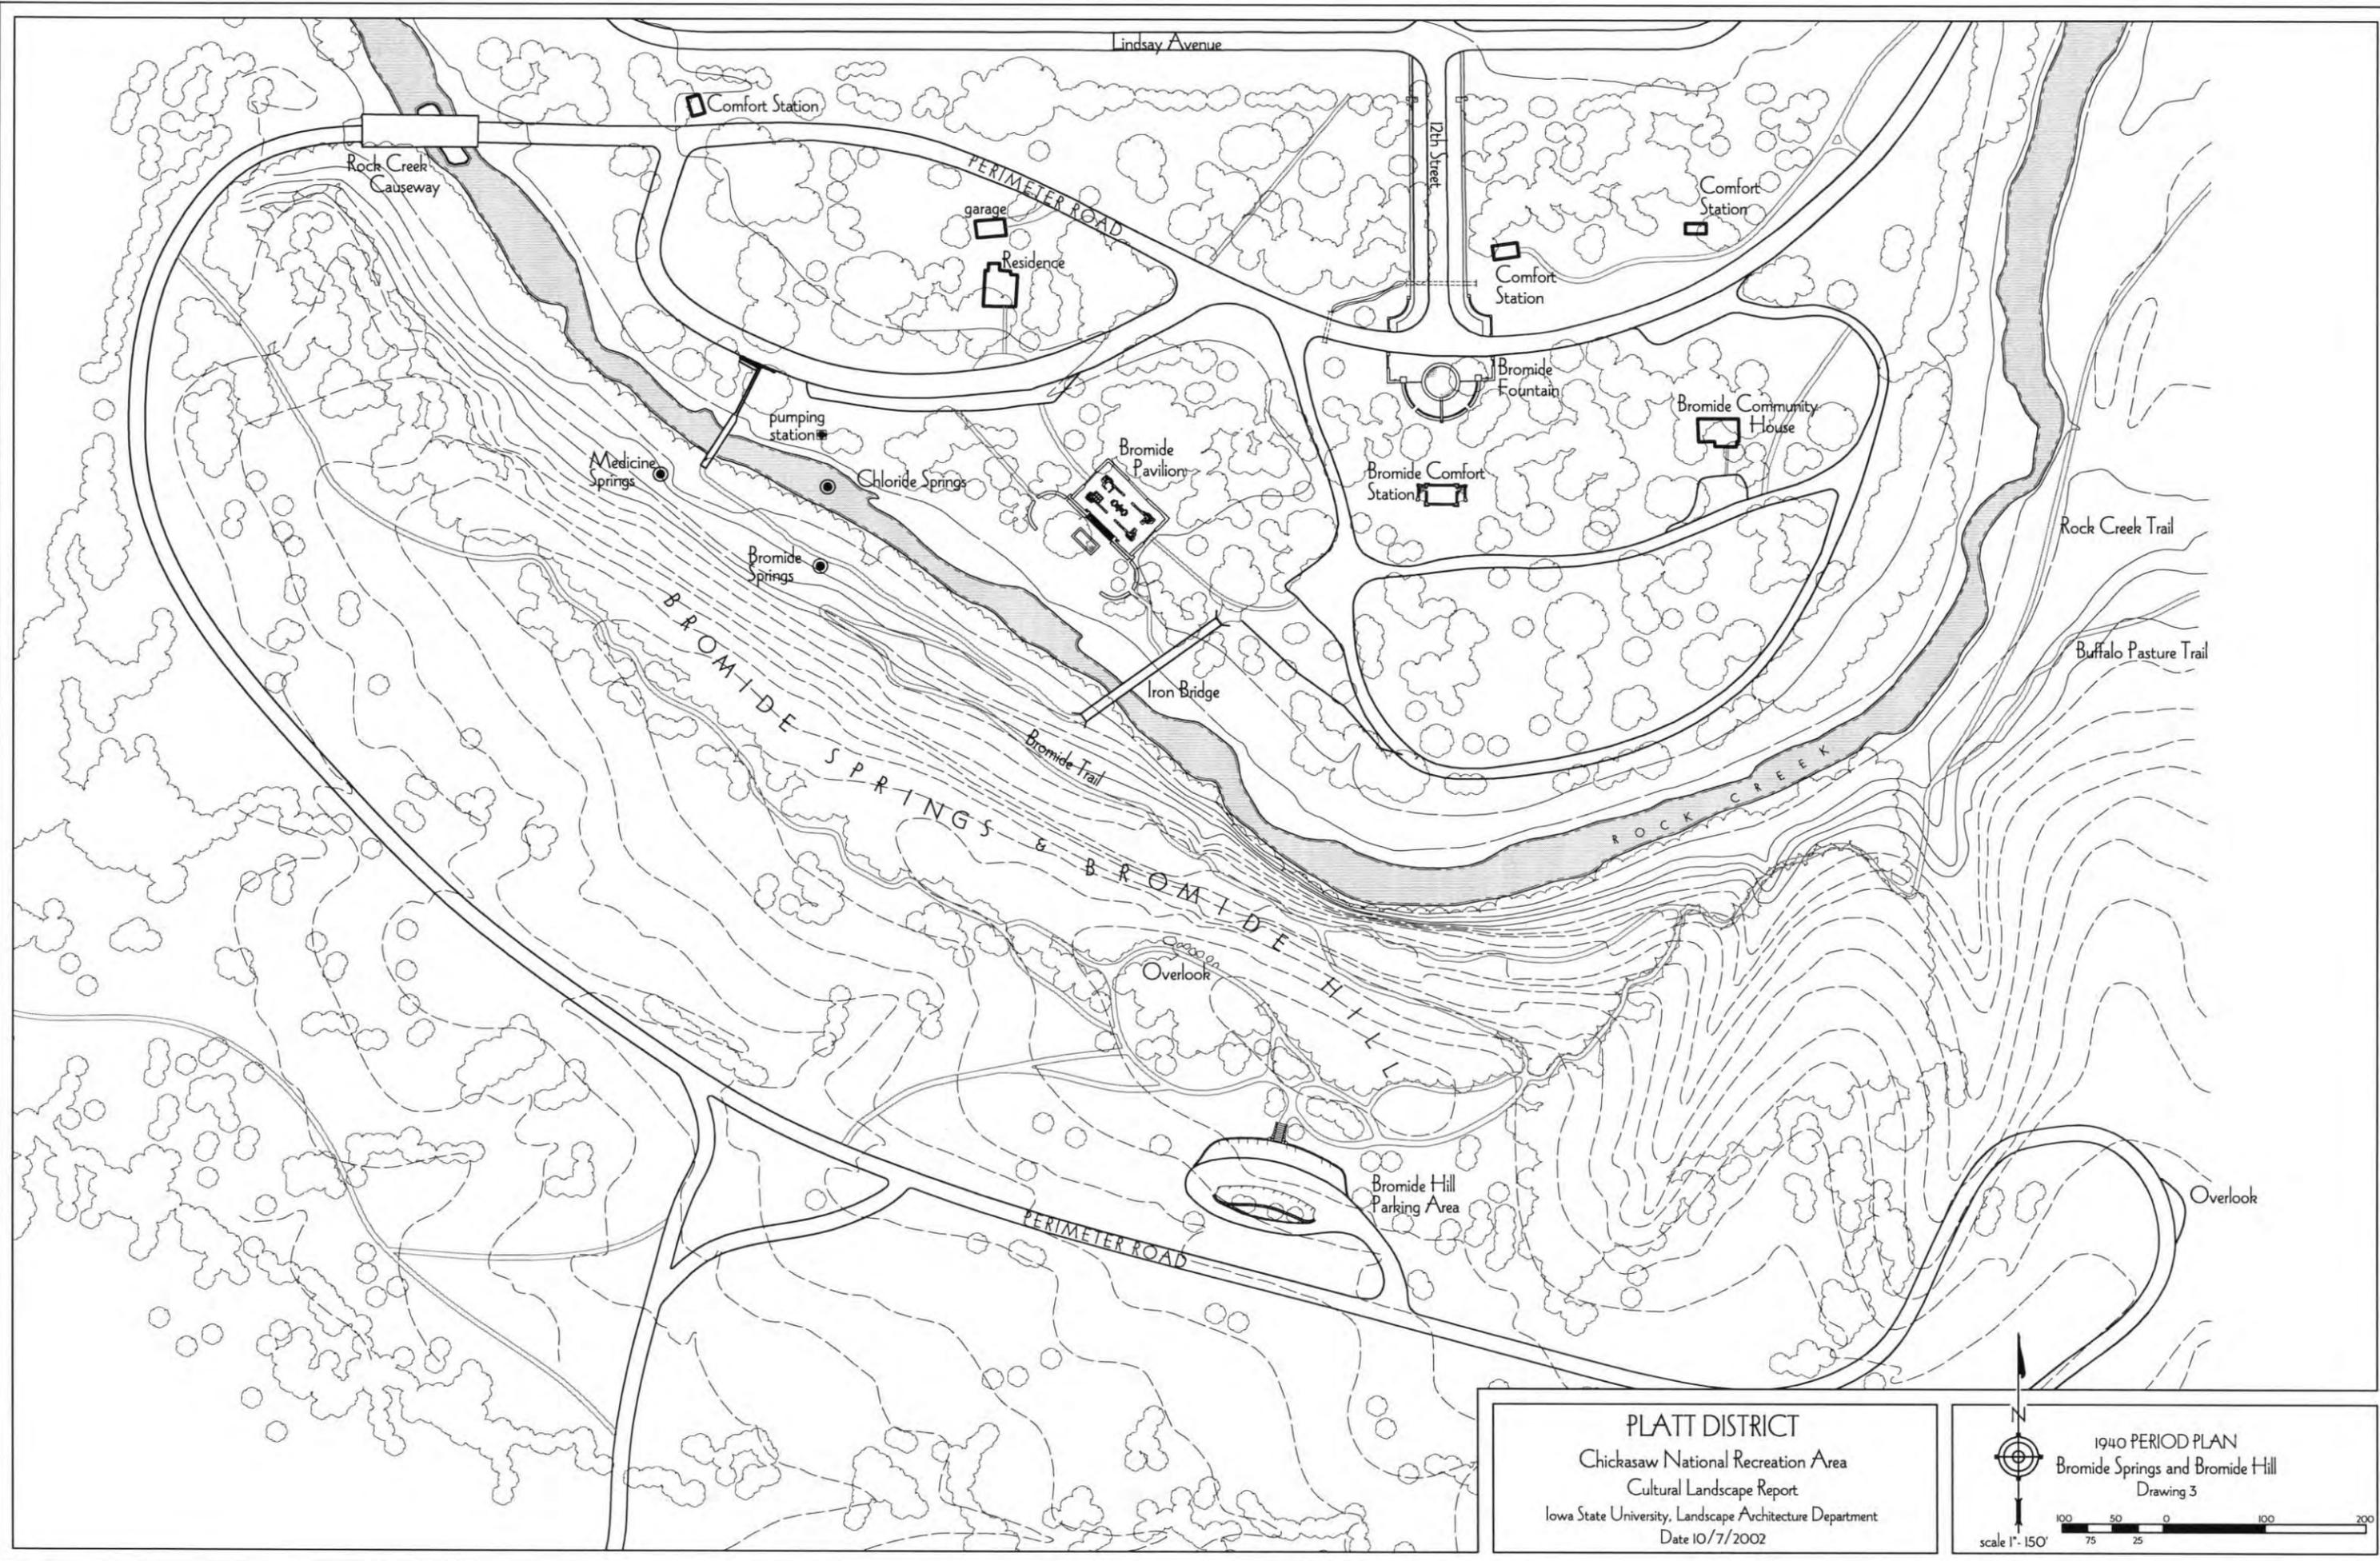

PLATT DISTRICT
 Chickasaw National Recreation Area
 Cultural Landscape Report
 Iowa State University, Landscape Architecture Department
 Date 10/7/2002

1940 PERIOD PLAN
 Bromide Springs and Bromide Hill
 Drawing 3

scale 1" = 150'

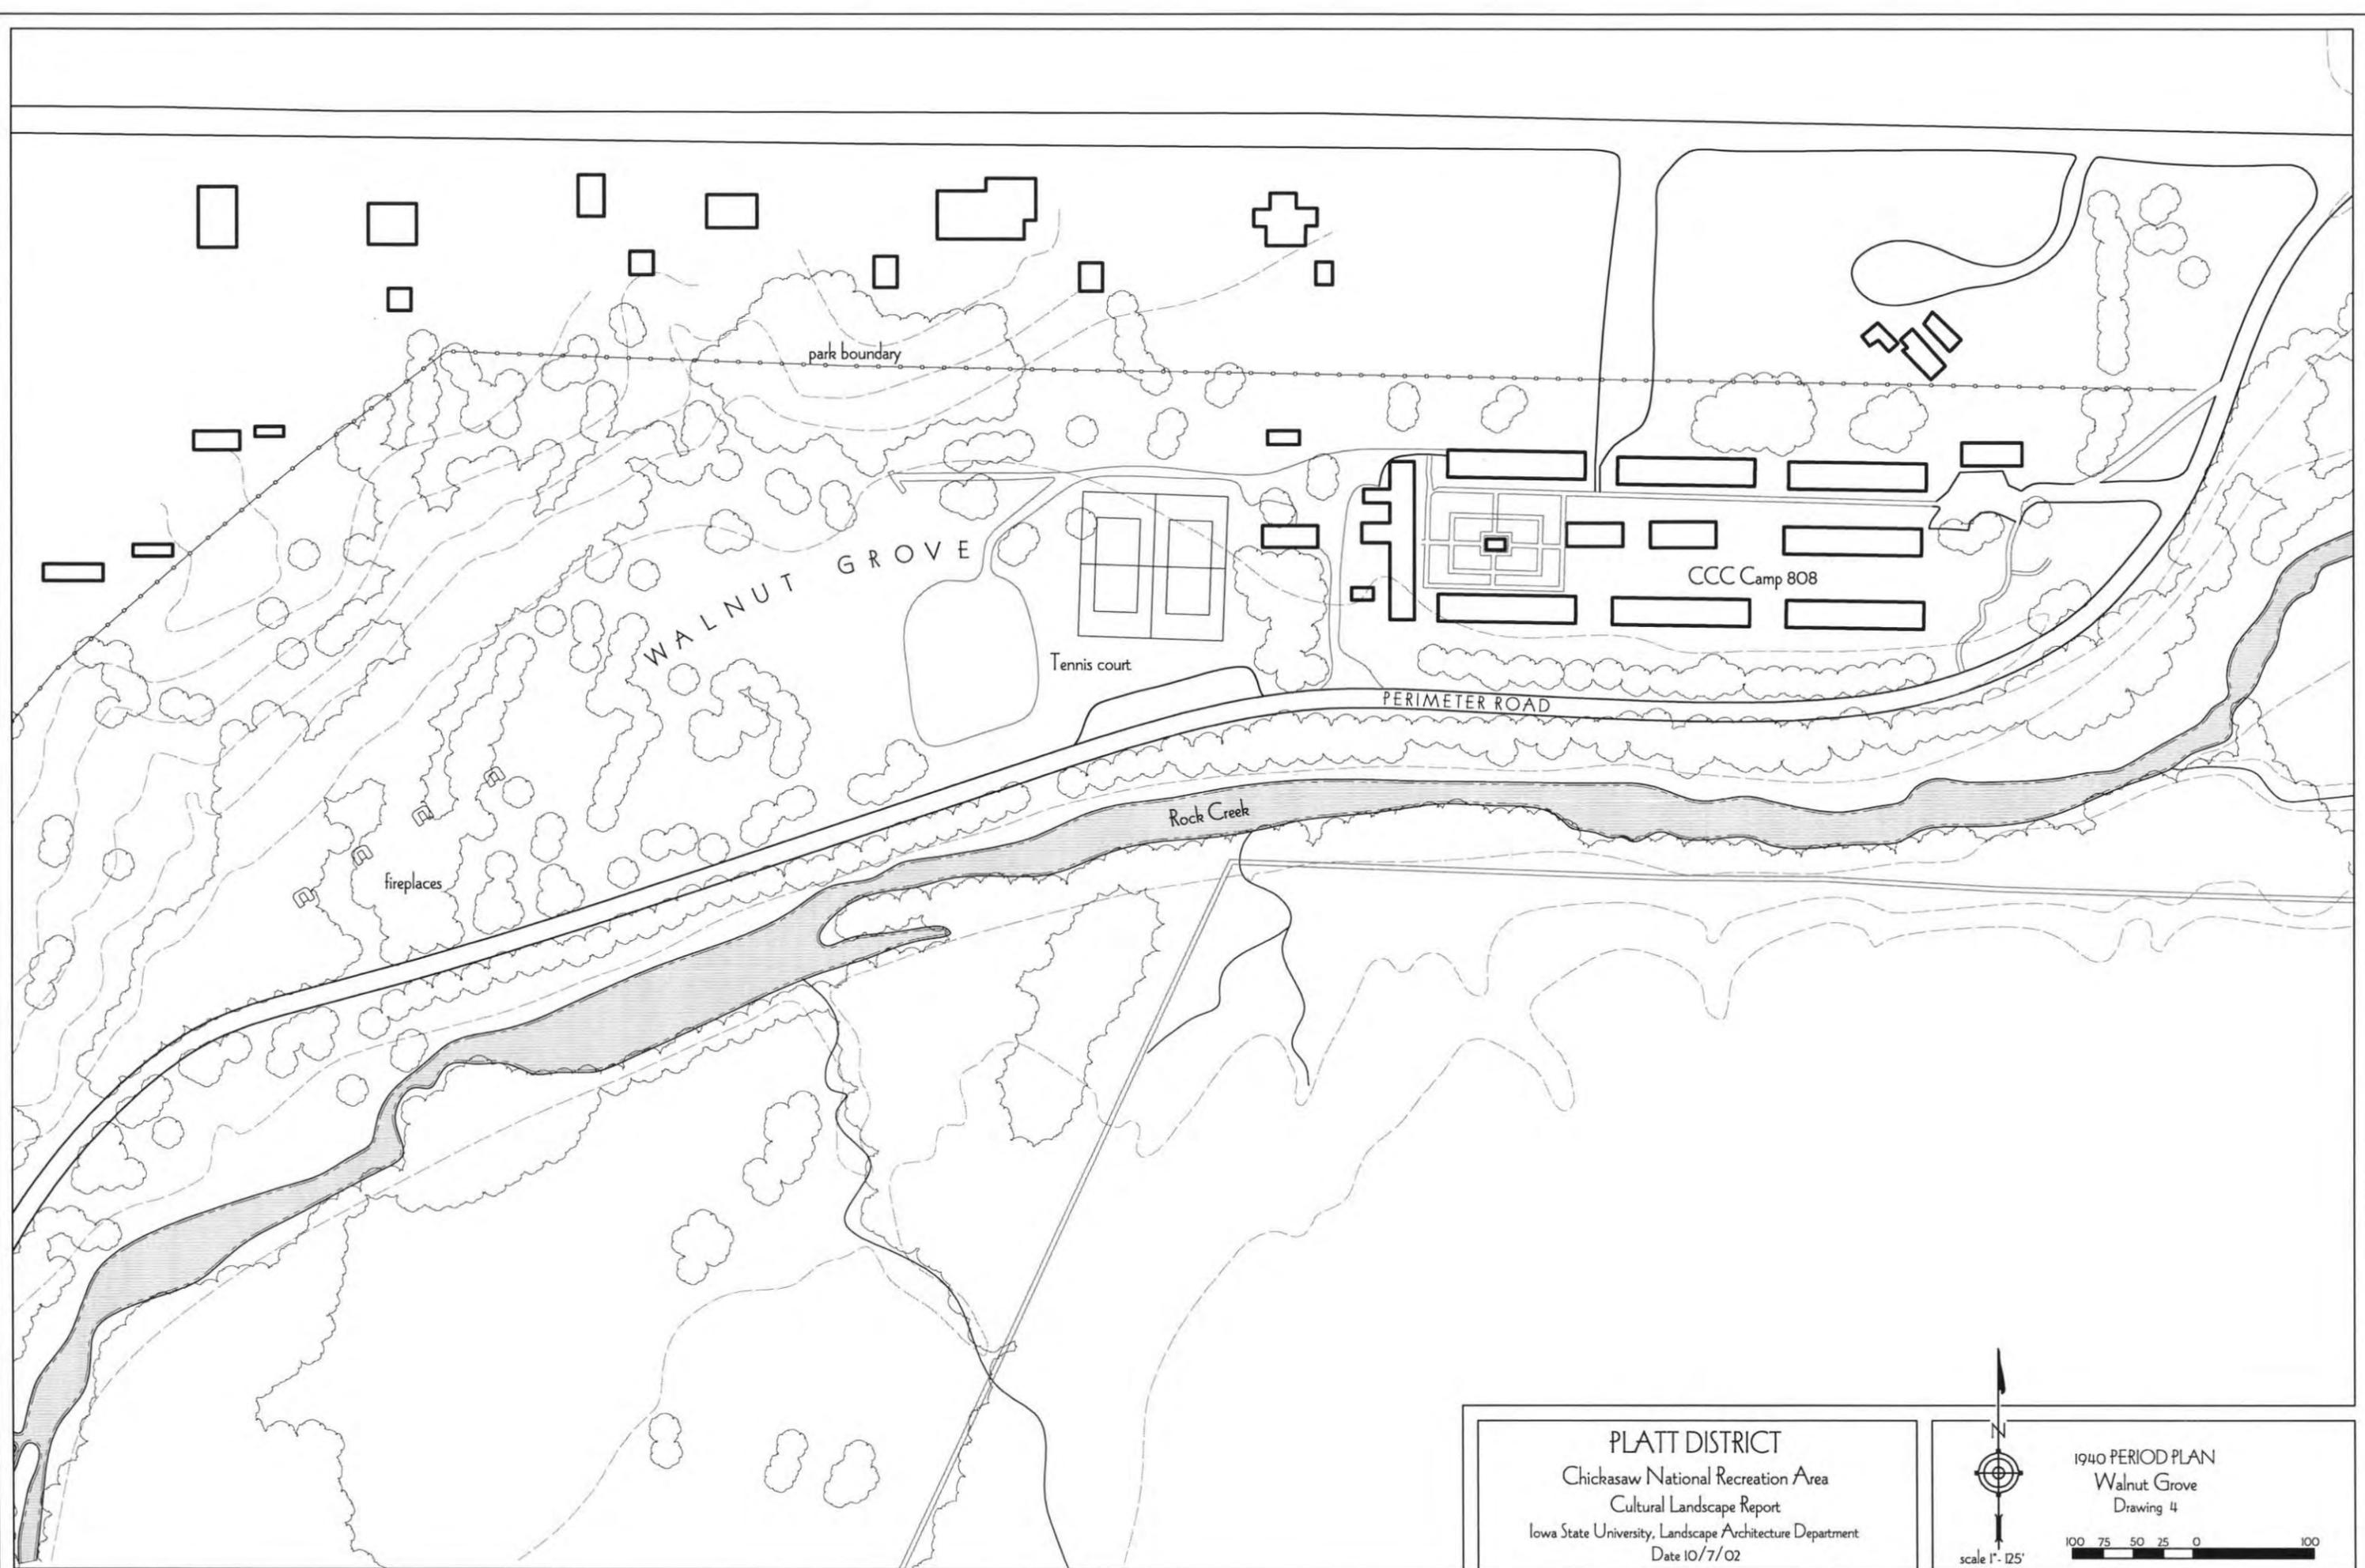


PLATT DISTRICT
Chickasaw National Recreation Area
Cultural Landscape Report
Iowa State University, Landscape Architecture Department
Date 10/7/02

1940 PERIOD PLAN
Walnut Grove
Drawing 4

scale 1" = 125'

A north arrow pointing upwards and a graphic scale bar with markings at 100, 75, 50, 25, 0, and 100 feet.

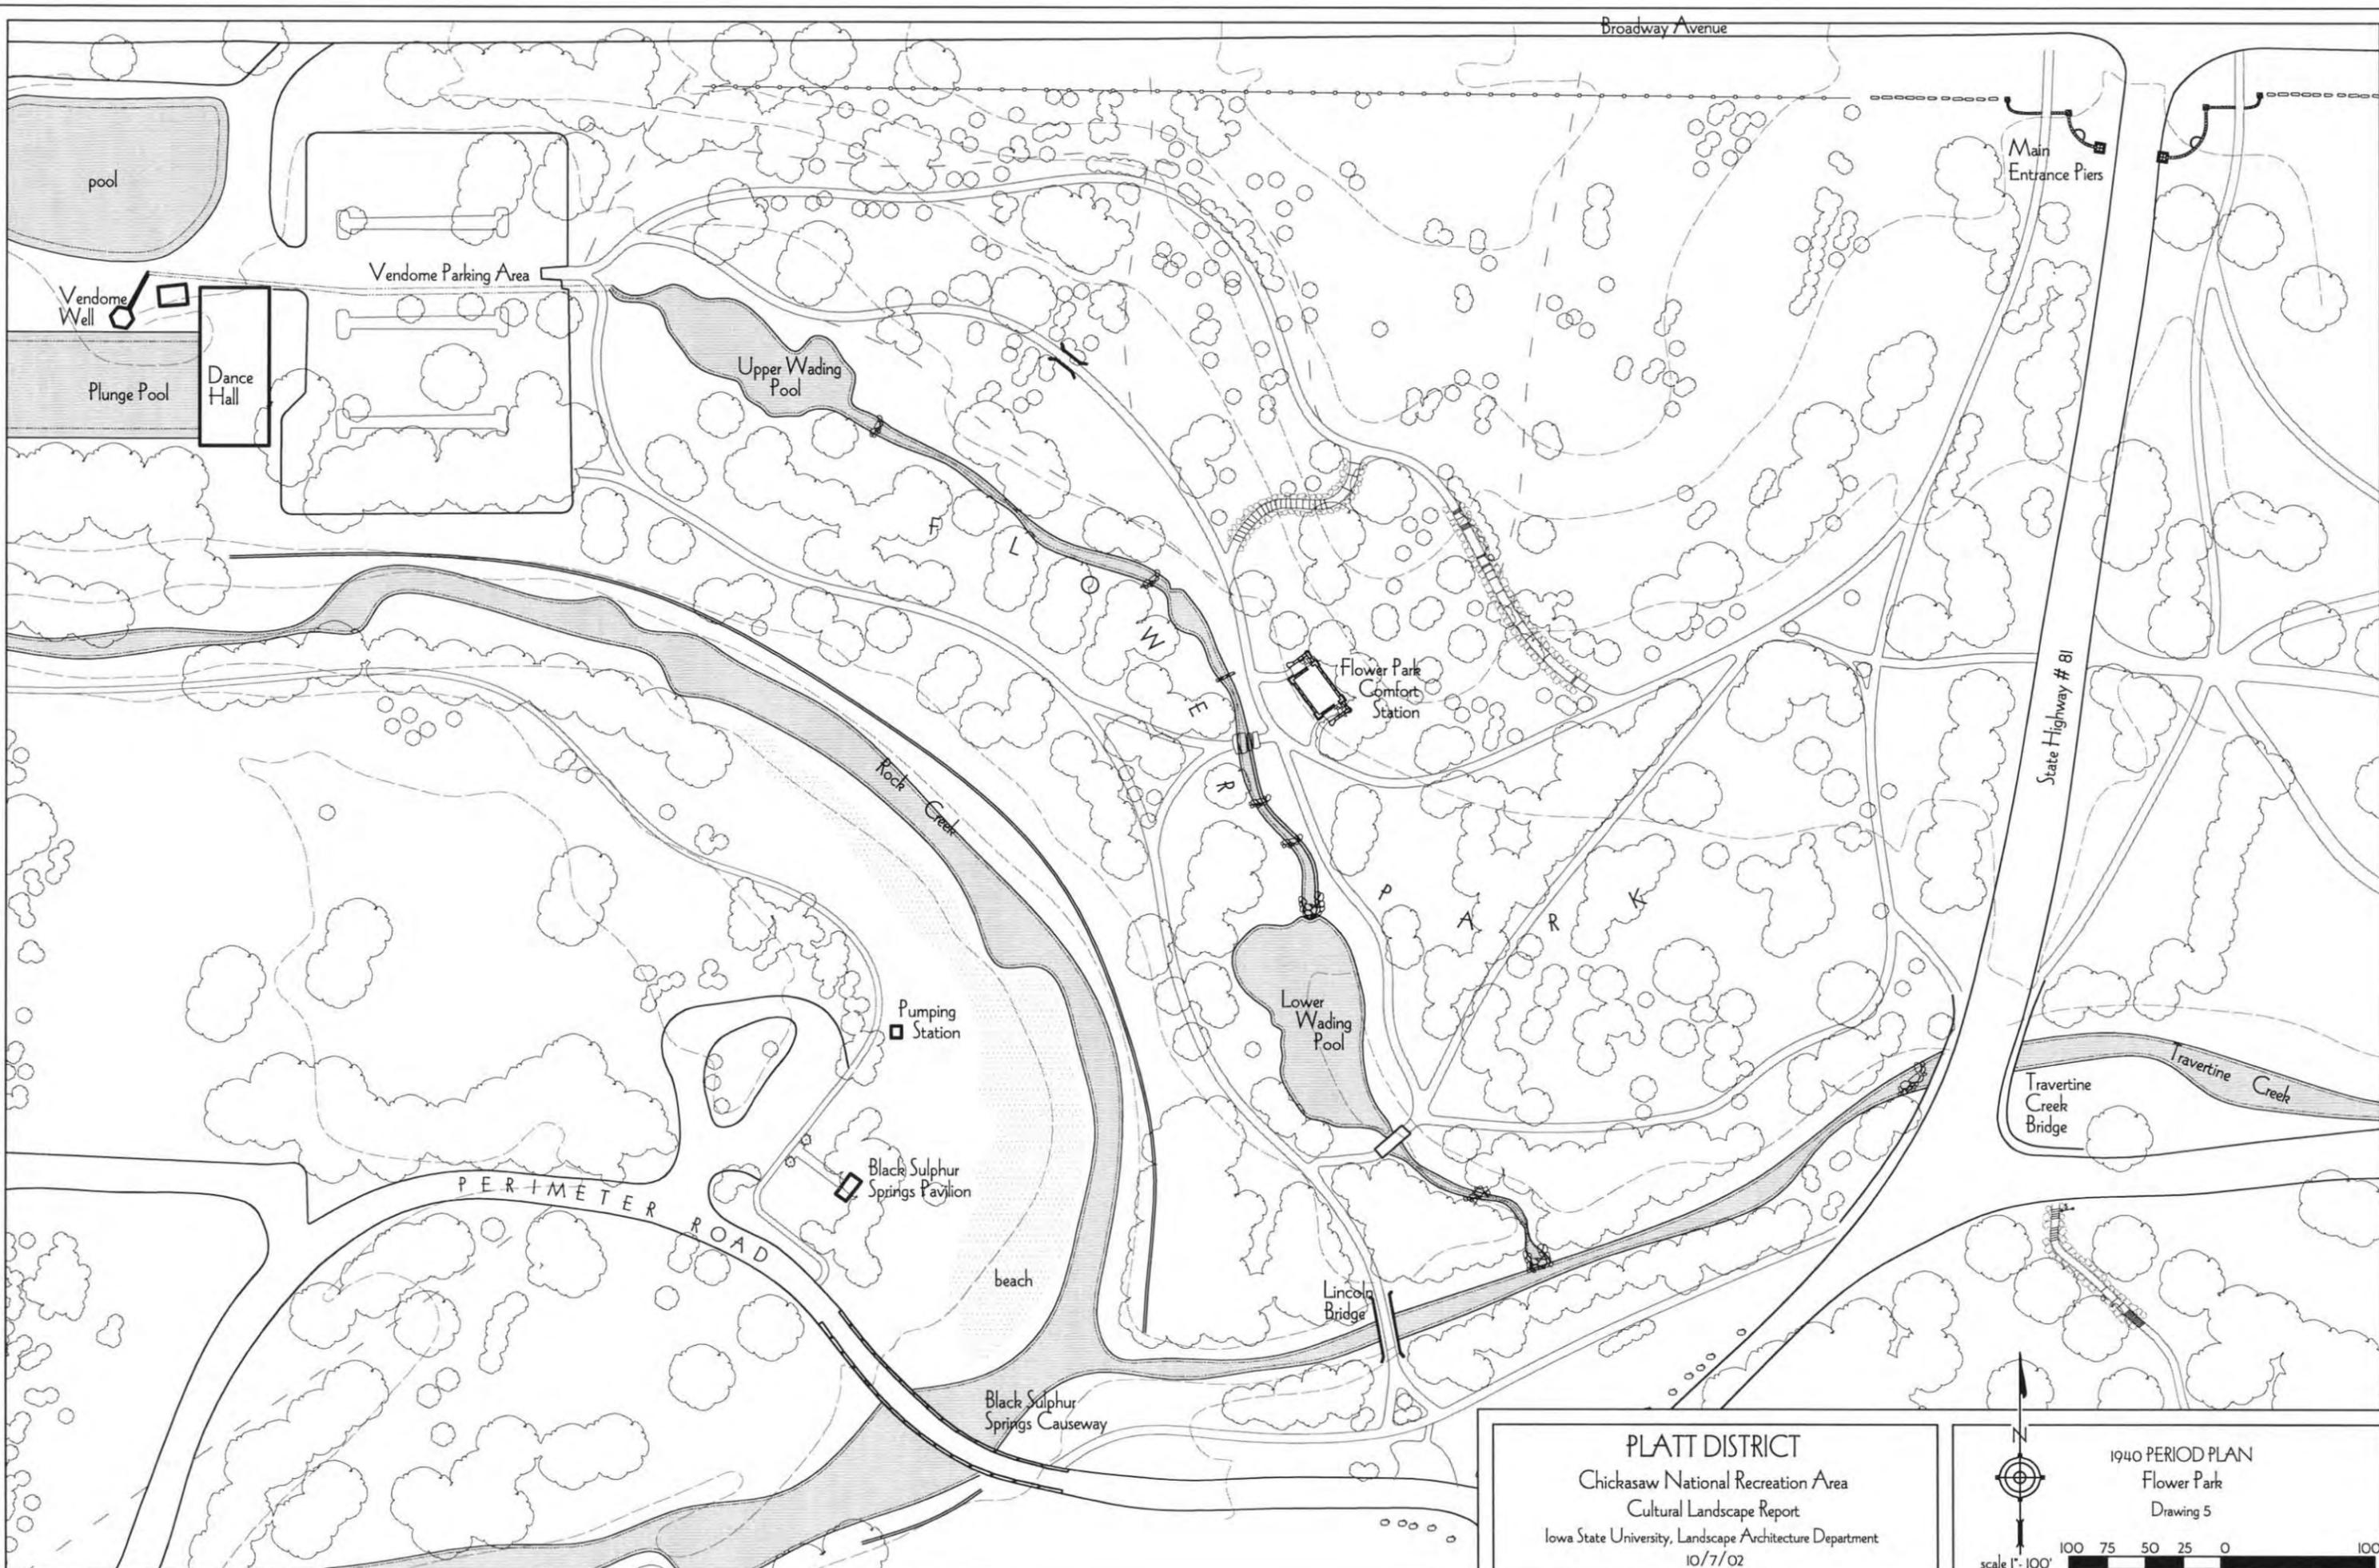


PLATT DISTRICT
 Chickasaw National Recreation Area
 Cultural Landscape Report
 Iowa State University, Landscape Architecture Department
 10/7/02

1940 PERIOD PLAN
 Flower Park
 Drawing 5

scale 1" = 100'

100 75 50 25 0 100

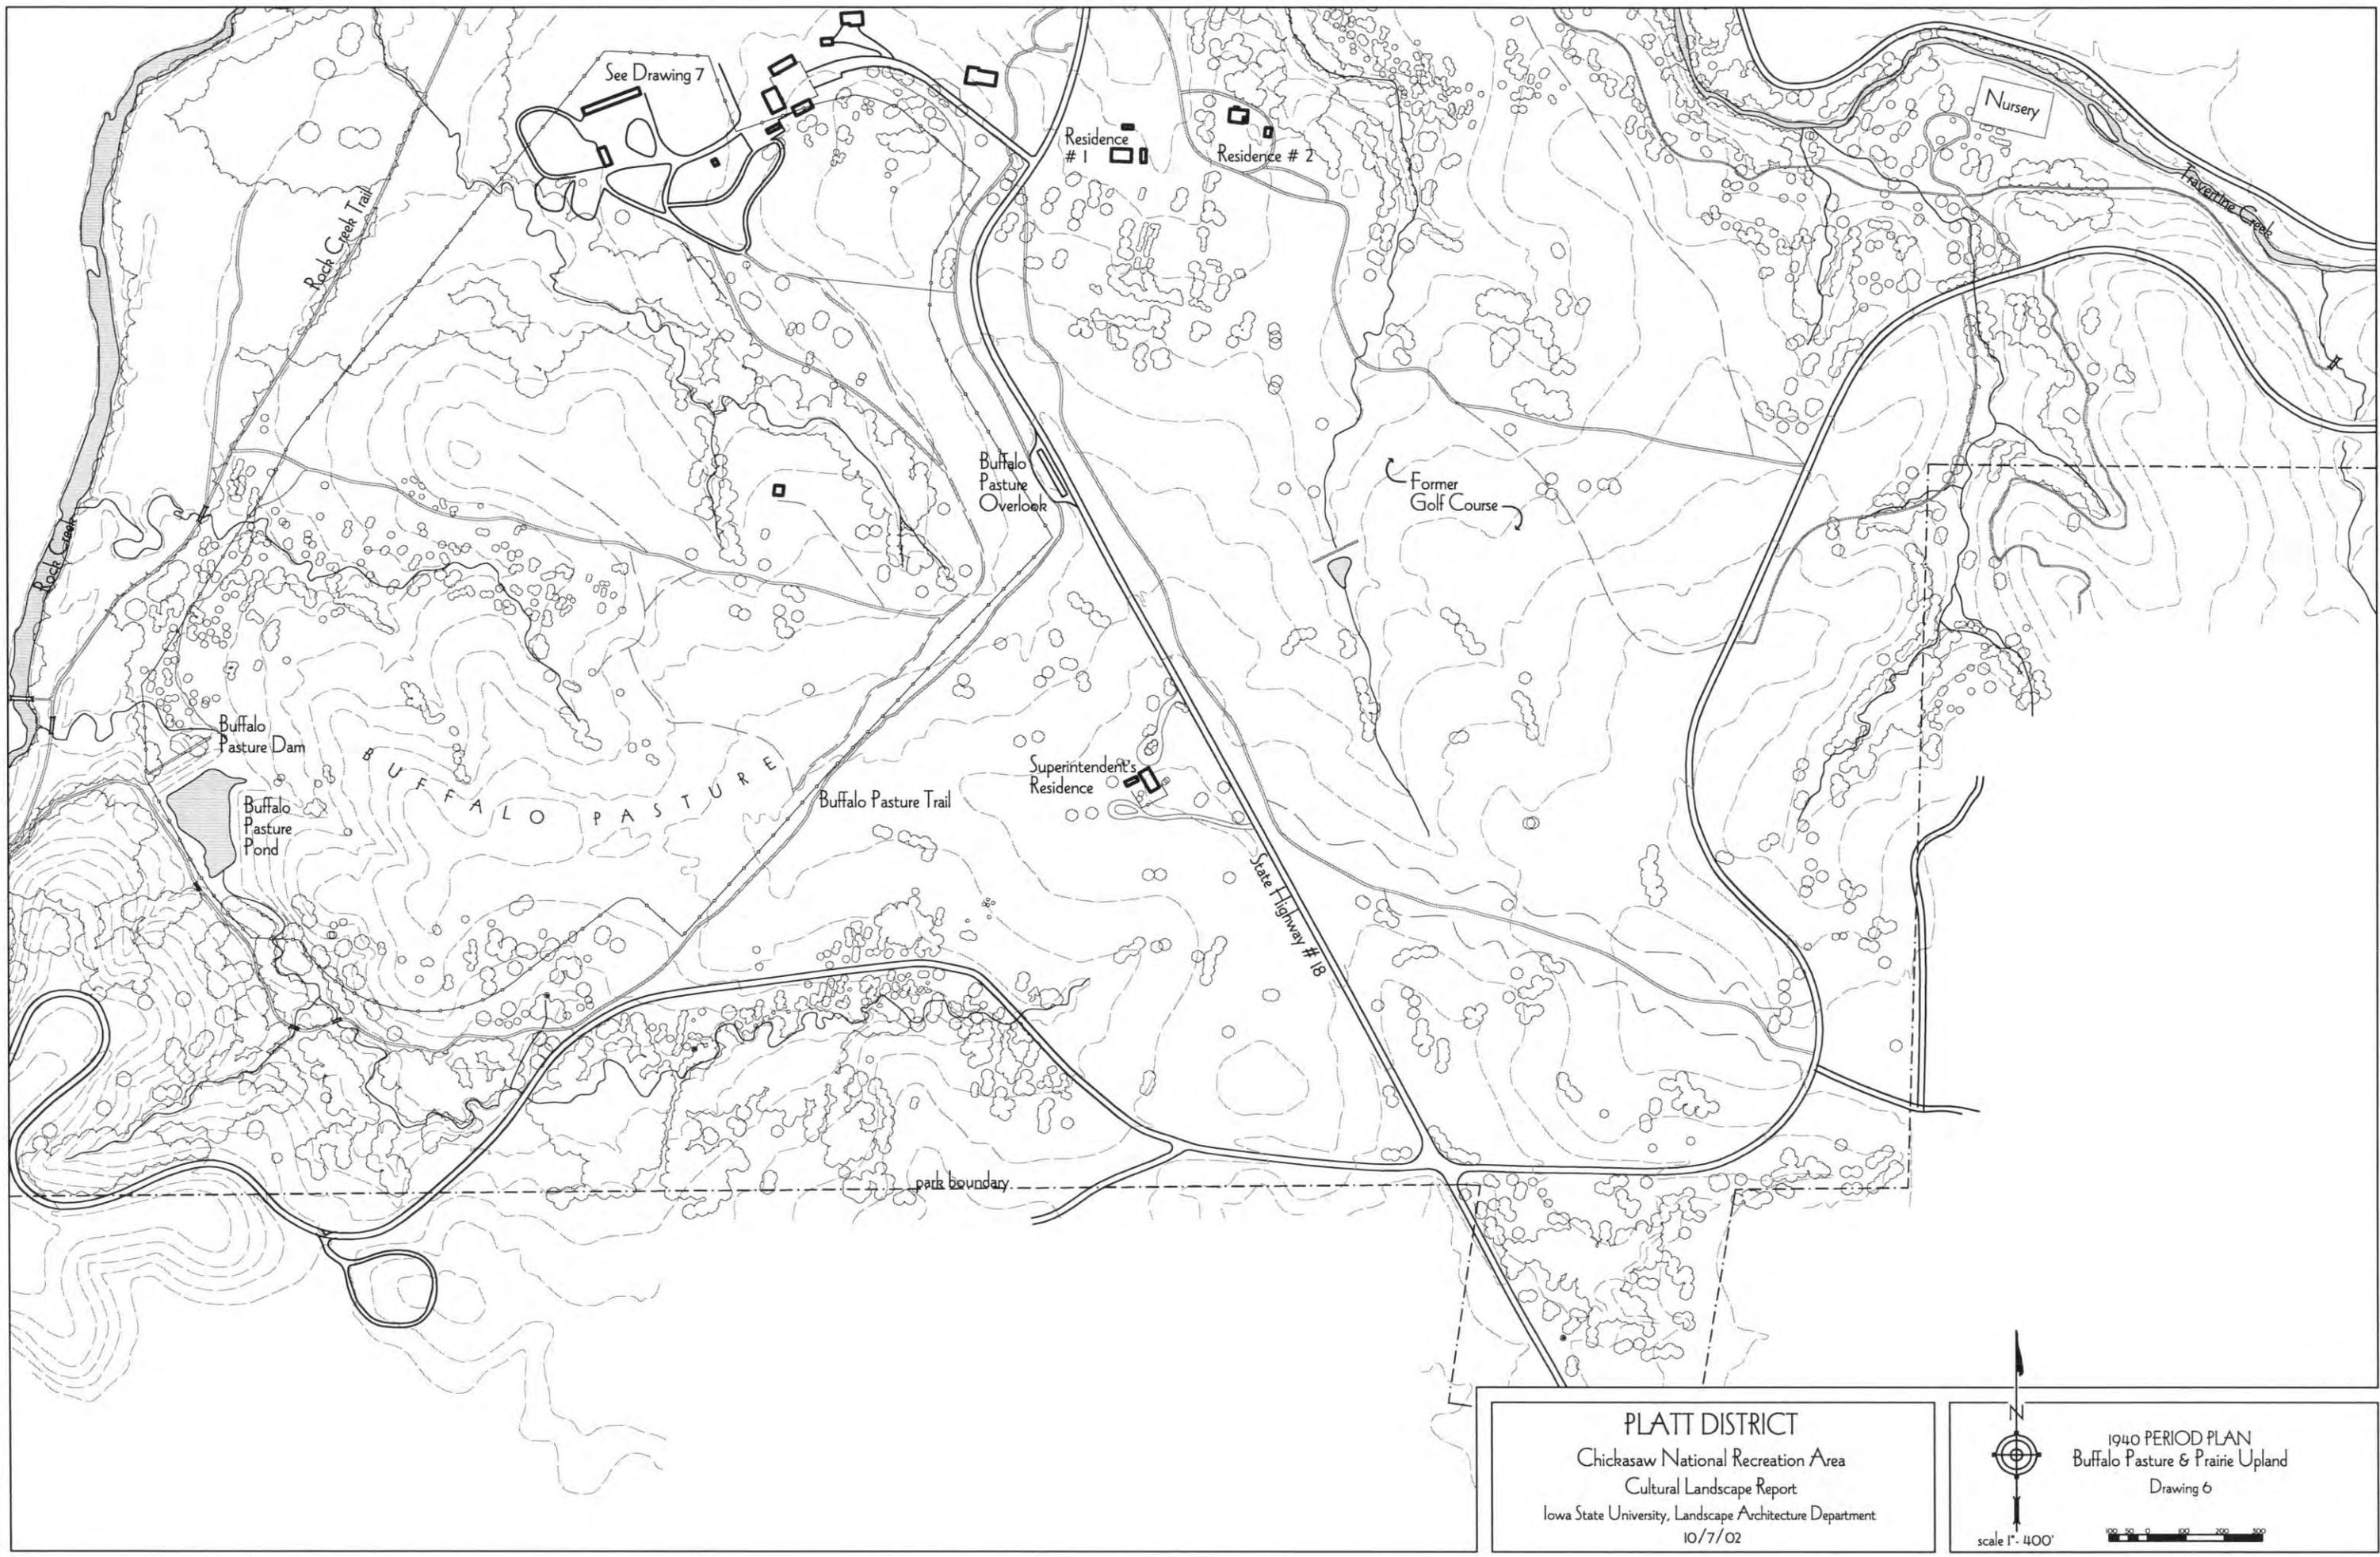


PLATT DISTRICT
Chickasaw National Recreation Area
Cultural Landscape Report
Iowa State University, Landscape Architecture Department
10/7/02

1940 PERIOD PLAN
Buffalo Pasture & Prairie Upland
Drawing 6

scale 1" = 400'


0 100 200 300

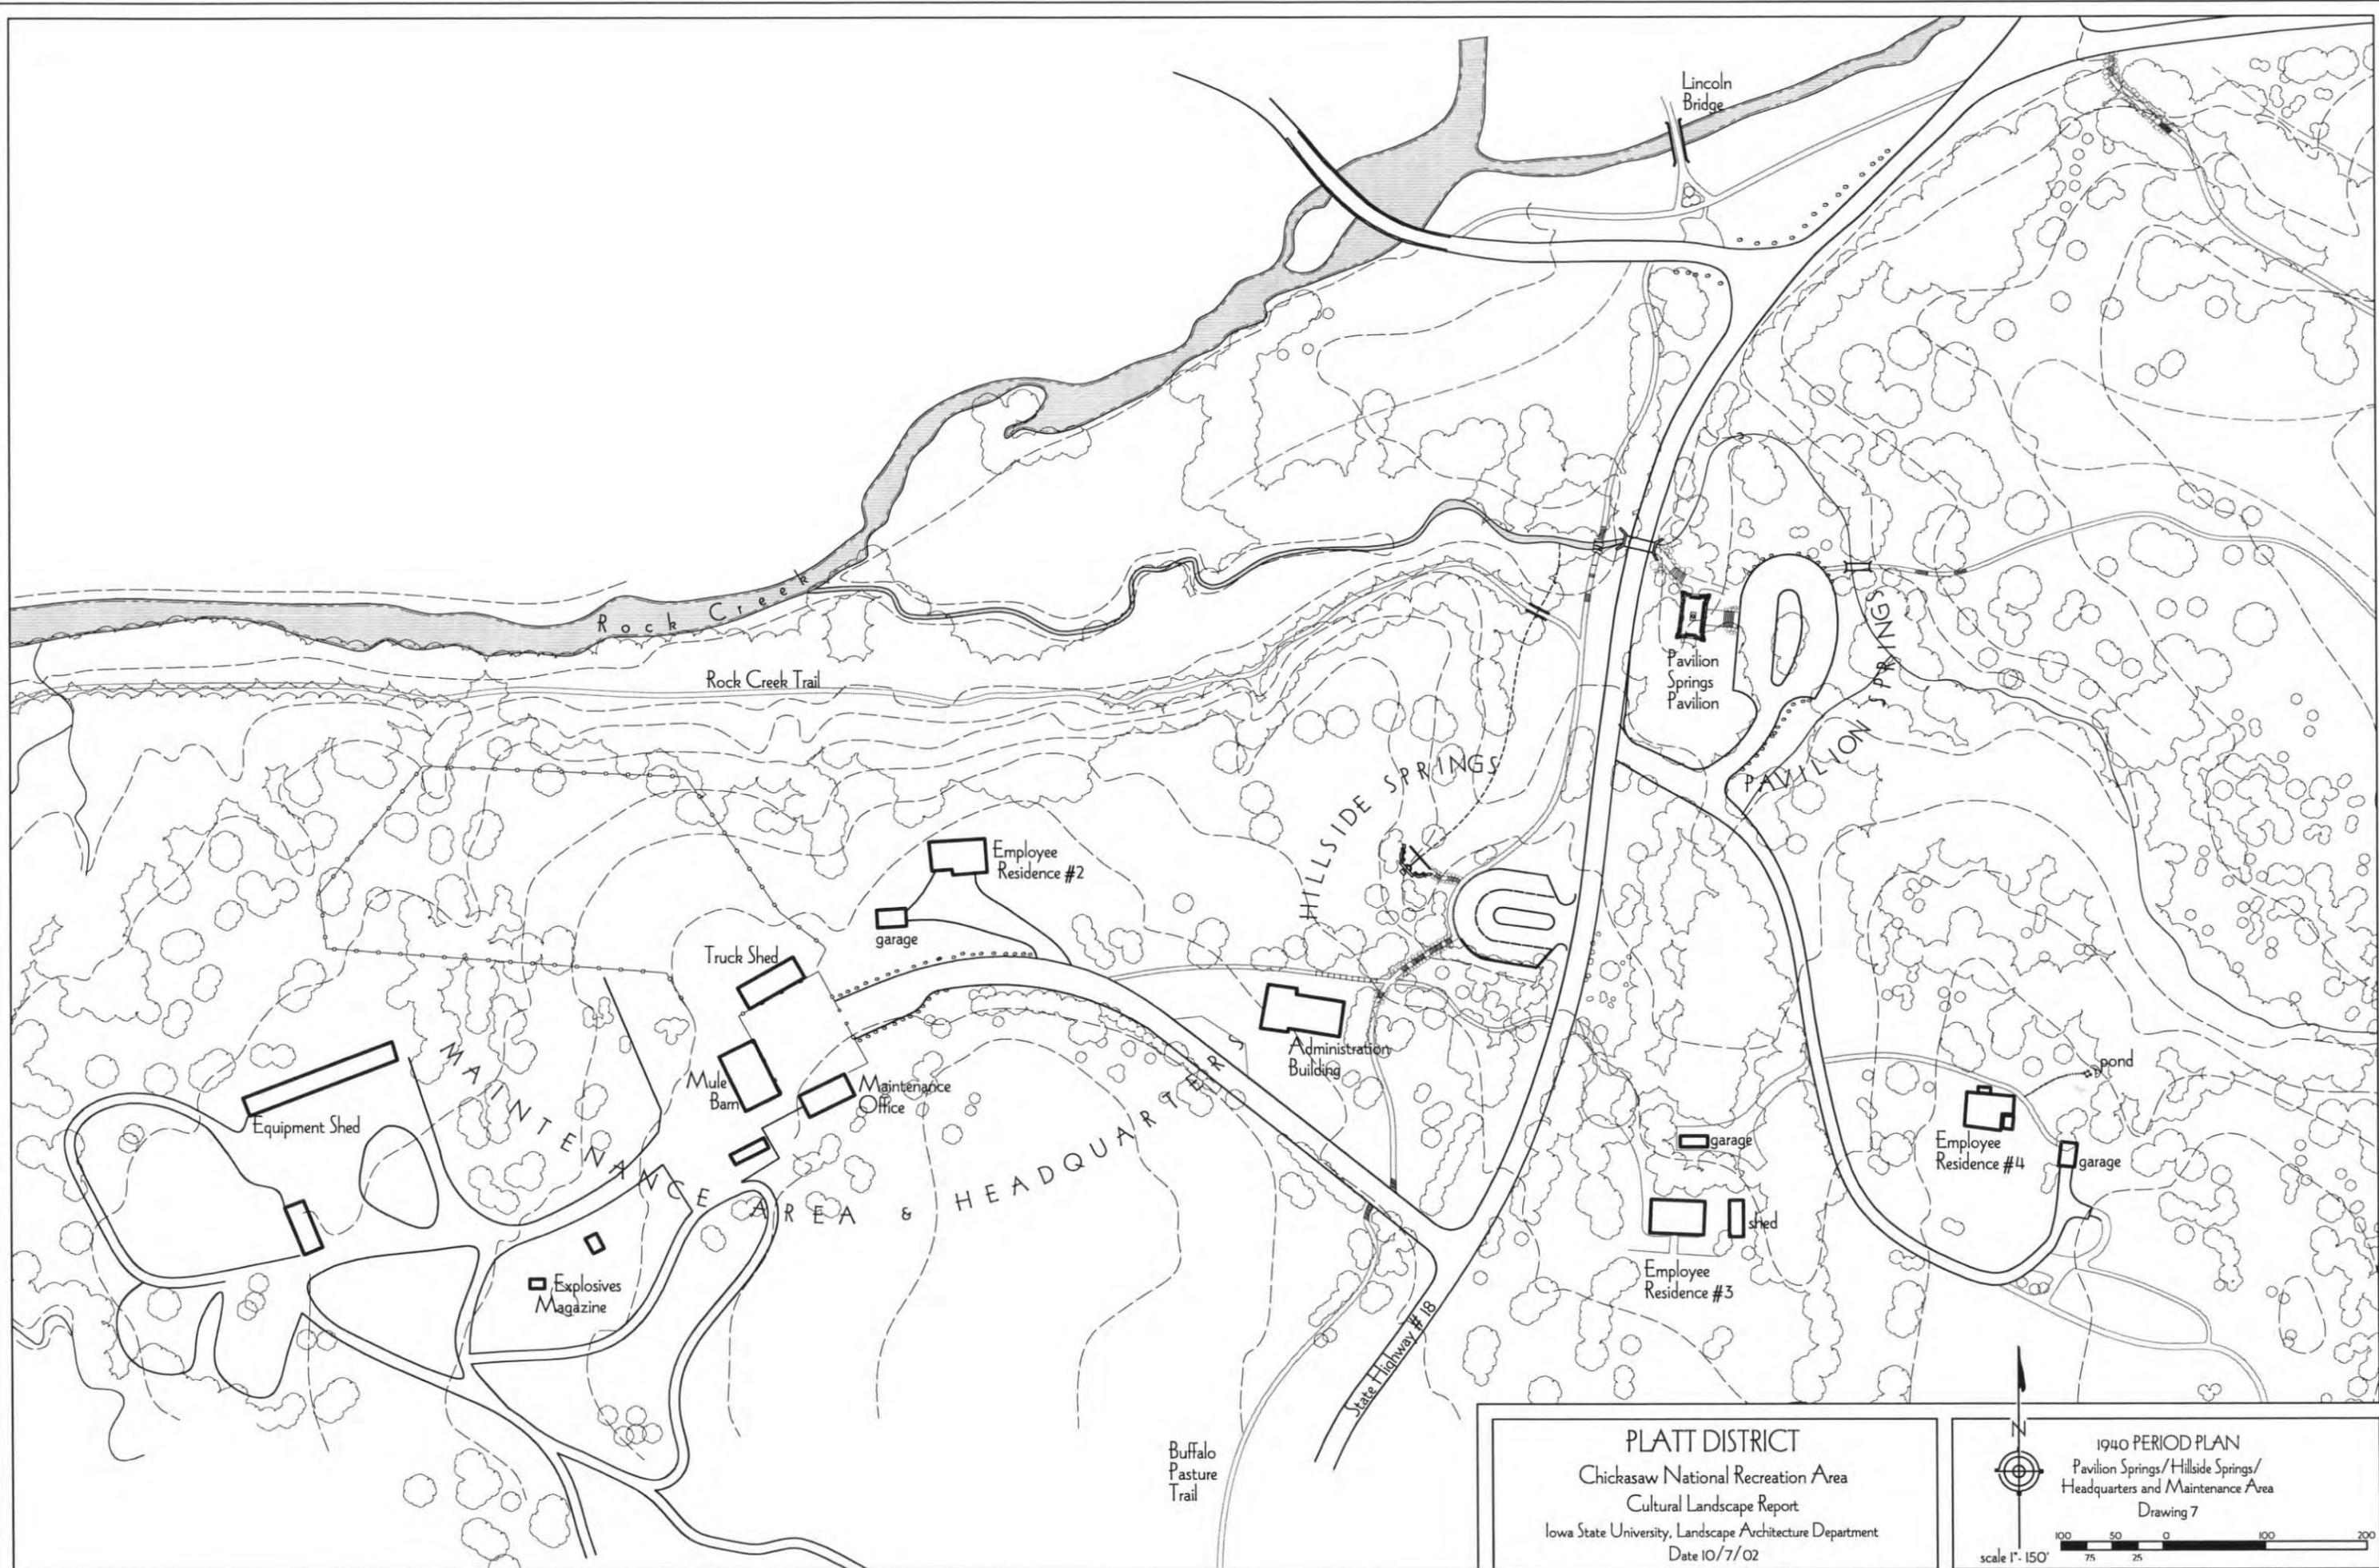

PLATT DISTRICT
 Chickasaw National Recreation Area
 Cultural Landscape Report
 Iowa State University, Landscape Architecture Department
 Date 10/7/02

1940 PERIOD PLAN
 Pavilion Springs/Hillside Springs/
 Headquarters and Maintenance Area
 Drawing 7


scale 1" = 150'

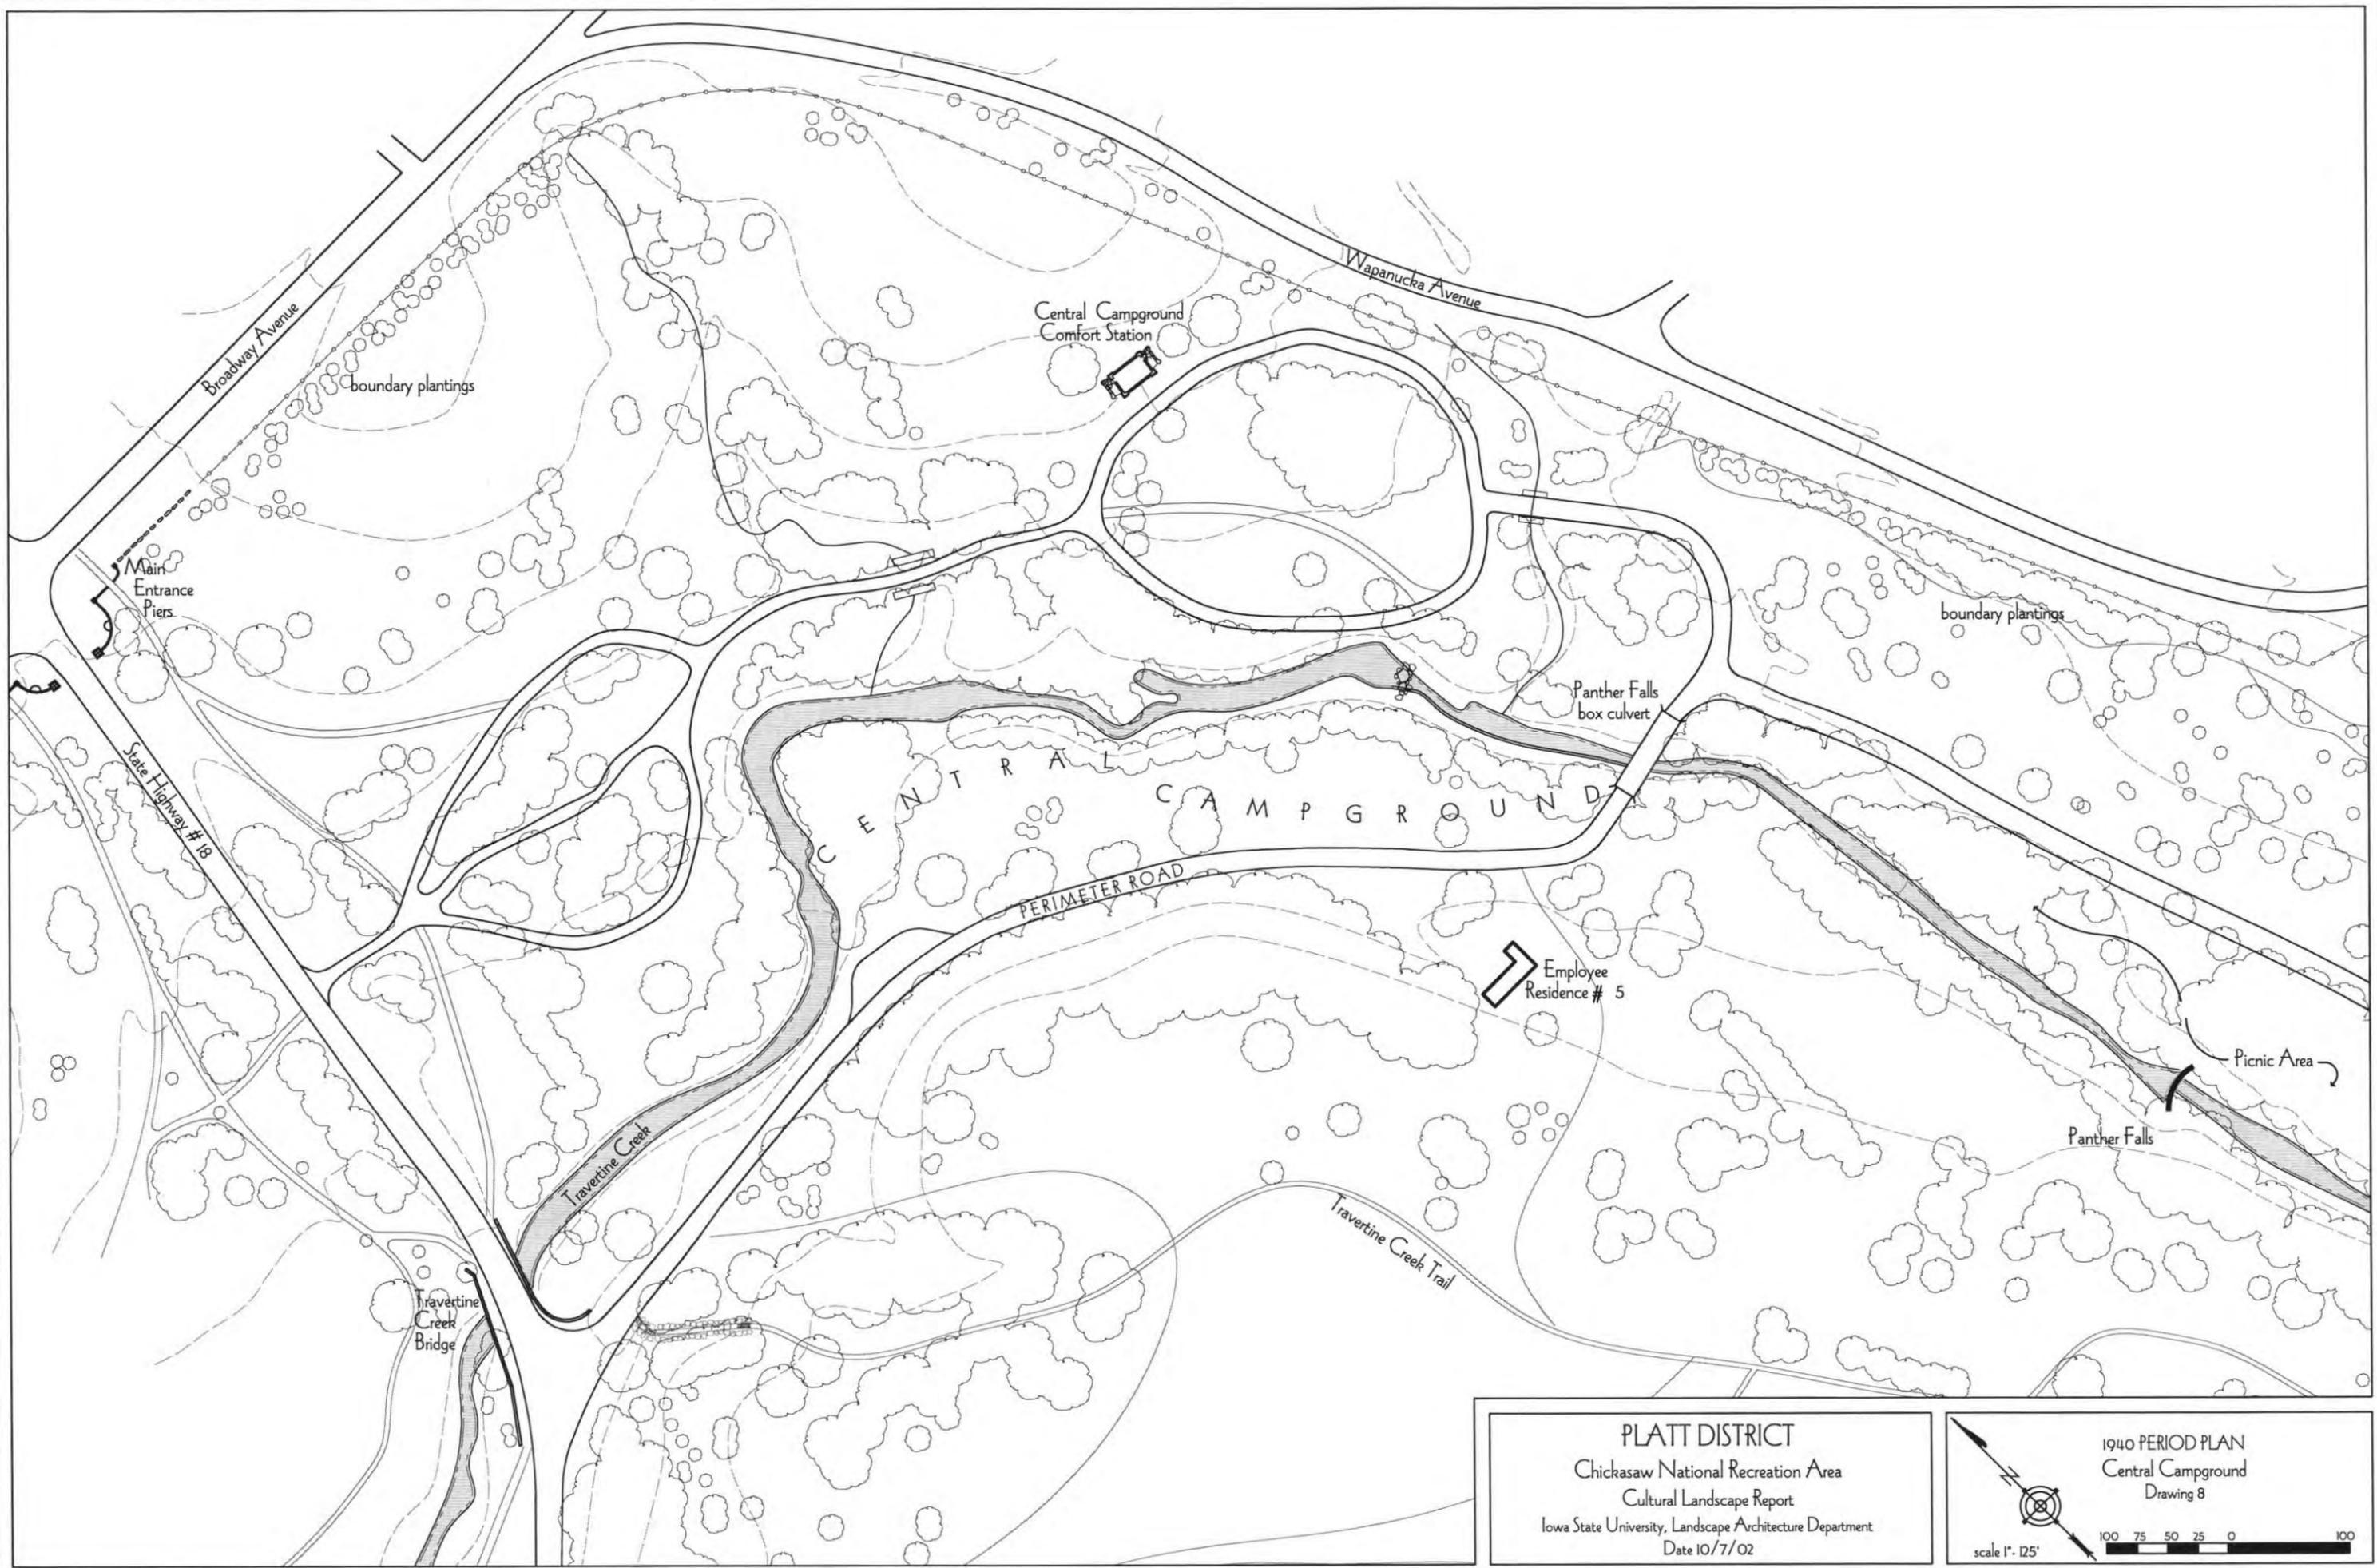

PLATT DISTRICT
 Chickasaw National Recreation Area
 Cultural Landscape Report
 Iowa State University, Landscape Architecture Department
 Date 10/7/02

1940 PERIOD PLAN
 Central Campground
 Drawing 8

scale 1" = 125'

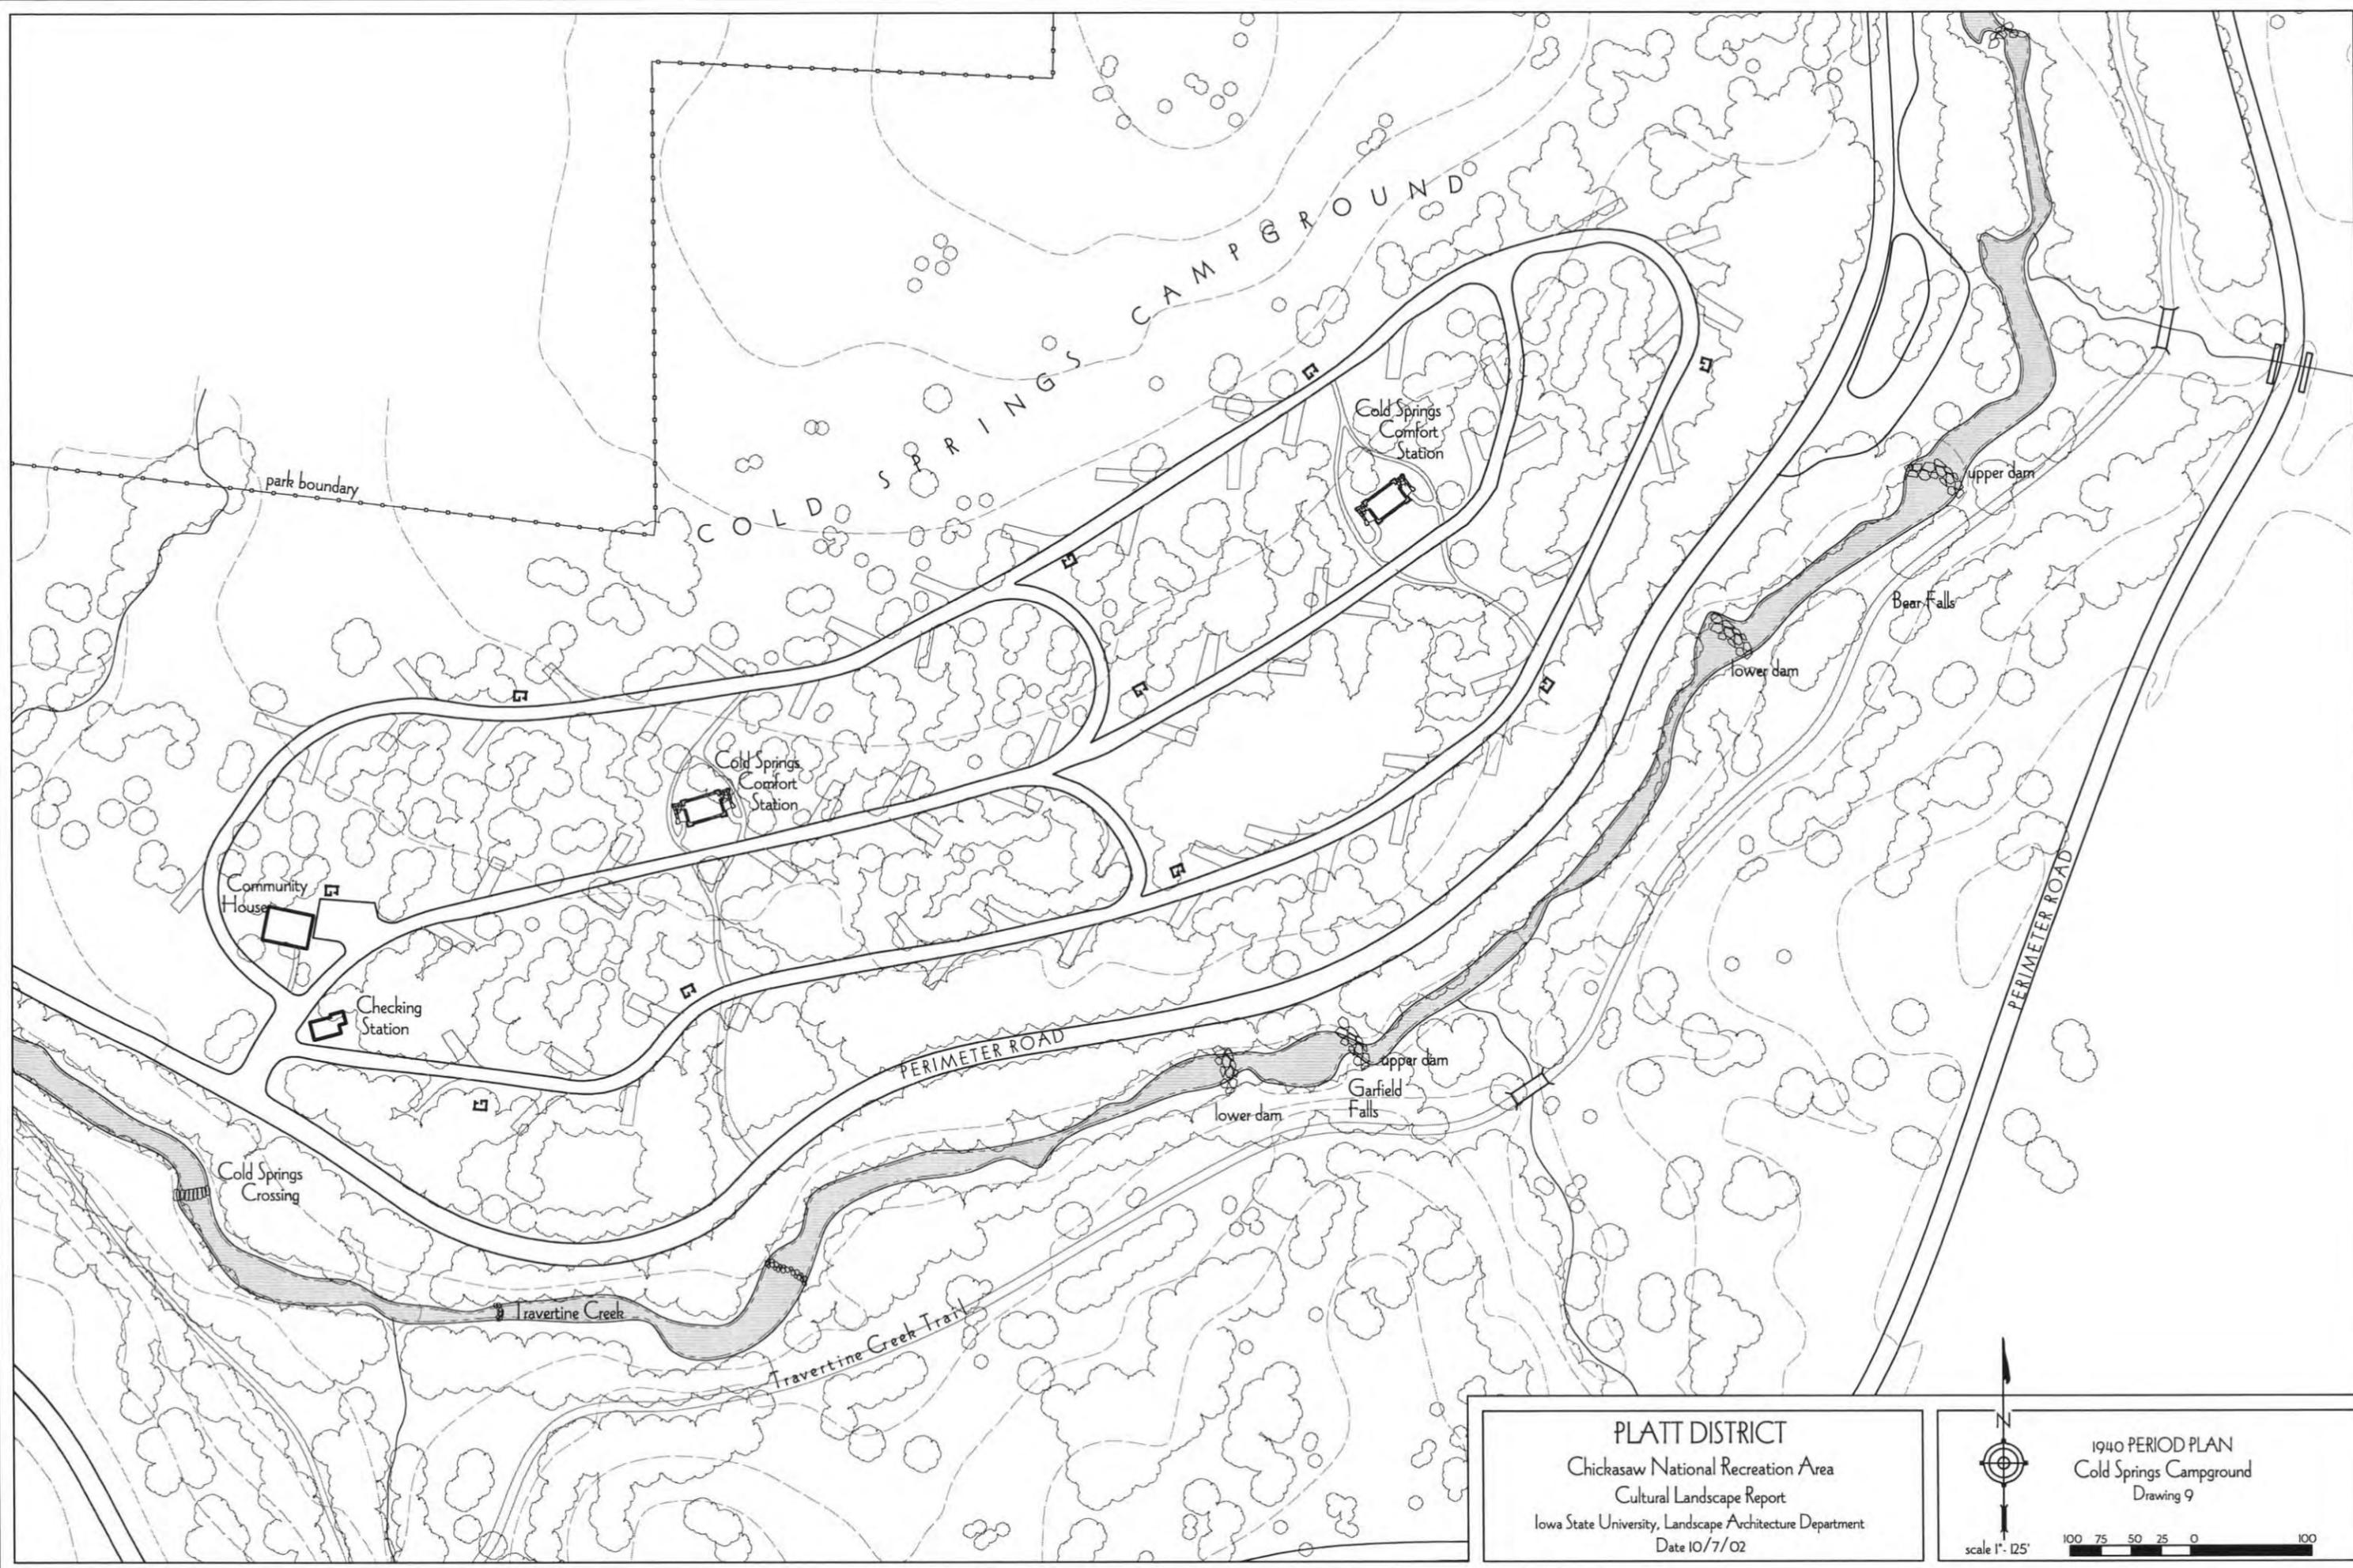


PLATT DISTRICT
 Chickasaw National Recreation Area
 Cultural Landscape Report
 Iowa State University, Landscape Architecture Department
 Date 10/7/02

1940 PERIOD PLAN
 Cold Springs Campground
 Drawing 9

scale 1" = 25'


100 75 50 25 0 100

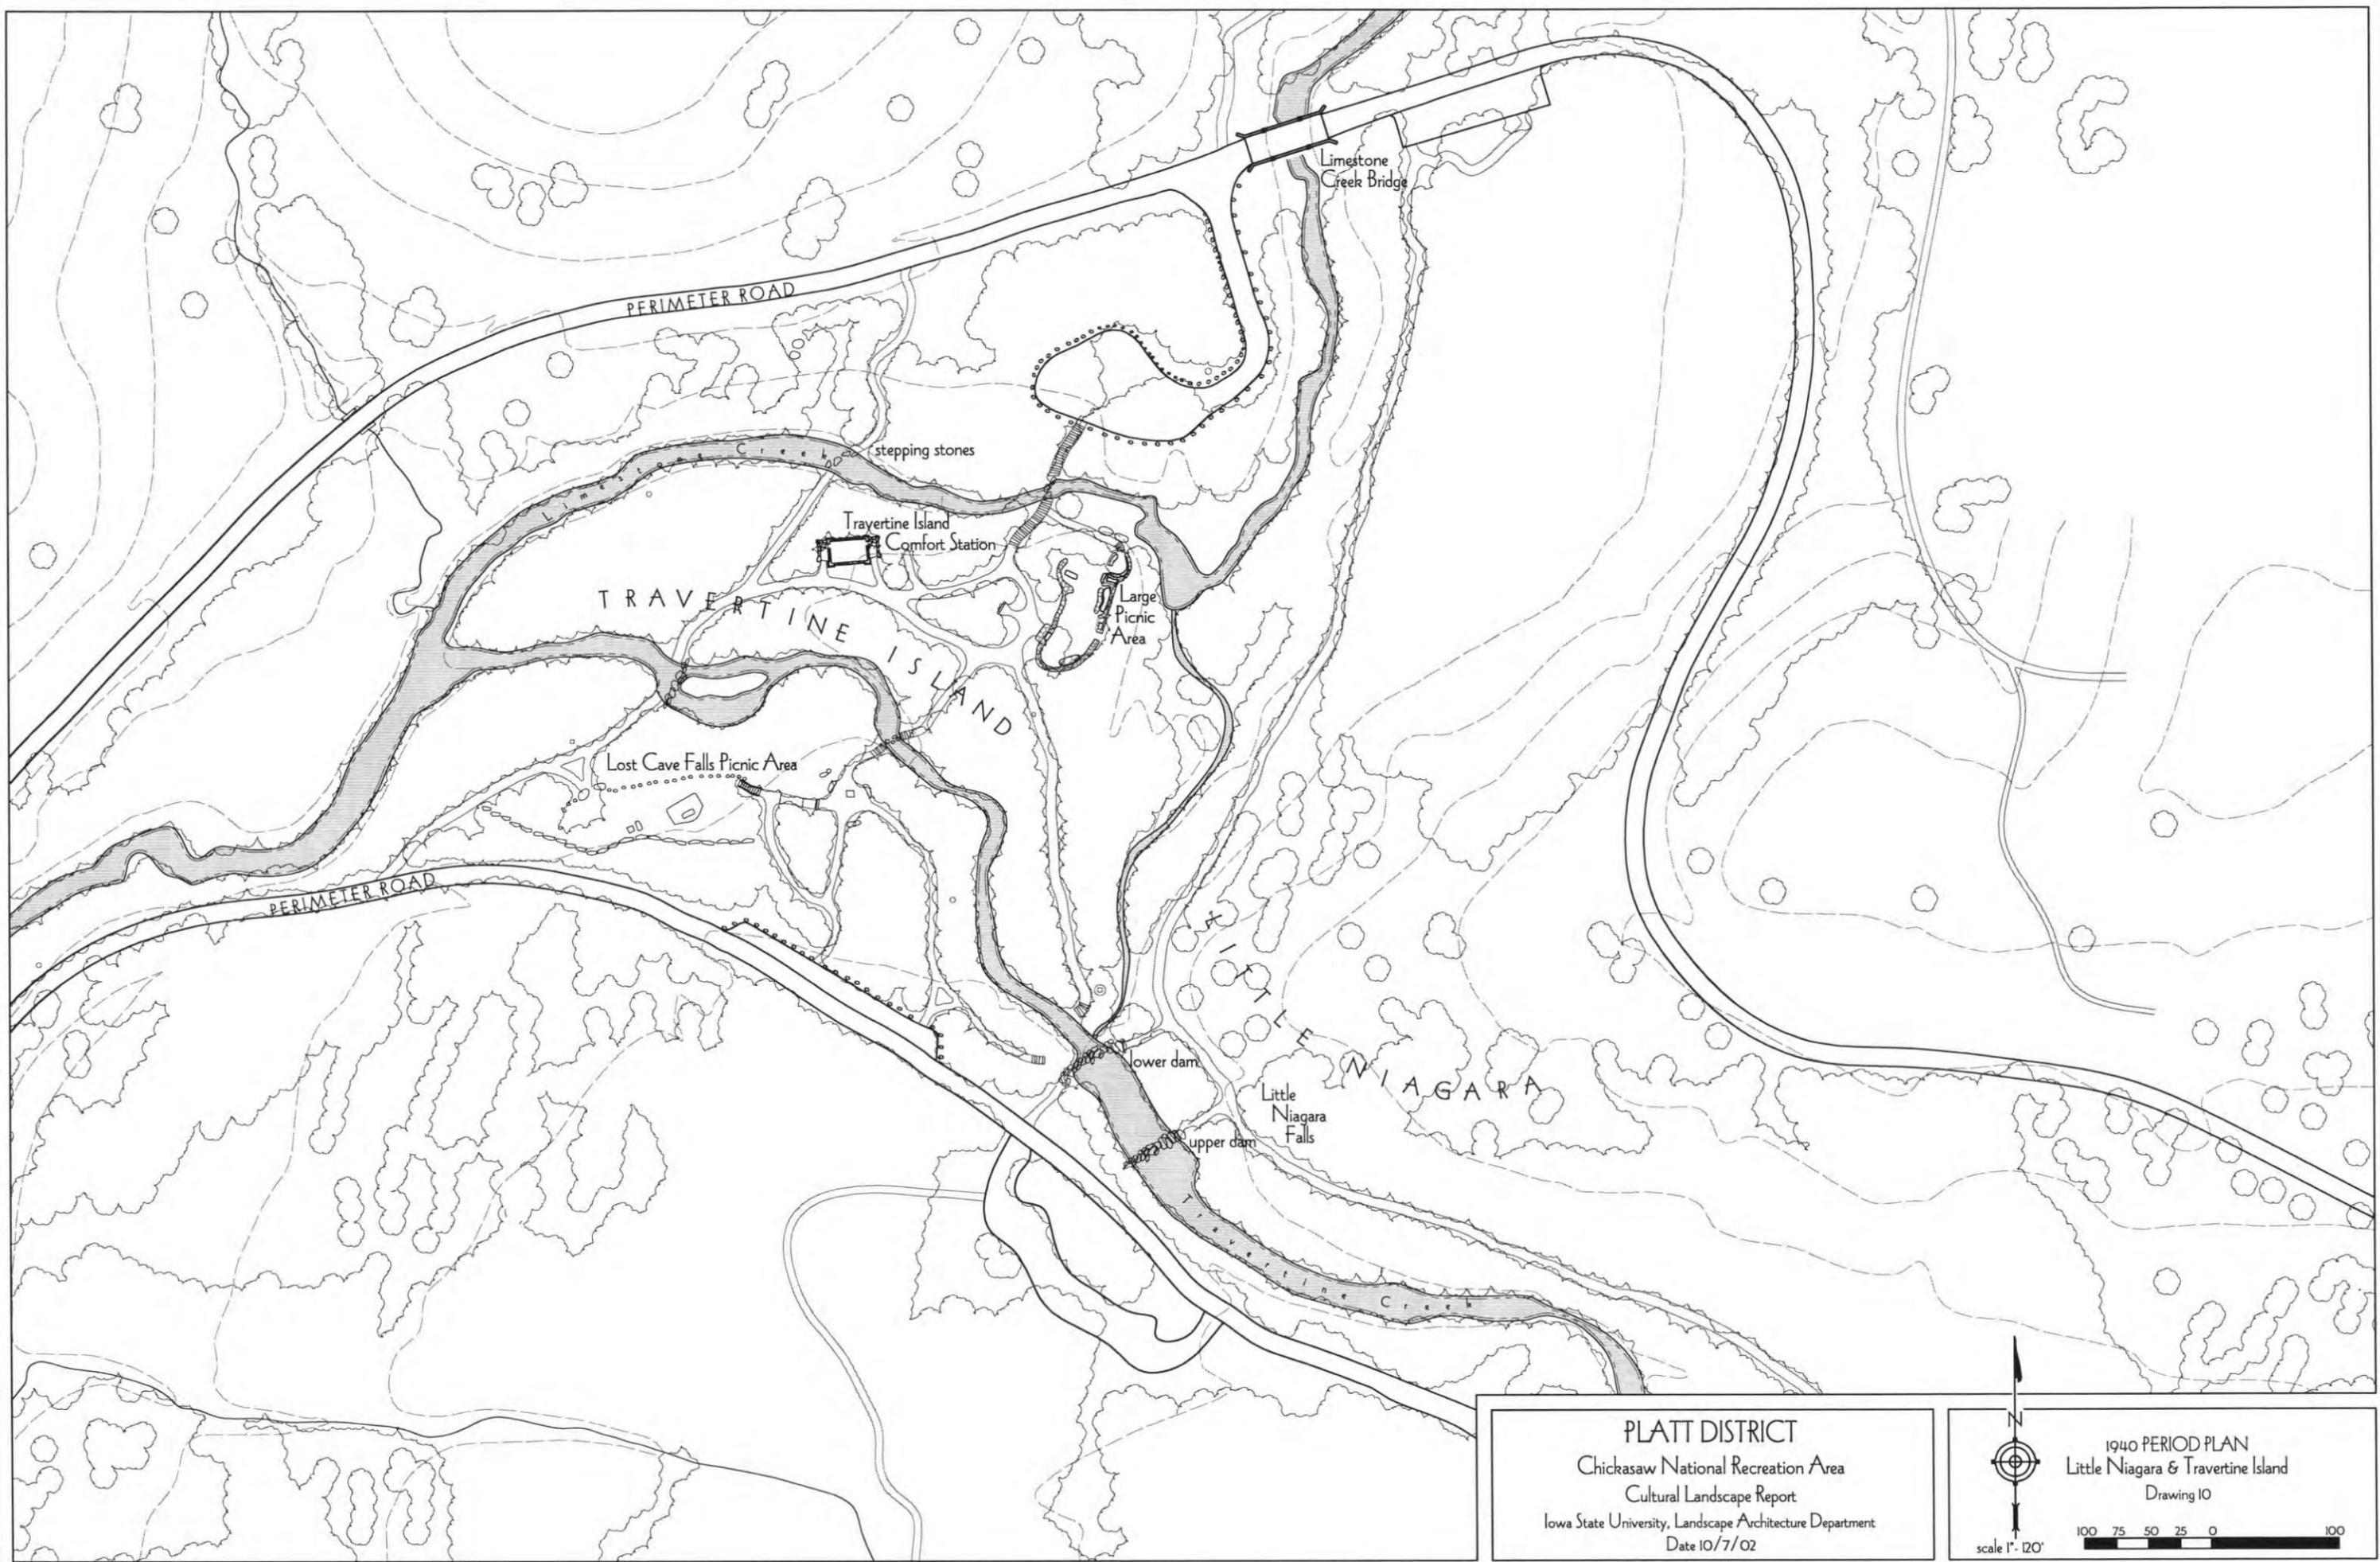

PLATT DISTRICT
 Chickasaw National Recreation Area
 Cultural Landscape Report
 Iowa State University, Landscape Architecture Department
 Date 10/7/02

1940 PERIOD PLAN
 Little Niagara & Travertine Island
 Drawing 10


scale 1" = 120'

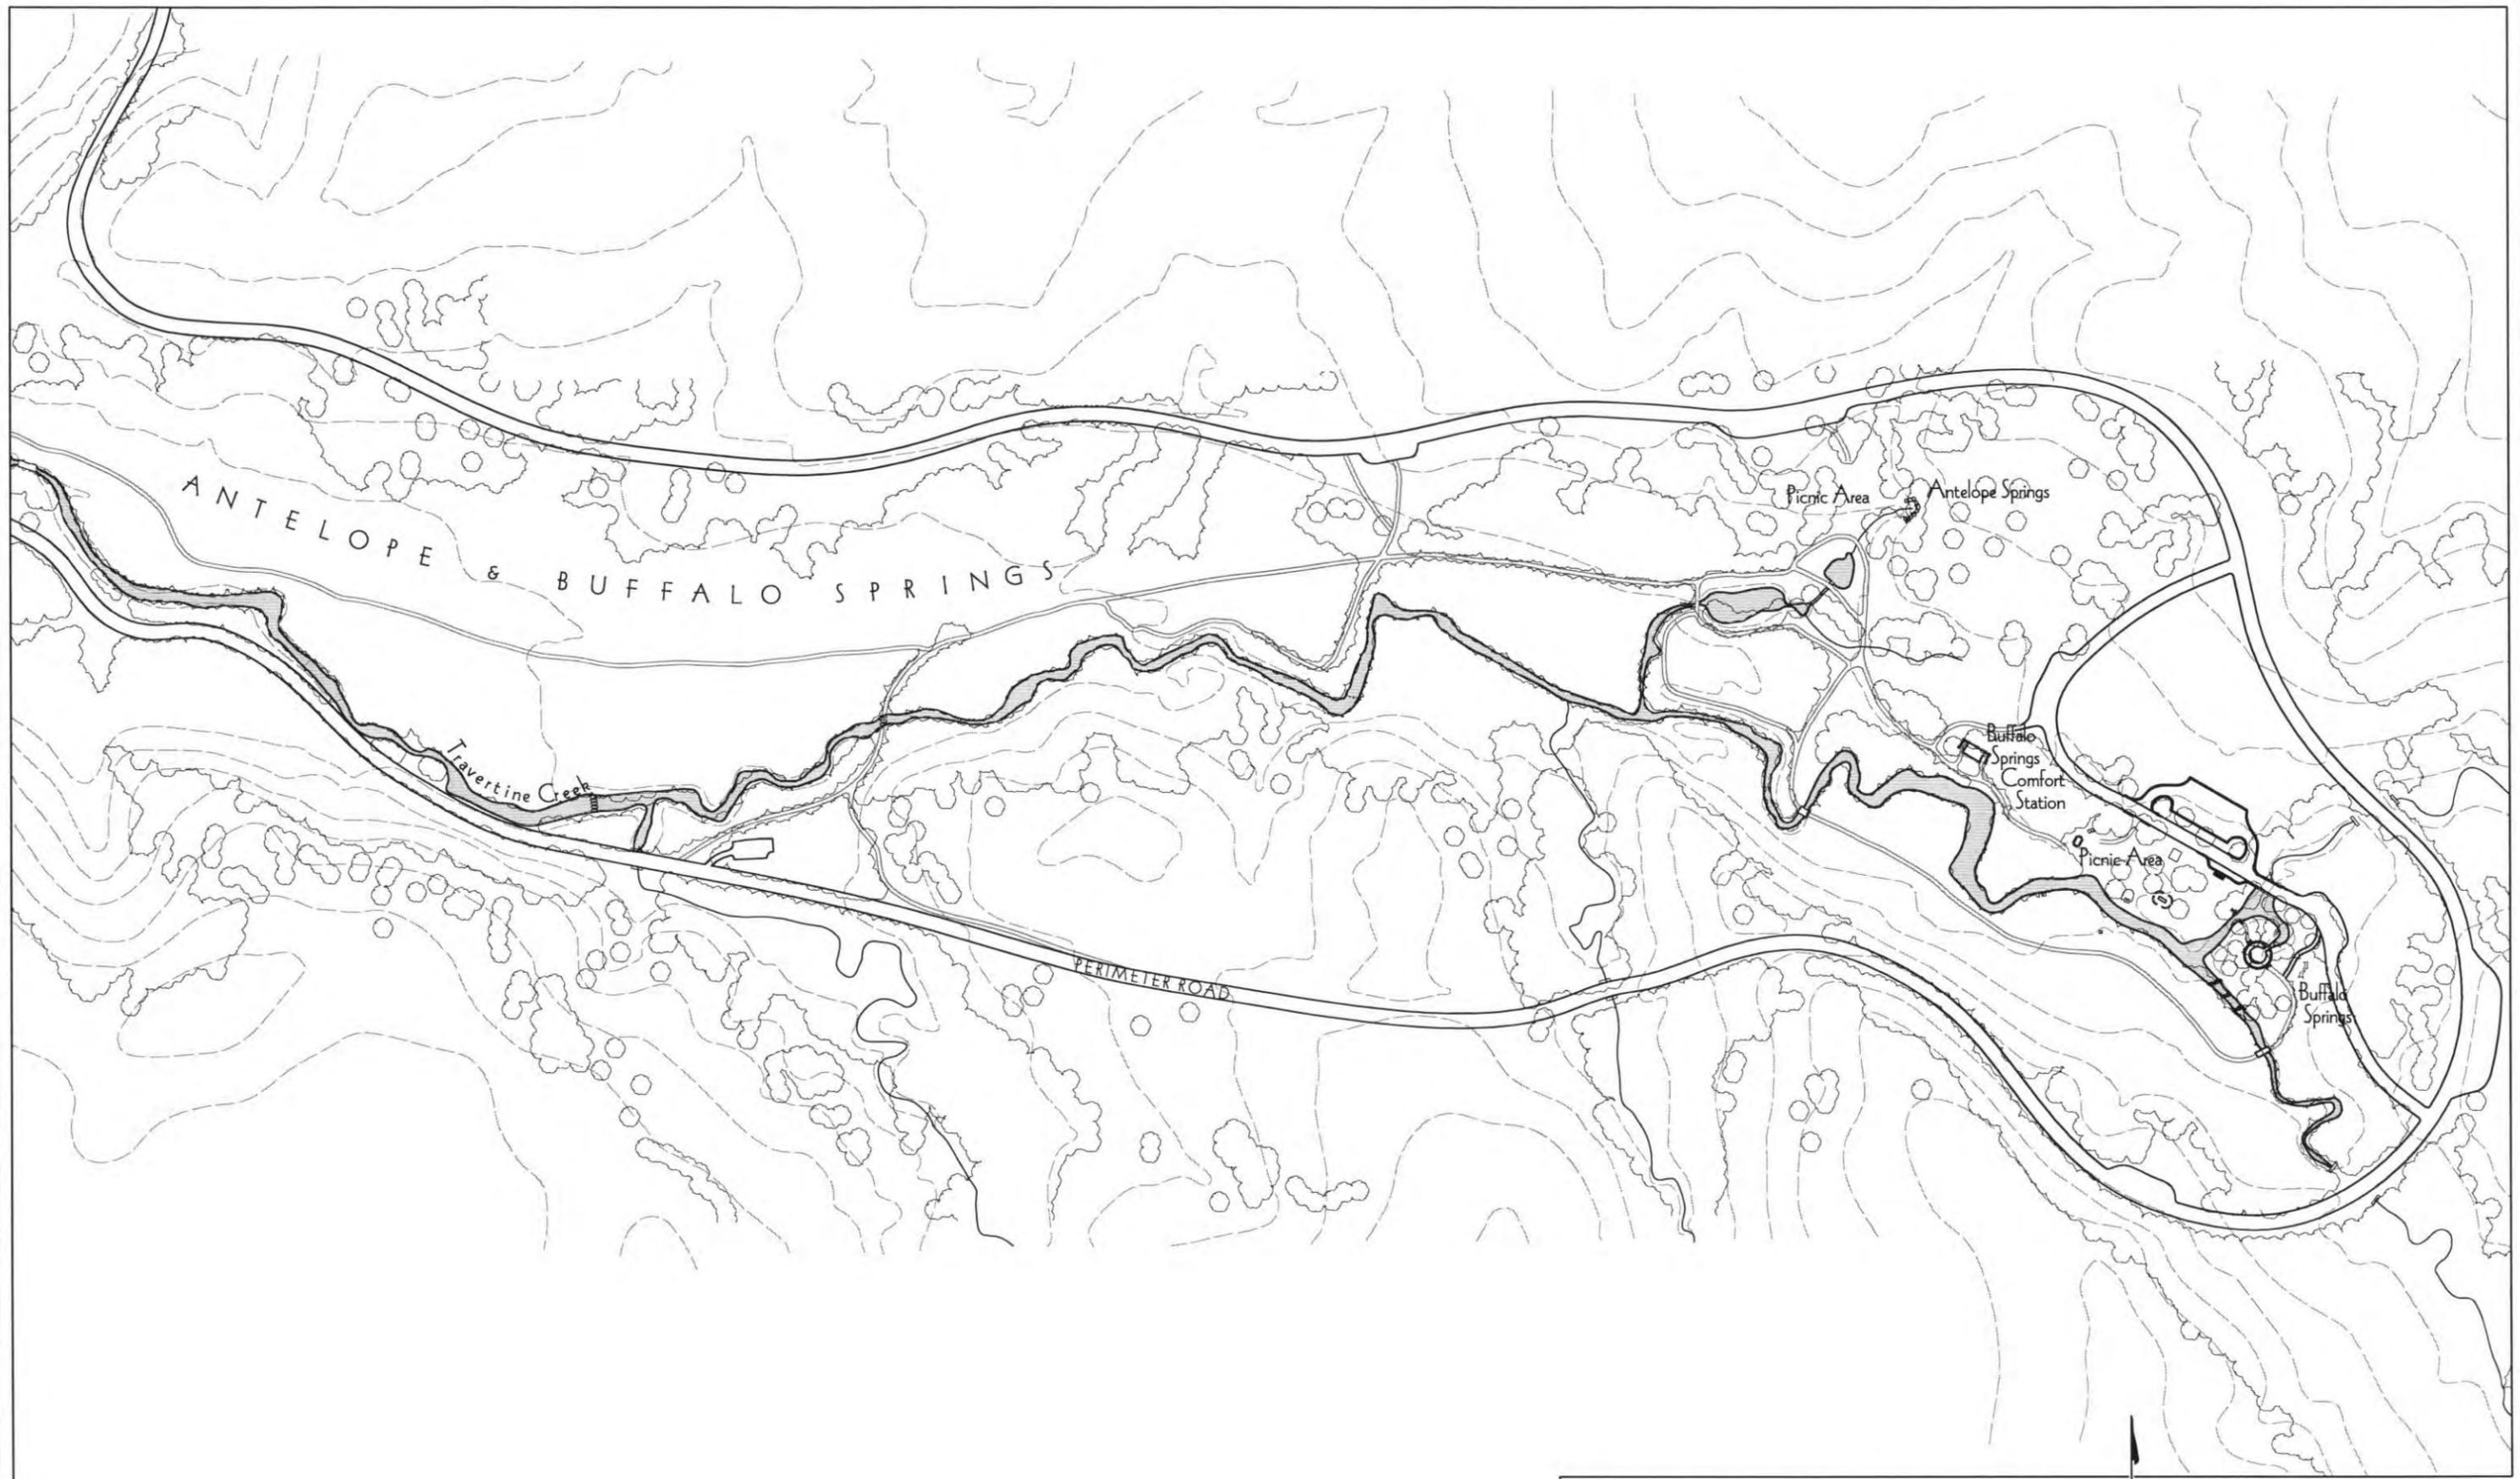

PLATT DISTRICT
Chickasaw National Recreation Area
Cultural Landscape Report
Iowa State University, Landscape Architecture Department
Date 10/7/02

1940 PERIOD PLAN
Antelope Springs & Buffalo Springs
Drawing II


scale 1" = 250'

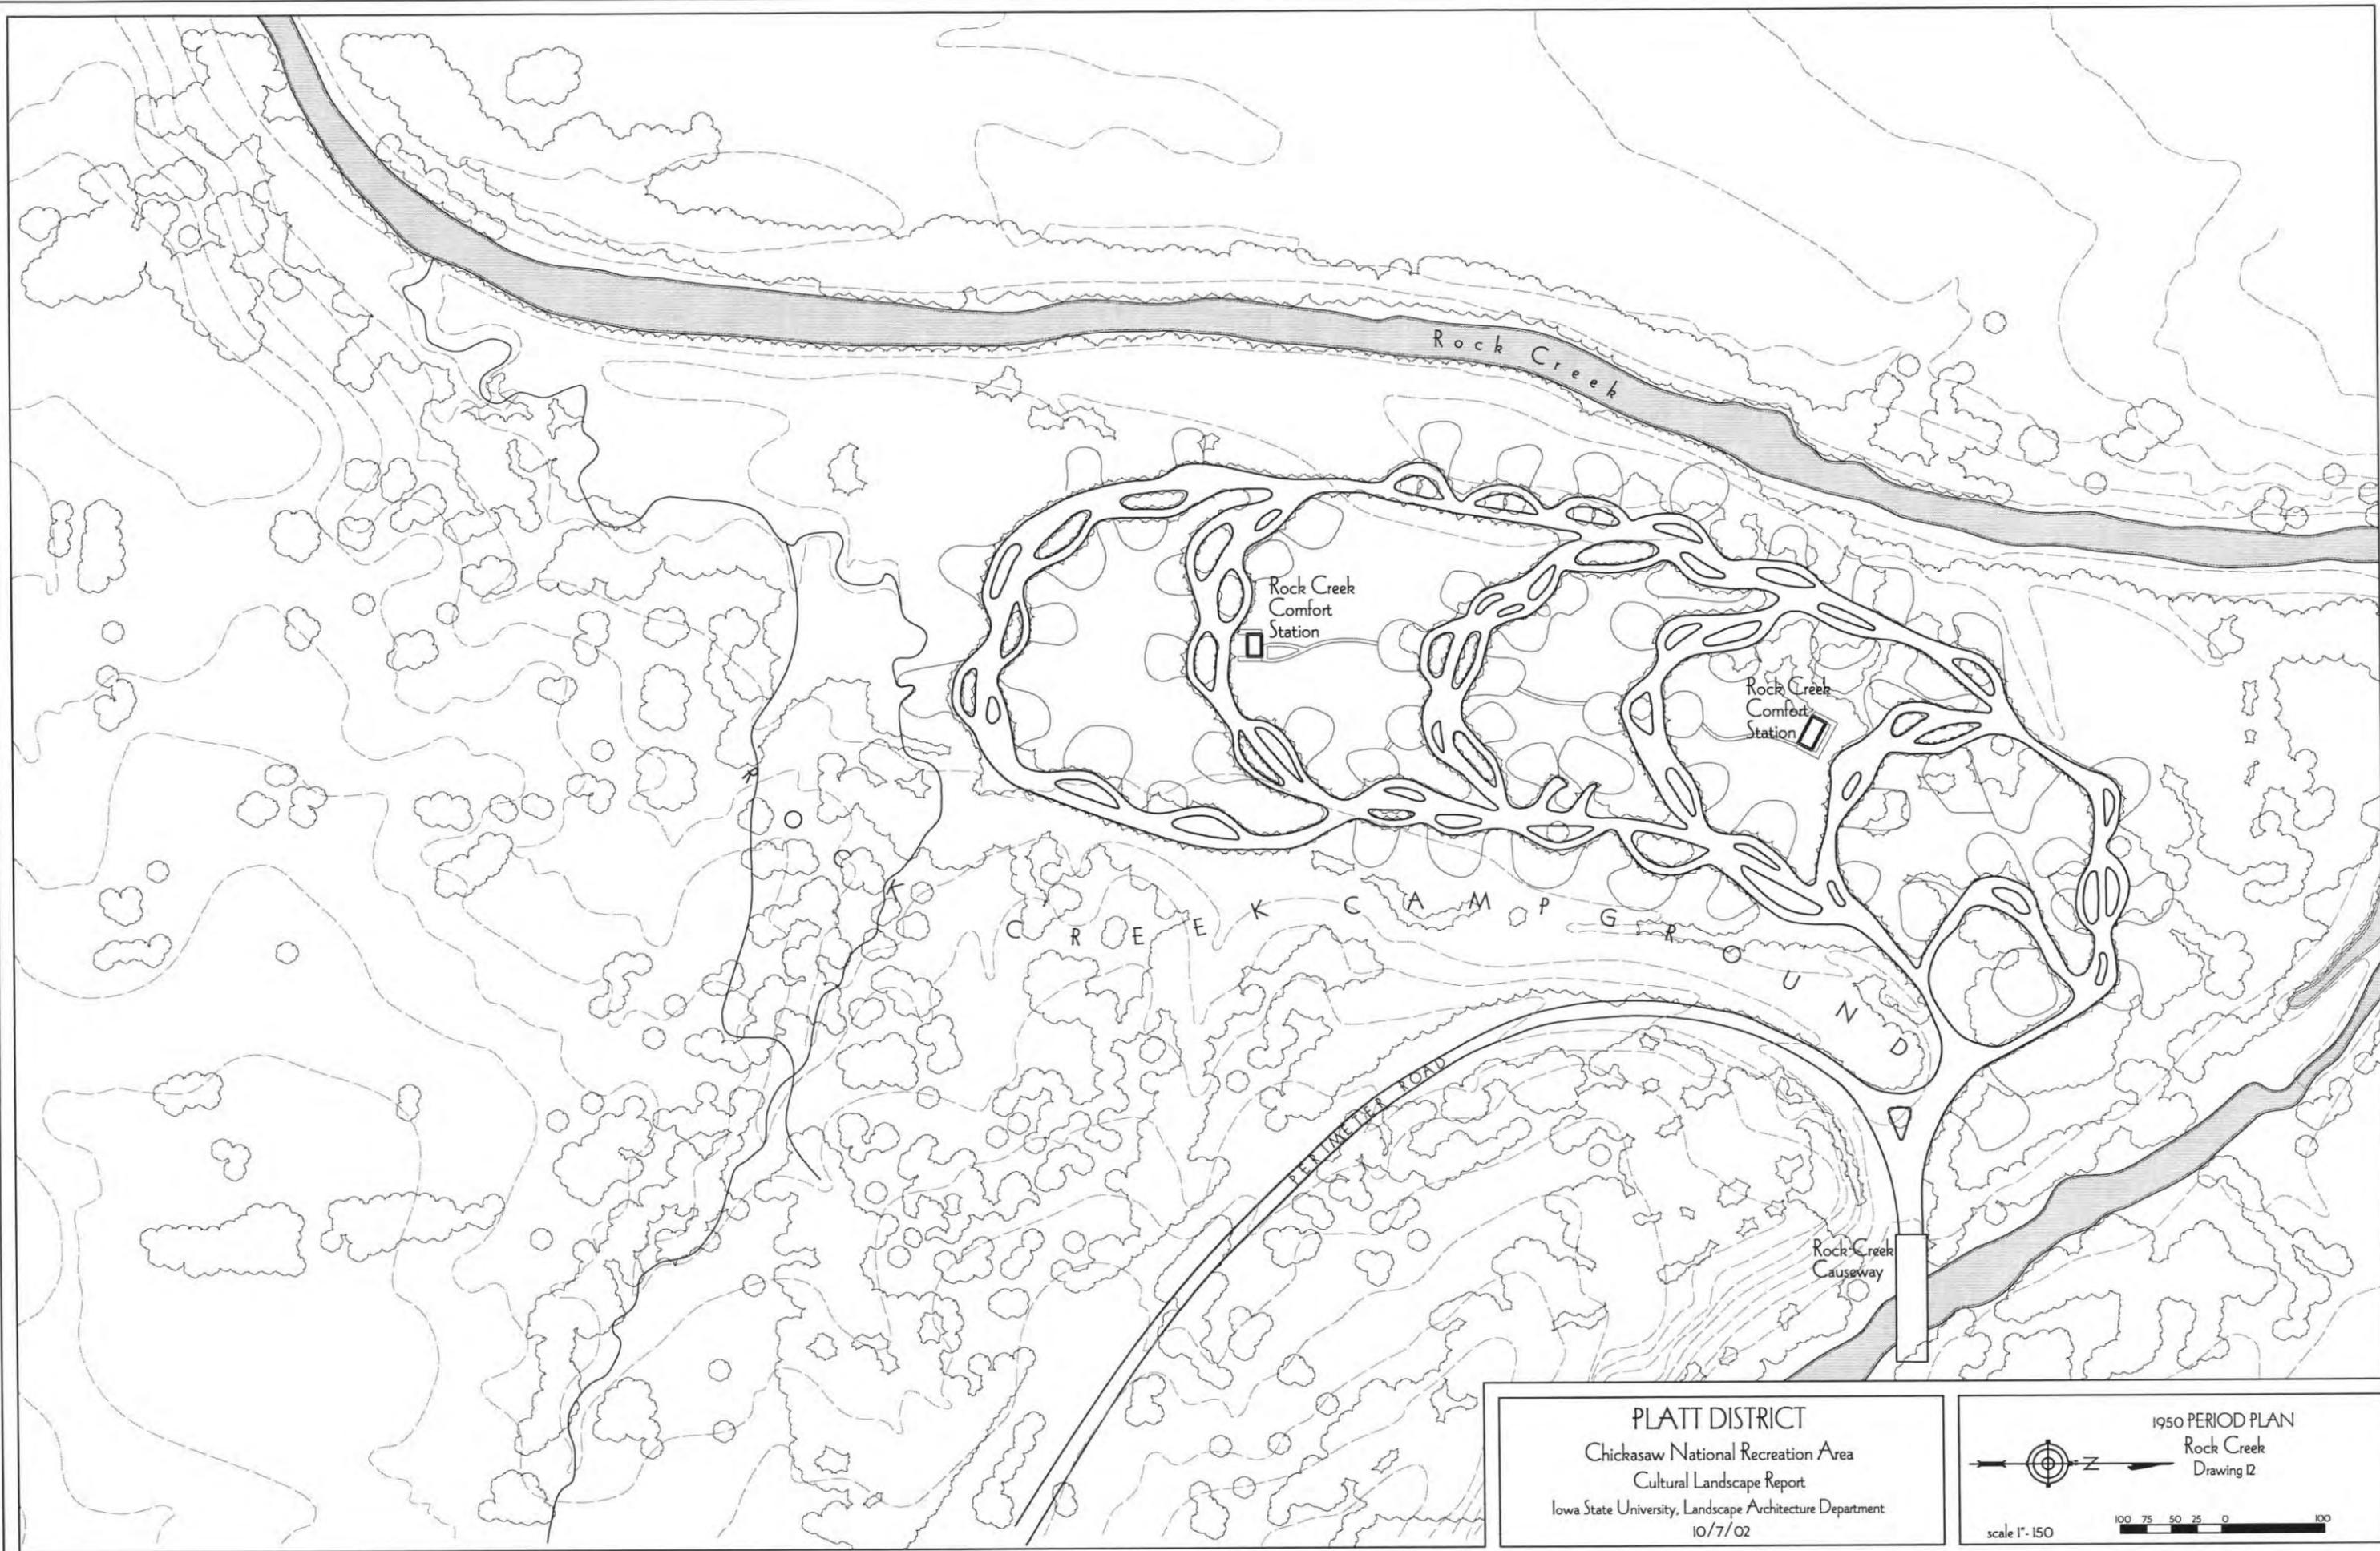


PLATT DISTRICT
Chickasaw National Recreation Area
Cultural Landscape Report
Iowa State University, Landscape Architecture Department
10/7/02

1950 PERIOD PLAN
Rock Creek
Drawing 12

scale 1" = 150'

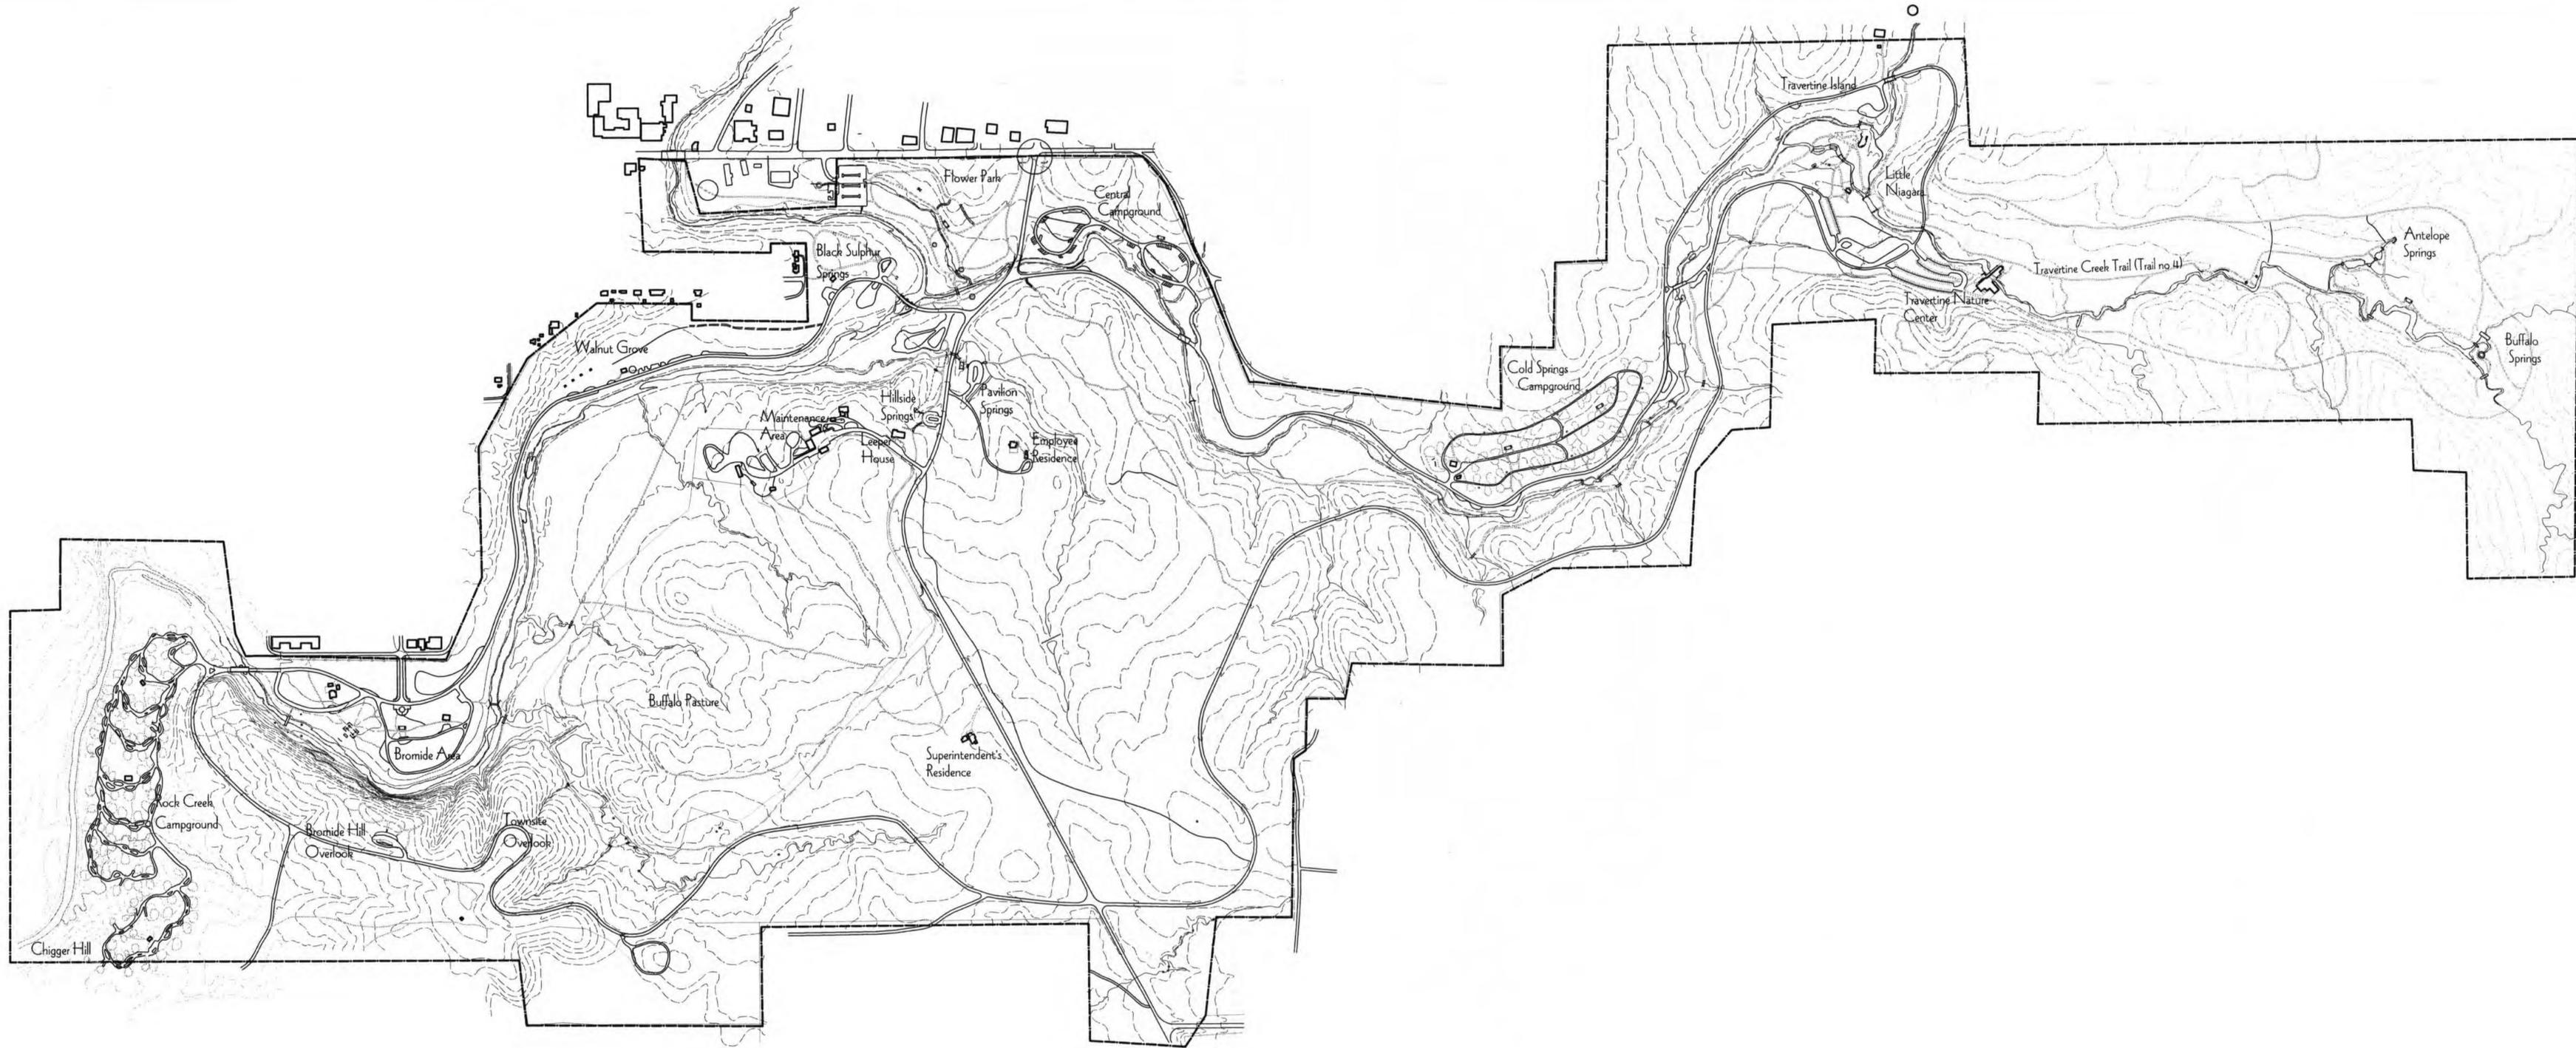


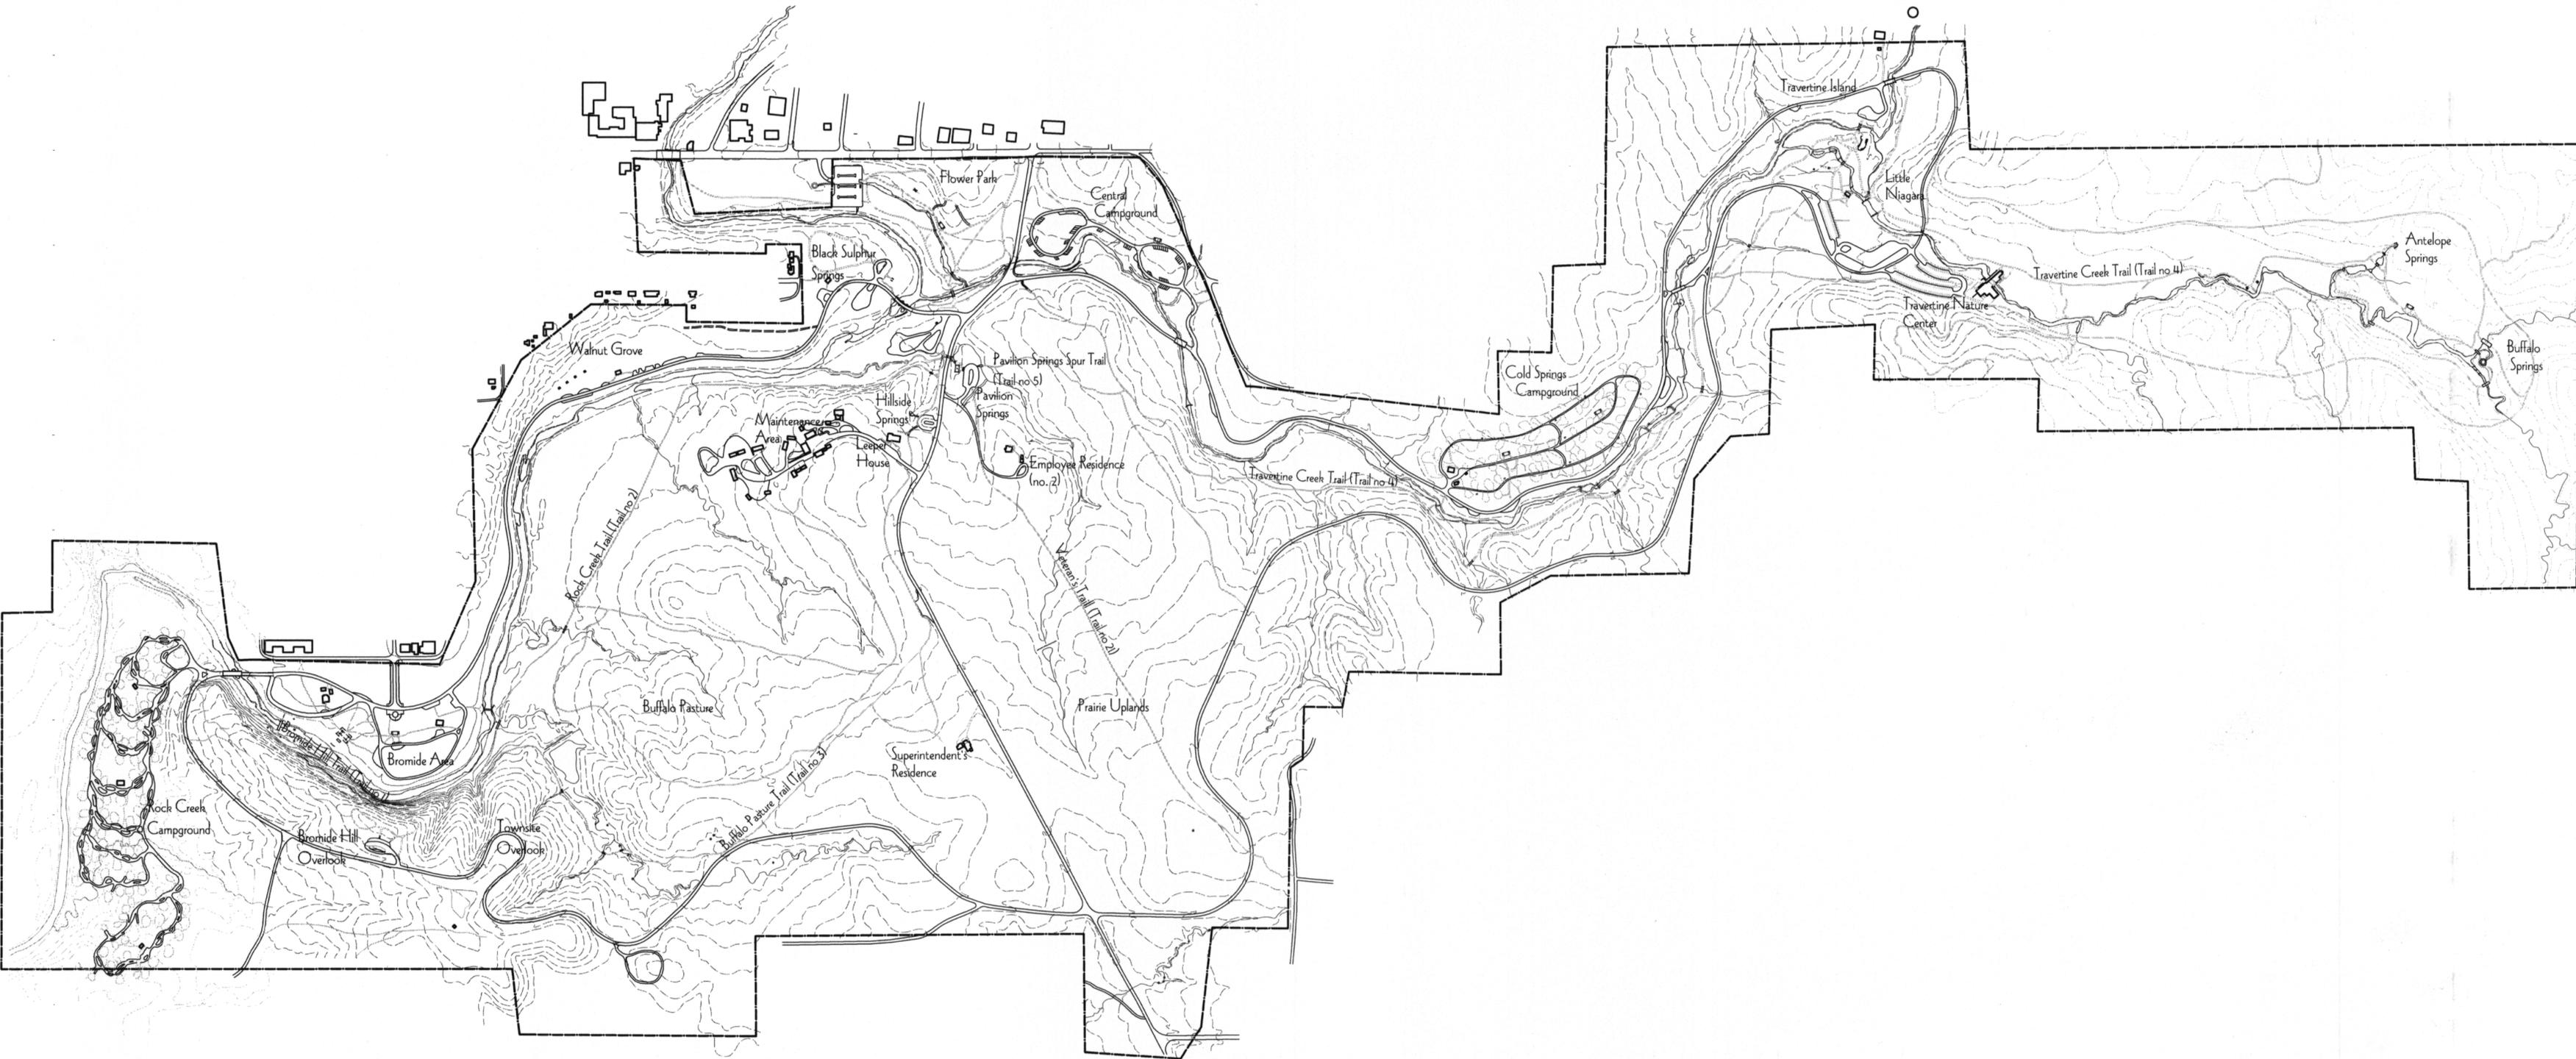

PLATT DISTRICT
 Chickasaw National Recreation Area
 Cultural Landscape Report
 Iowa State University, Landscape Architecture Department
 Date 10/7/02

EXISTING CONDITIONS
 Platt District 2002
 Drawing 14


Scale 1" = 500'

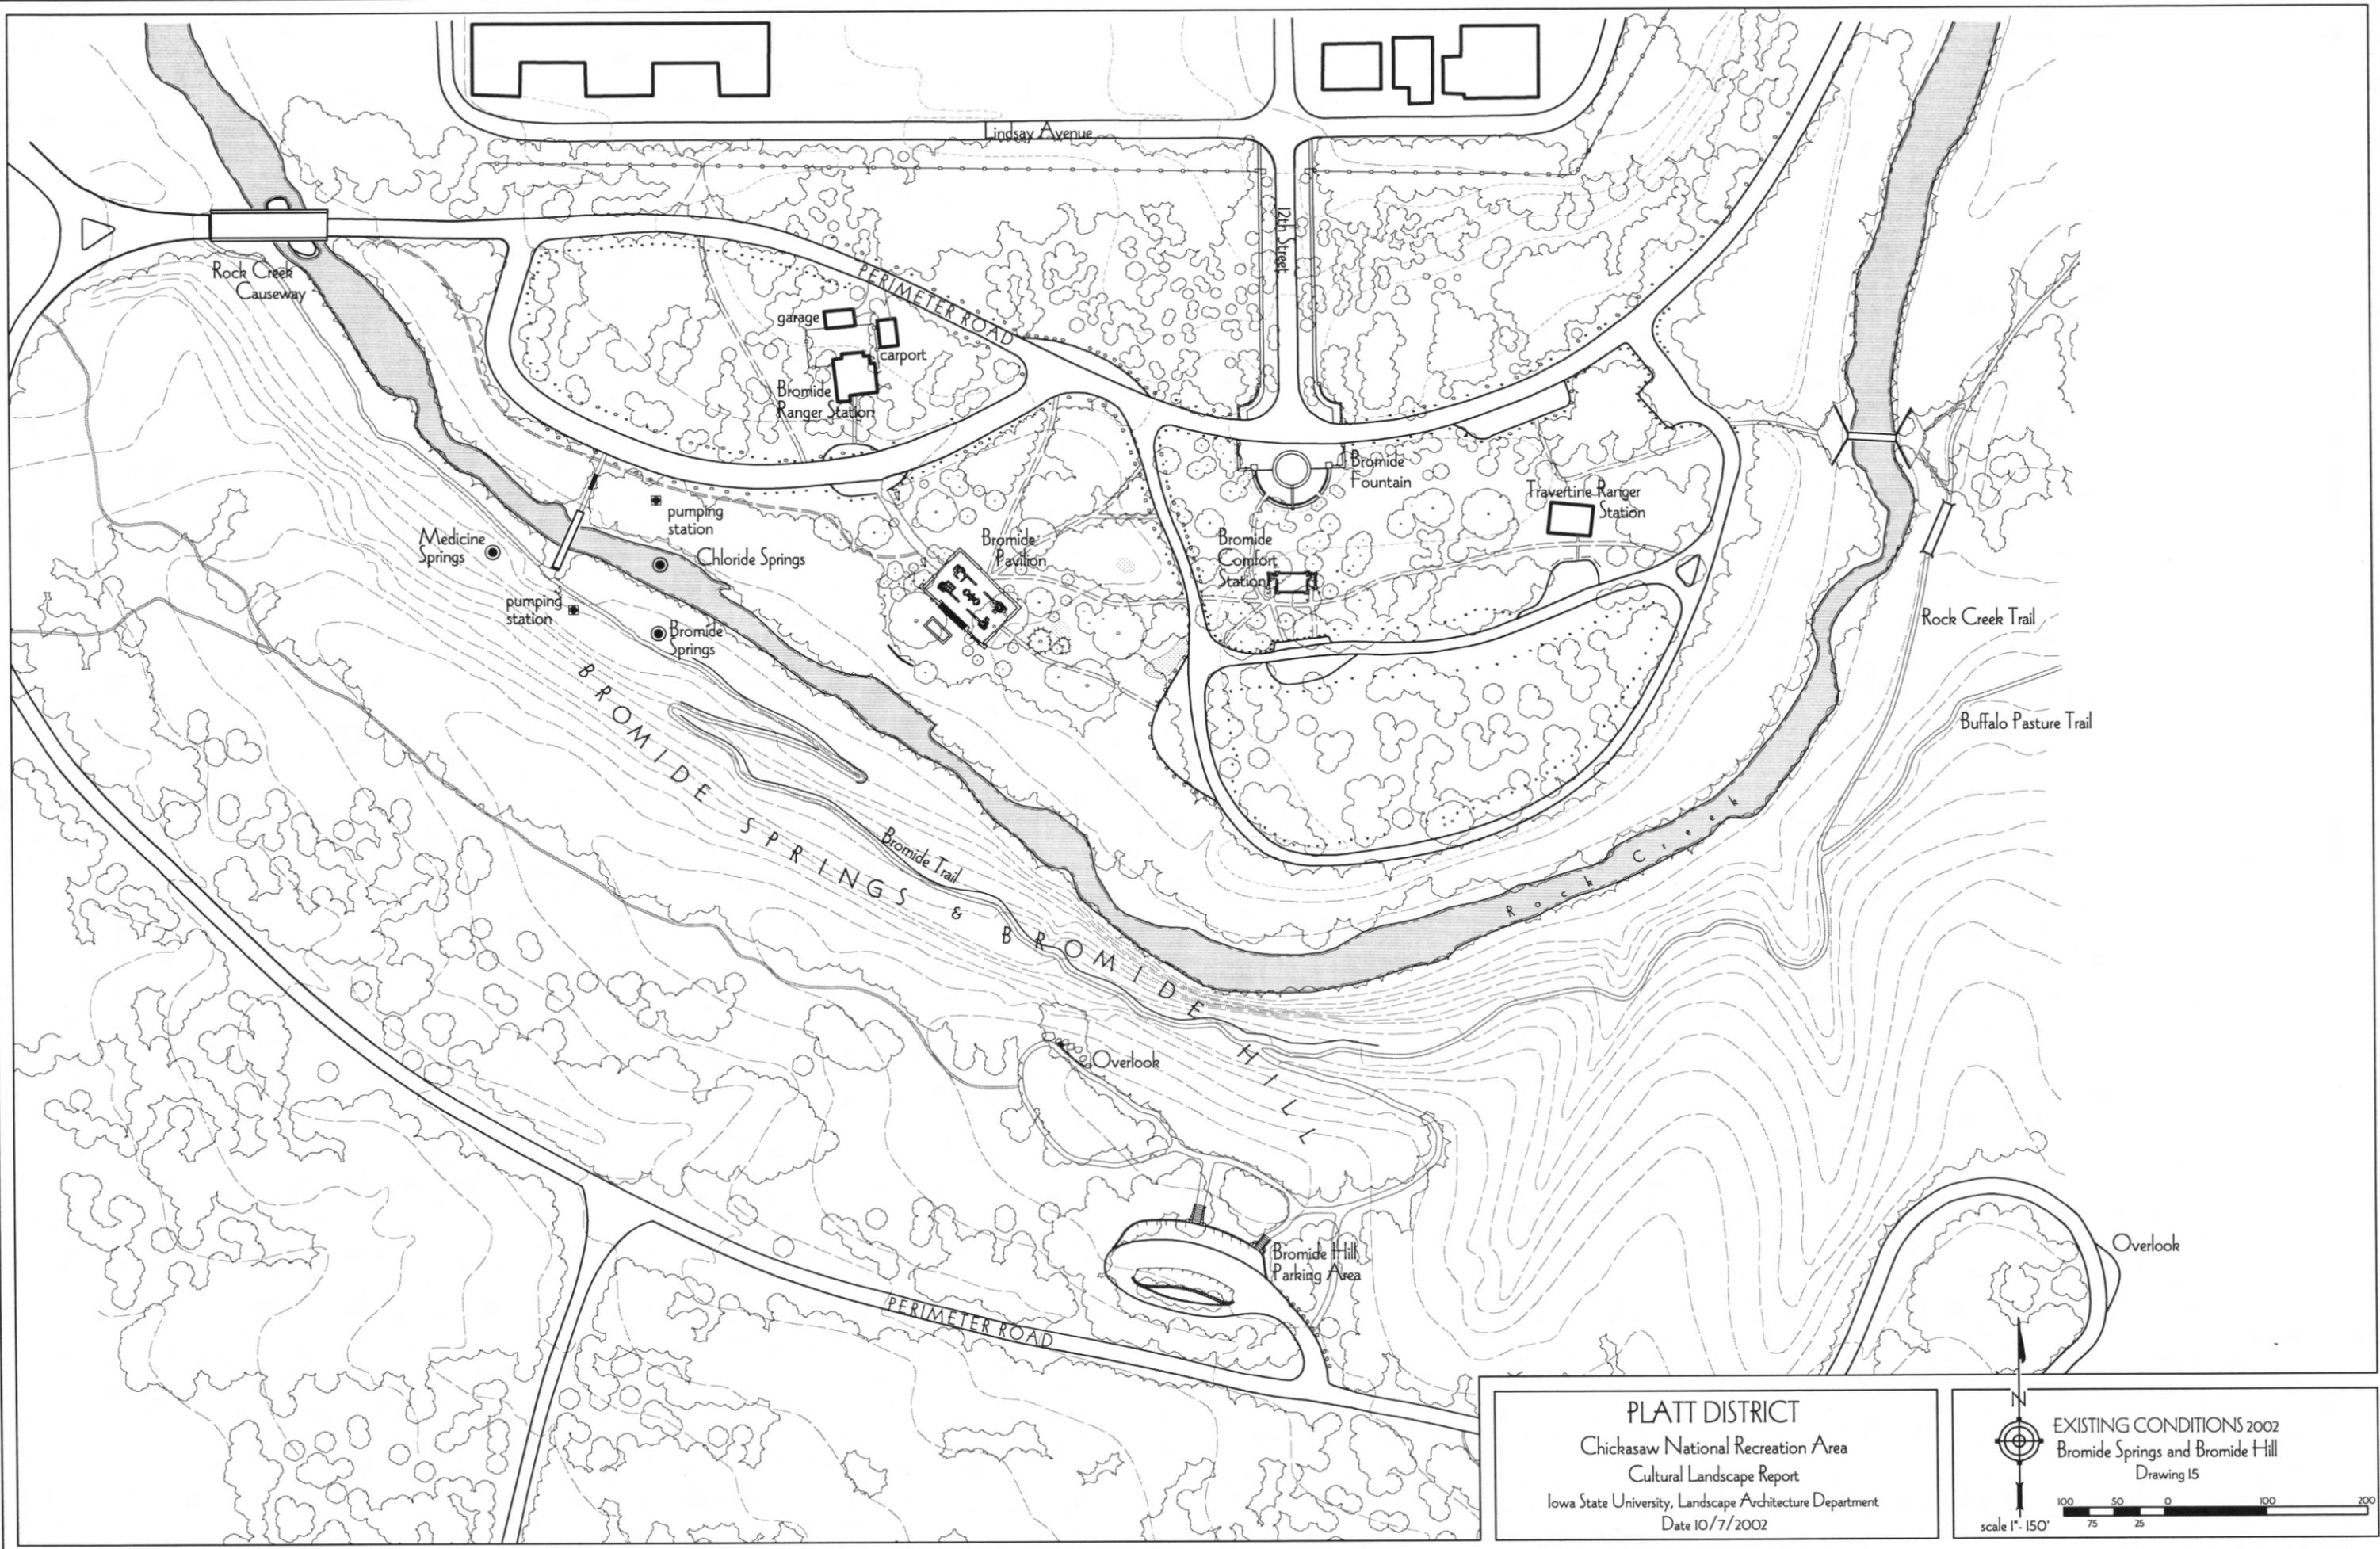

PLATT DISTRICT
 Chickasaw National Recreation Area
 Cultural Landscape Report
 Iowa State University, Landscape Architecture Department
 Date 10/7/2002

EXISTING CONDITIONS 2002
 Bromide Springs and Bromide Hill
 Drawing 15

scale 1" = 150'

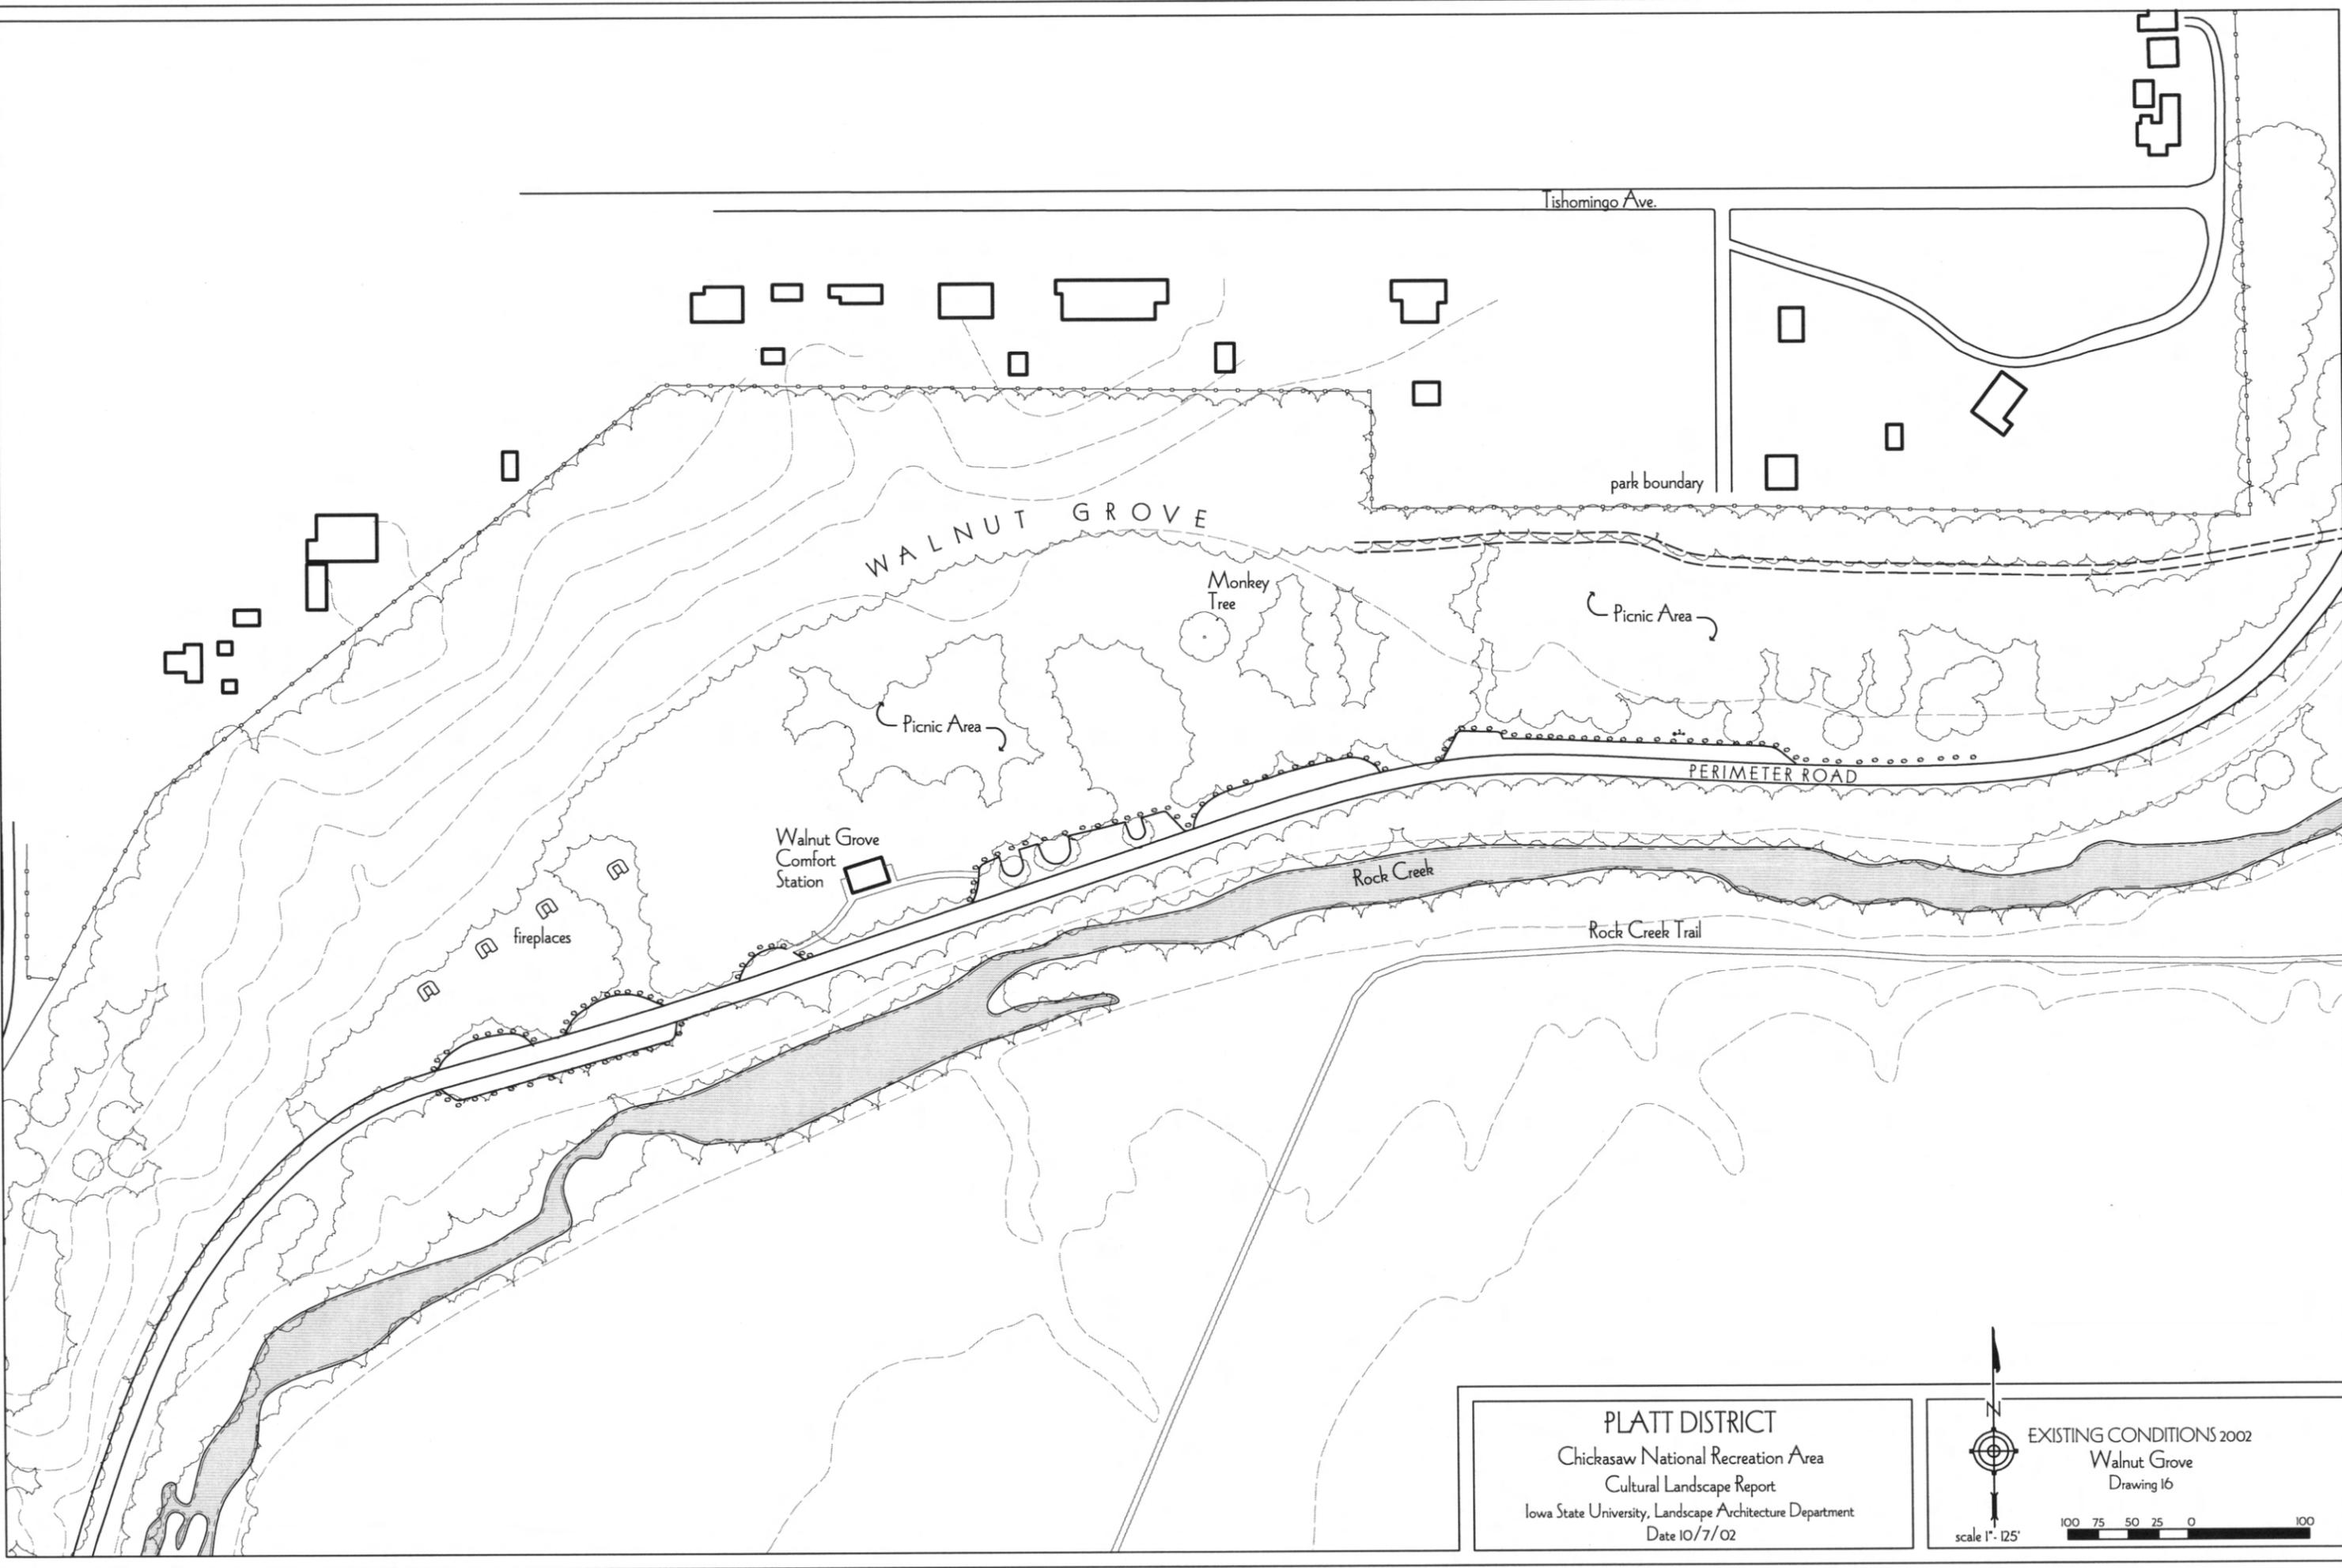

PLATT DISTRICT
 Chickasaw National Recreation Area
 Cultural Landscape Report
 Iowa State University, Landscape Architecture Department
 Date 10/7/02

EXISTING CONDITIONS 2002
 Walnut Grove
 Drawing 16

scale 1" = 125'

The block contains a north arrow pointing upwards and a graphic scale bar with markings at 100, 75, 50, 25, 0, and 100 feet.

Broadway Avenue

Main Entrance Piers

US 171 / Buckhorn Road

Vendome Well
New well and manhole

Vendome Parking Area

Upper Wading Pool

F
L
O
W
E
R
P
A
R
K

Flower Park Comfort Station

Rock Creek

Lower Wading Pool

Travertine Creek

Travertine Creek Bridge

Picnic Area

Pumping Station

Black Sulphur Springs Comfort Station

Black Sulphur Springs Pavilion

Black Sulphur Springs Causeway

Lincoln Bridge


Picnic Area

PERIMETER ROAD

PLATT DISTRICT
 Chickasaw National Recreation Area
 Cultural Landscape Report
 Iowa State University, Landscape Architecture Department
 10/7/02




EXISTING CONDITIONS 2002
 FLOWER PARK
 Drawing 17

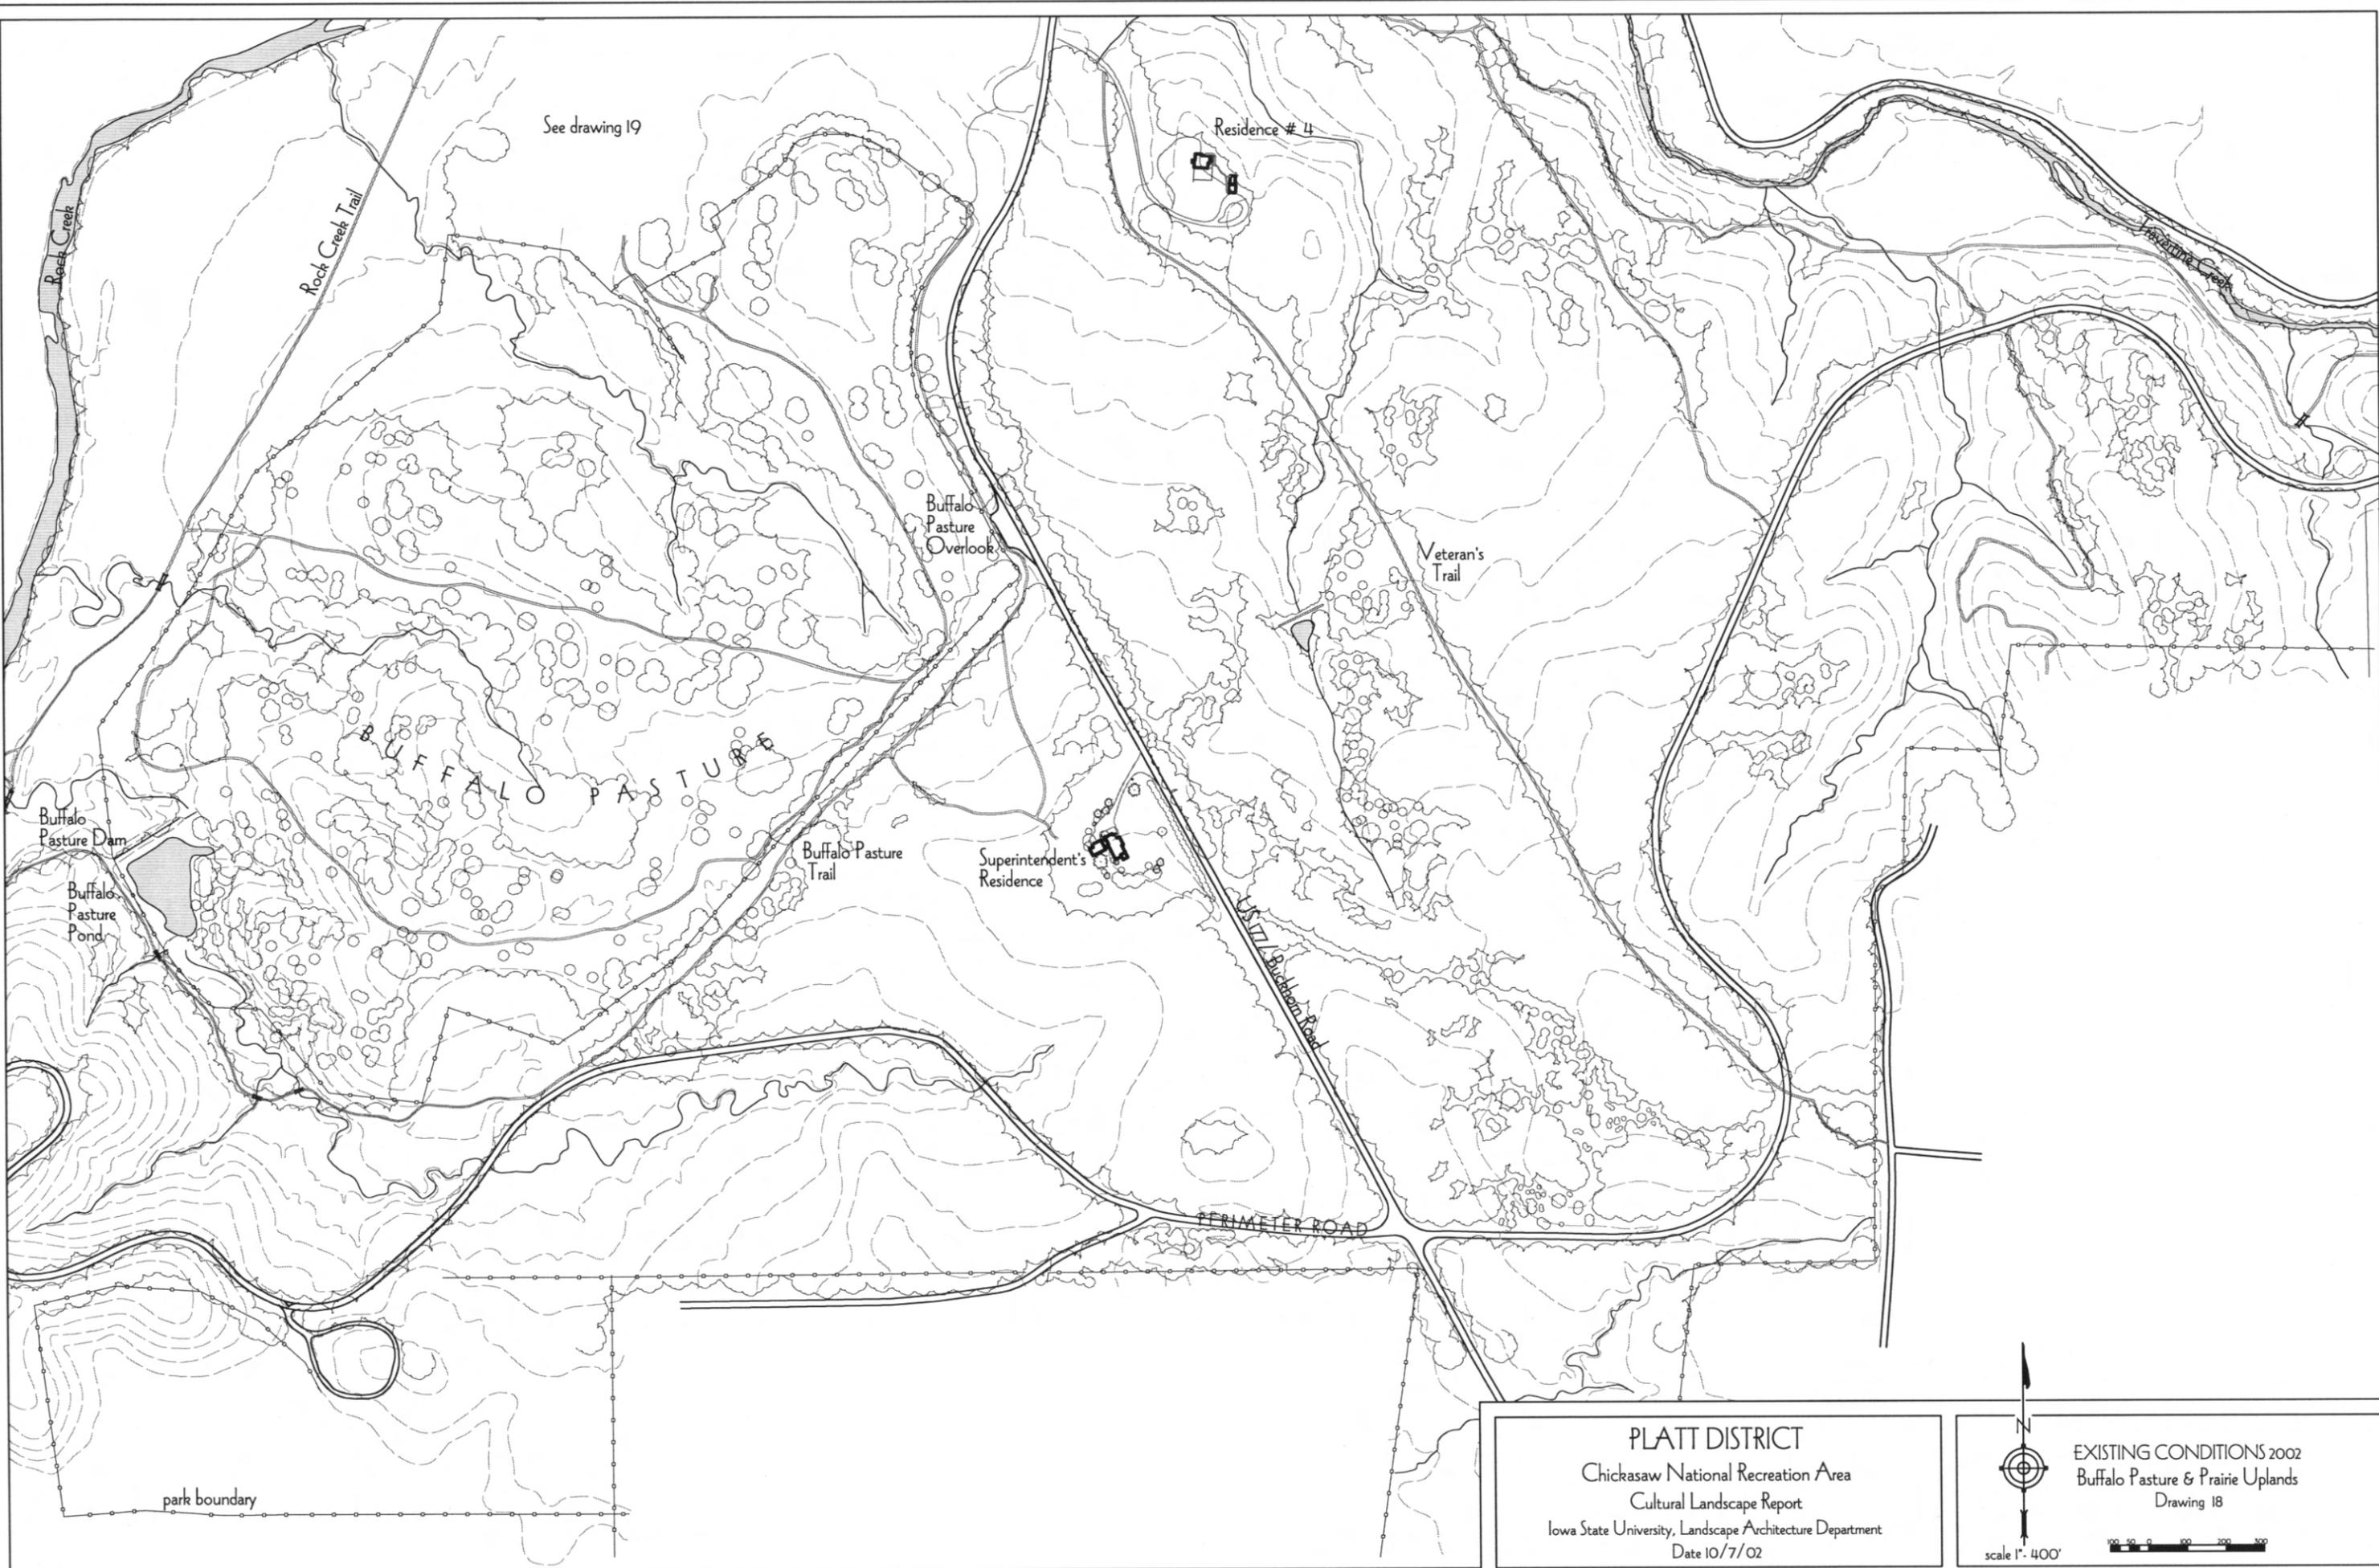


PLATT DISTRICT
Chickasaw National Recreation Area
Cultural Landscape Report
Iowa State University, Landscape Architecture Department
Date 10/7/02

EXISTING CONDITIONS 2002
Buffalo Pasture & Prairie Uplands
Drawing 18

scale 1" = 400'

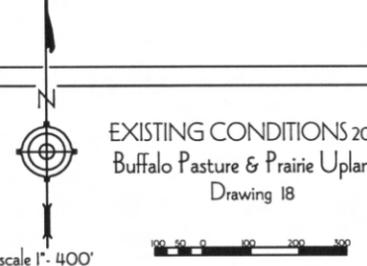

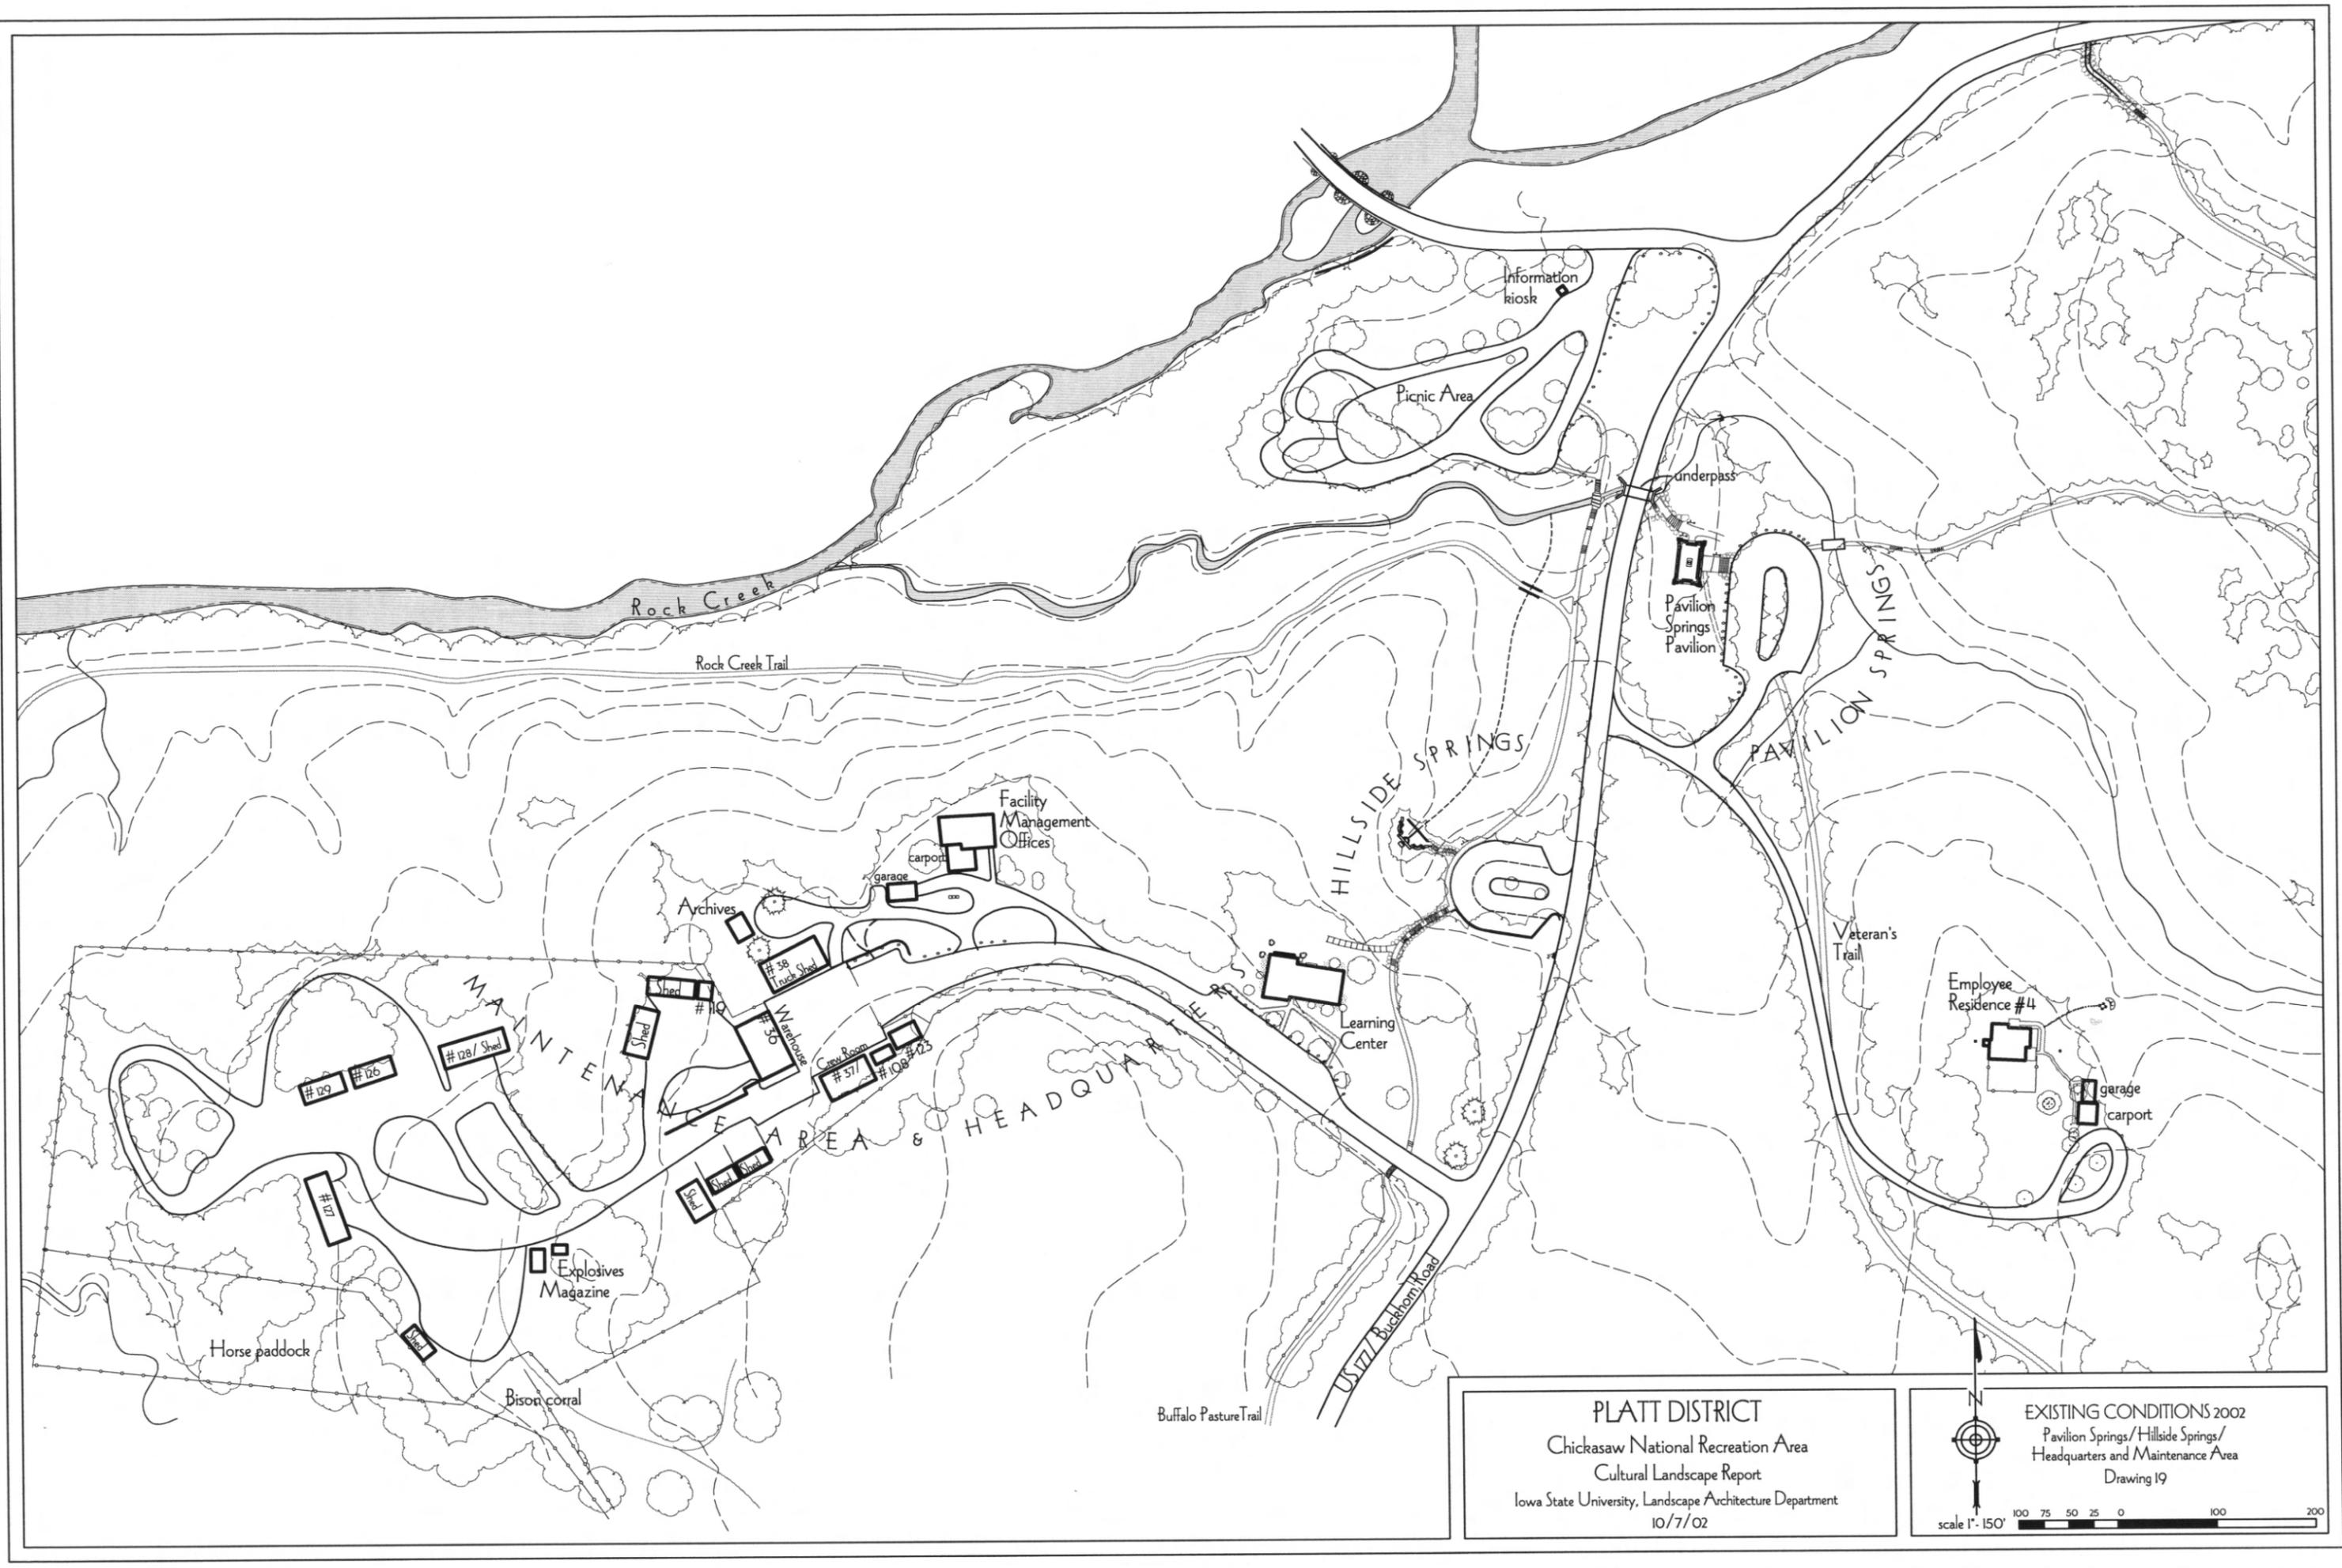

PLATT DISTRICT
 Chickasaw National Recreation Area
 Cultural Landscape Report
 Iowa State University, Landscape Architecture Department
 10/7/02


EXISTING CONDITIONS 2002
 Pavilion Springs/Hillside Springs/
 Headquarters and Maintenance Area
 Drawing 19


scale 1" = 150'

100 75 50 25 0 100 200



PLATT DISTRICT
 Chickasaw National Recreation Area
 Cultural Landscape Report
 Iowa State University, Landscape Architecture Department
 Date 10/7/02

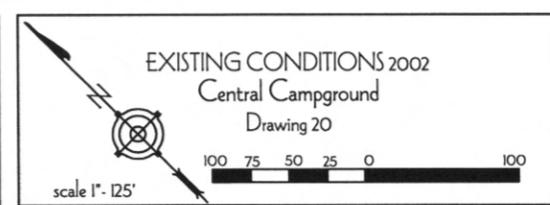

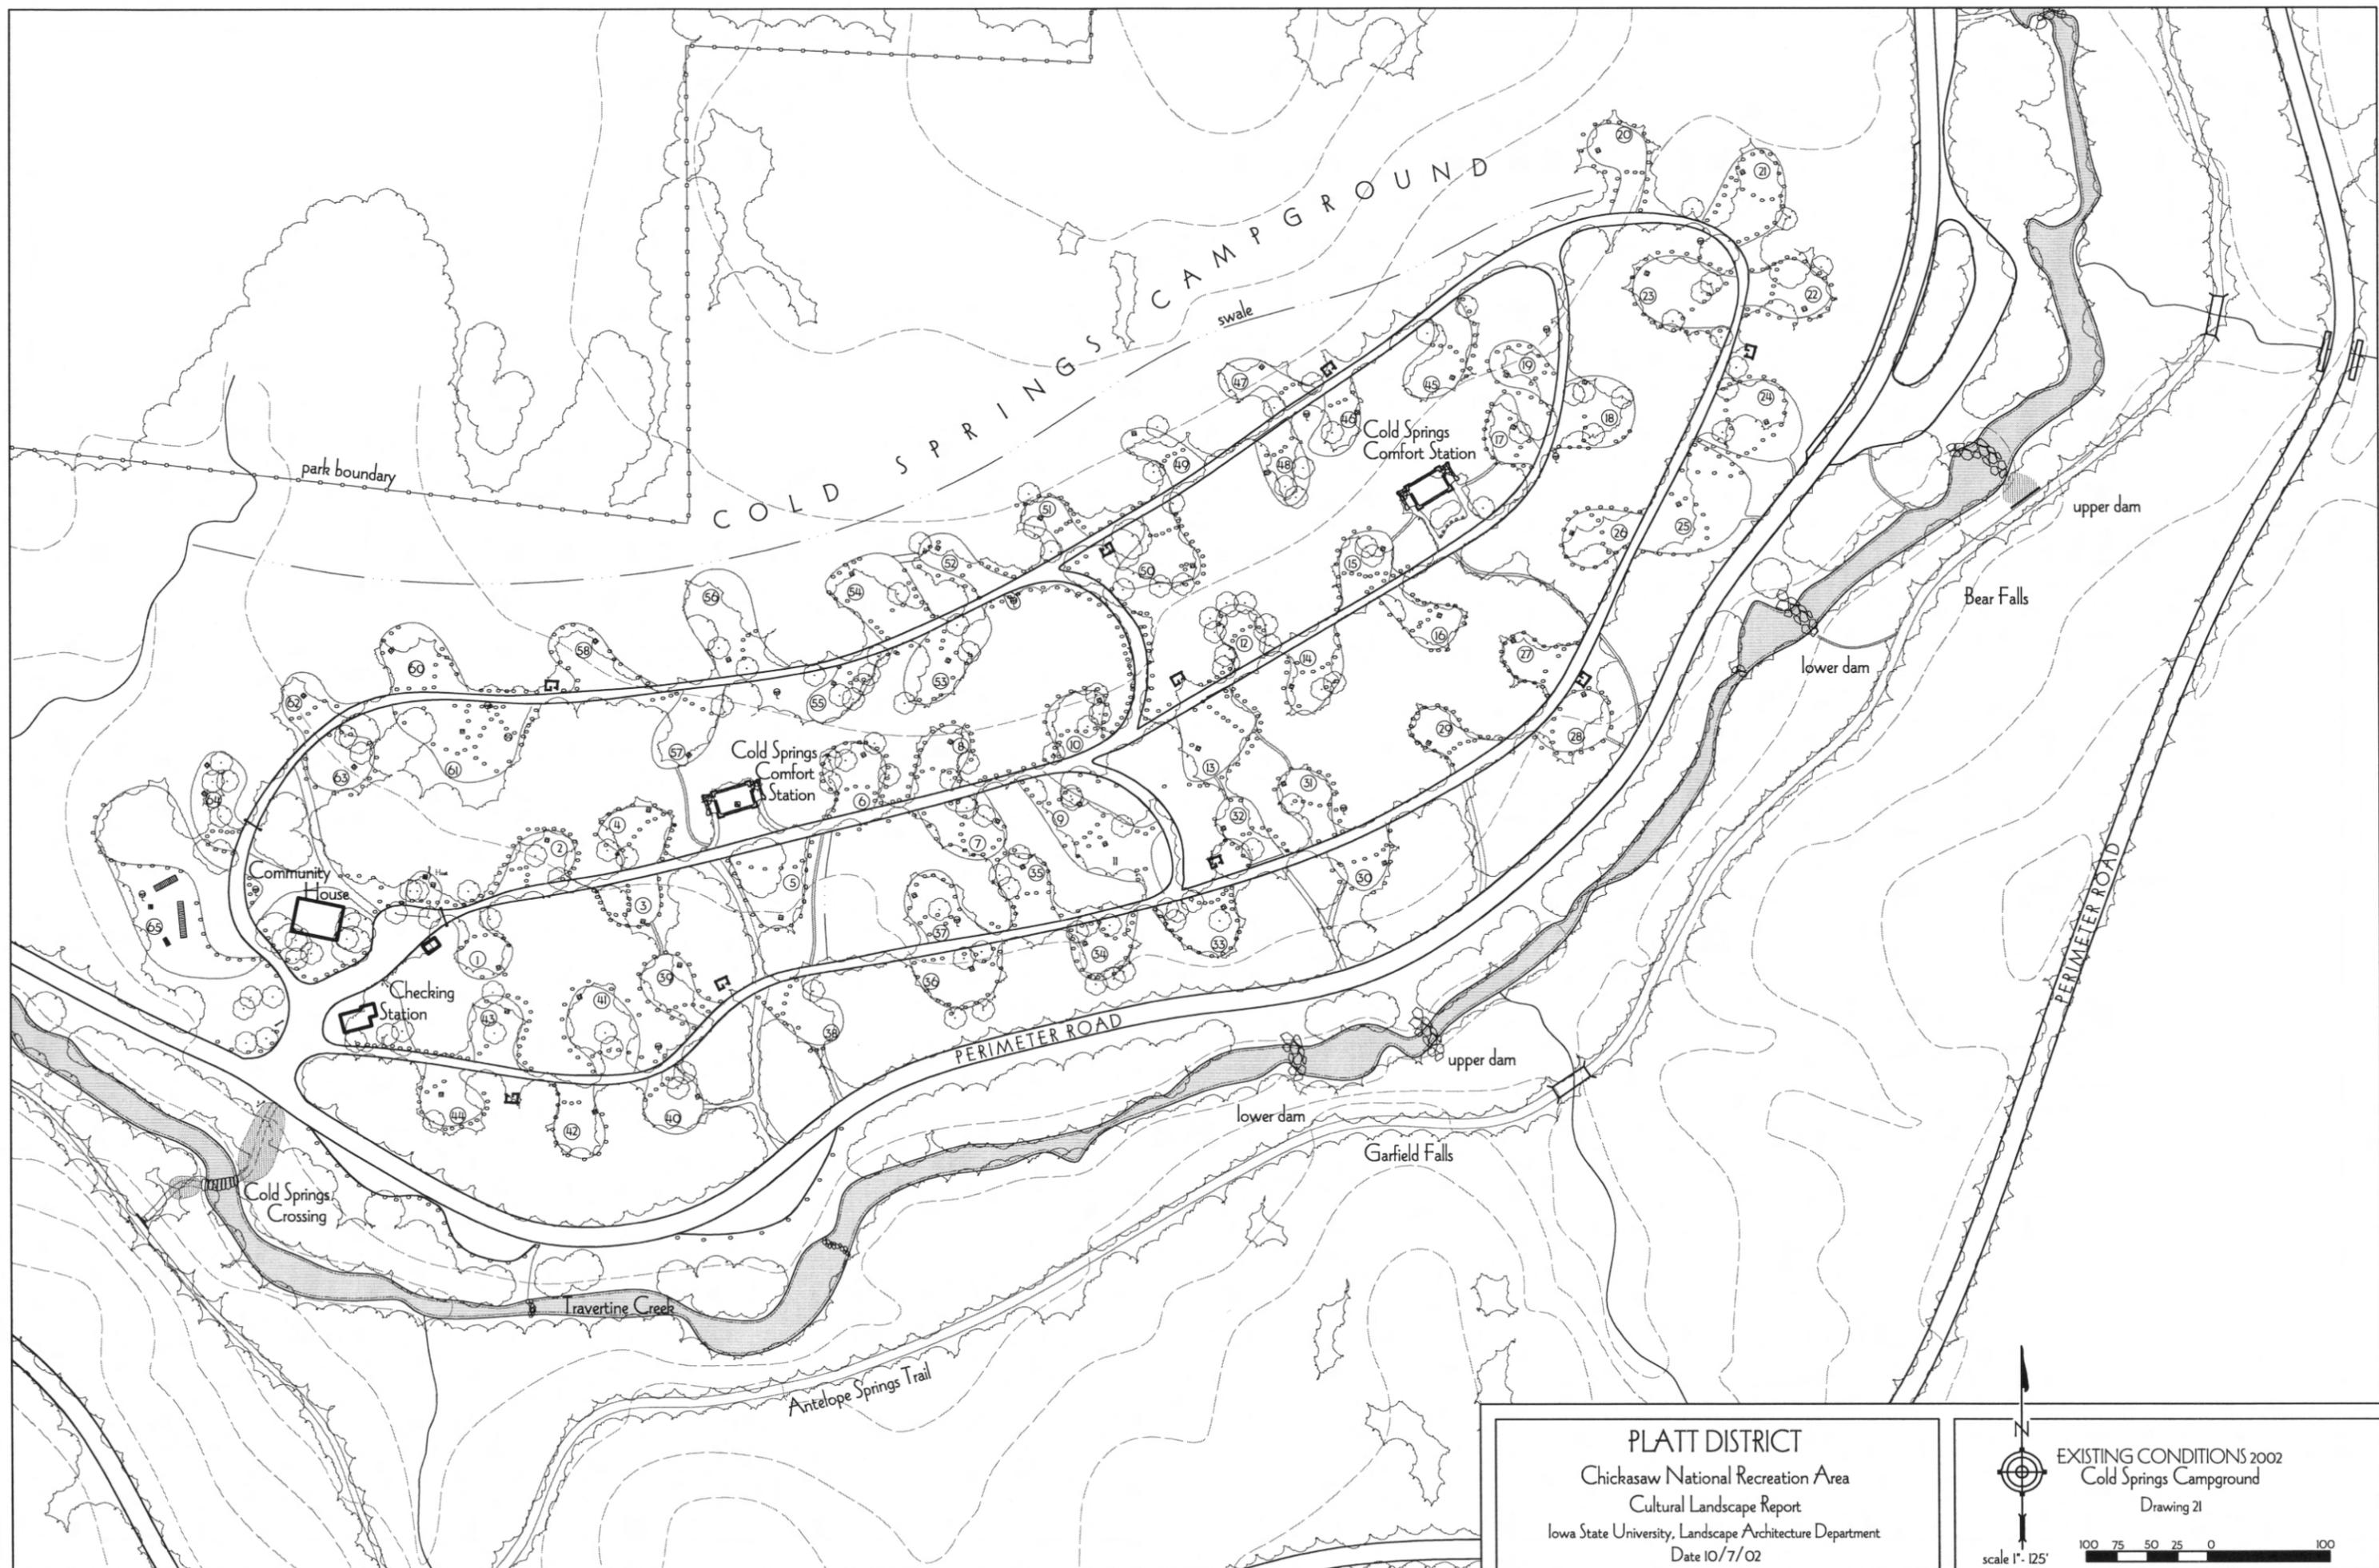


PLATT DISTRICT
 Chickasaw National Recreation Area
 Cultural Landscape Report
 Iowa State University, Landscape Architecture Department
 Date 10/7/02

EXISTING CONDITIONS 2002
 Cold Springs Campground
 Drawing 21

scale 1" = 125'

100 75 50 25 0 100

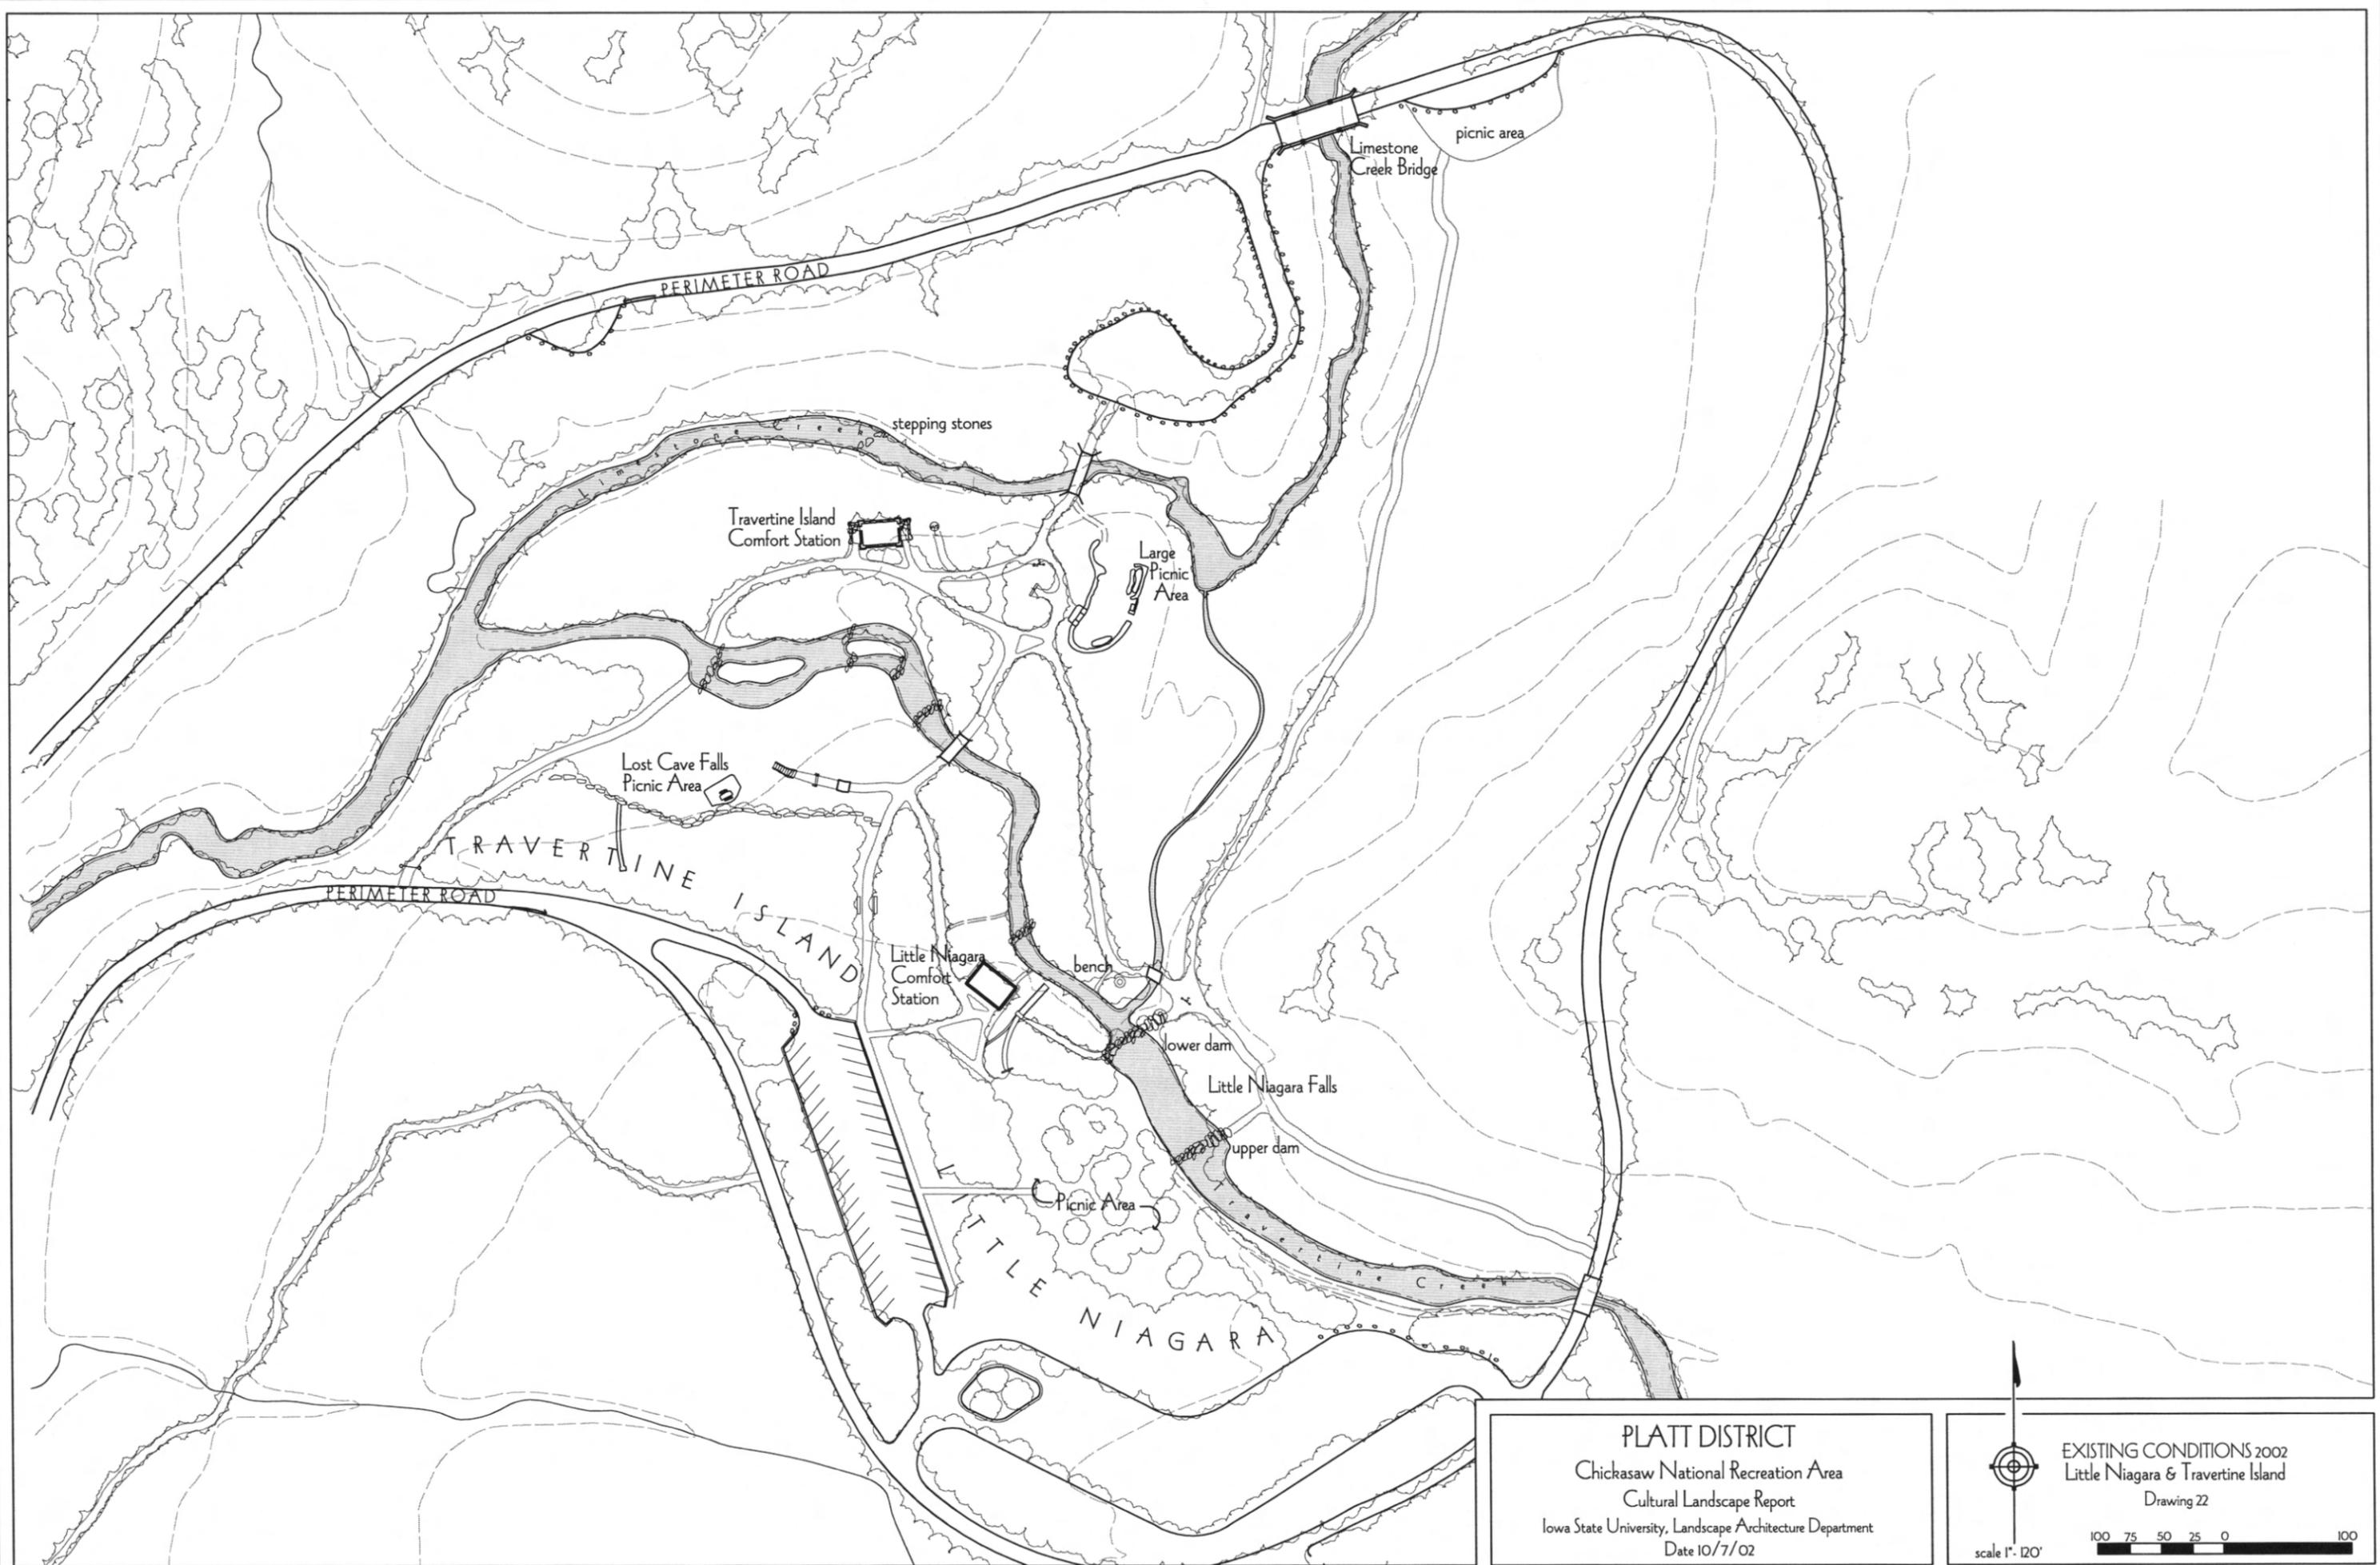

PLATT DISTRICT
 Chickasaw National Recreation Area
 Cultural Landscape Report
 Iowa State University, Landscape Architecture Department
 Date 10/7/02

EXISTING CONDITIONS 2002
 Little Niagara & Travertine Island
 Drawing 22

scale 1" = 120'




PLATT DISTRICT
 Chickasaw National Recreation Area
 Cultural Landscape Report
 Iowa State University, Landscape Architecture Department
 Date 10/7/02

EXISTING CONDITIONS 2002
 Antelope Springs & Buffalo Springs
 Drawing 23

scale 1" = 250'


A north arrow pointing upwards and a graphic scale bar are located in the bottom right corner of the map area.

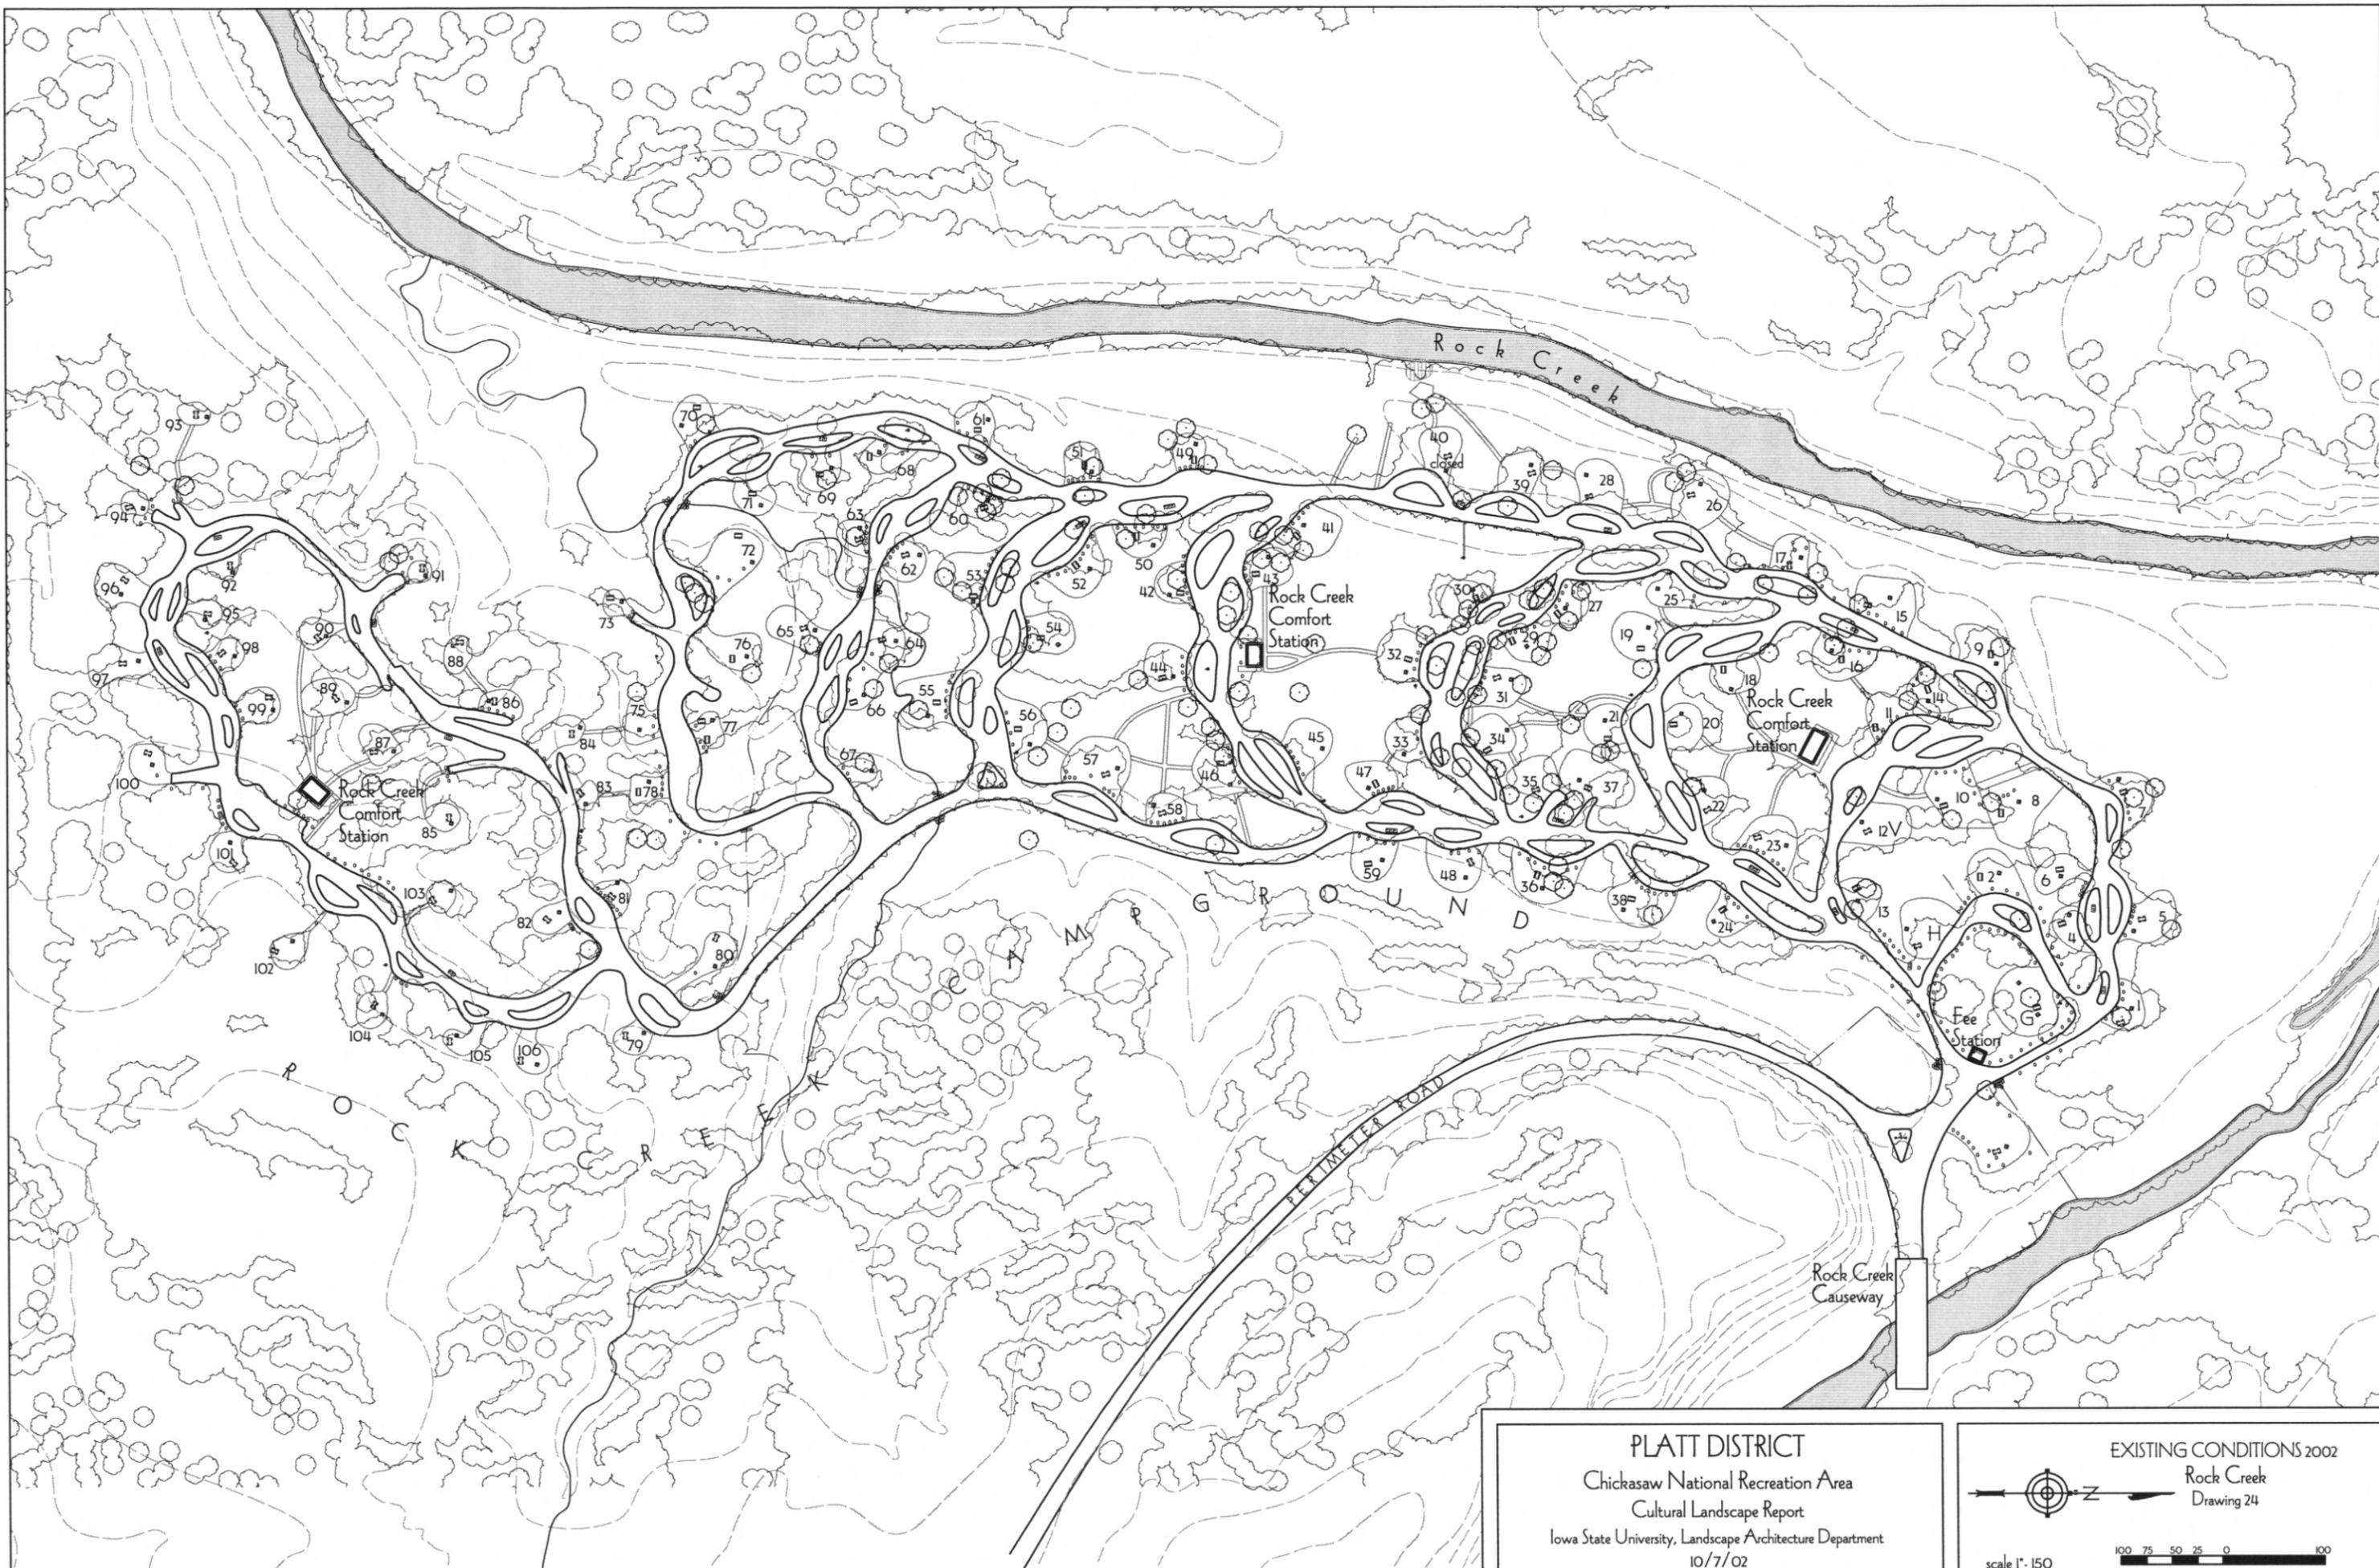

PLATT DISTRICT
 Chickasaw National Recreation Area
 Cultural Landscape Report
 Iowa State University, Landscape Architecture Department
 10/7/02

EXISTING CONDITIONS 2002
 Rock Creek
 Drawing 24

scale 1" = 150'

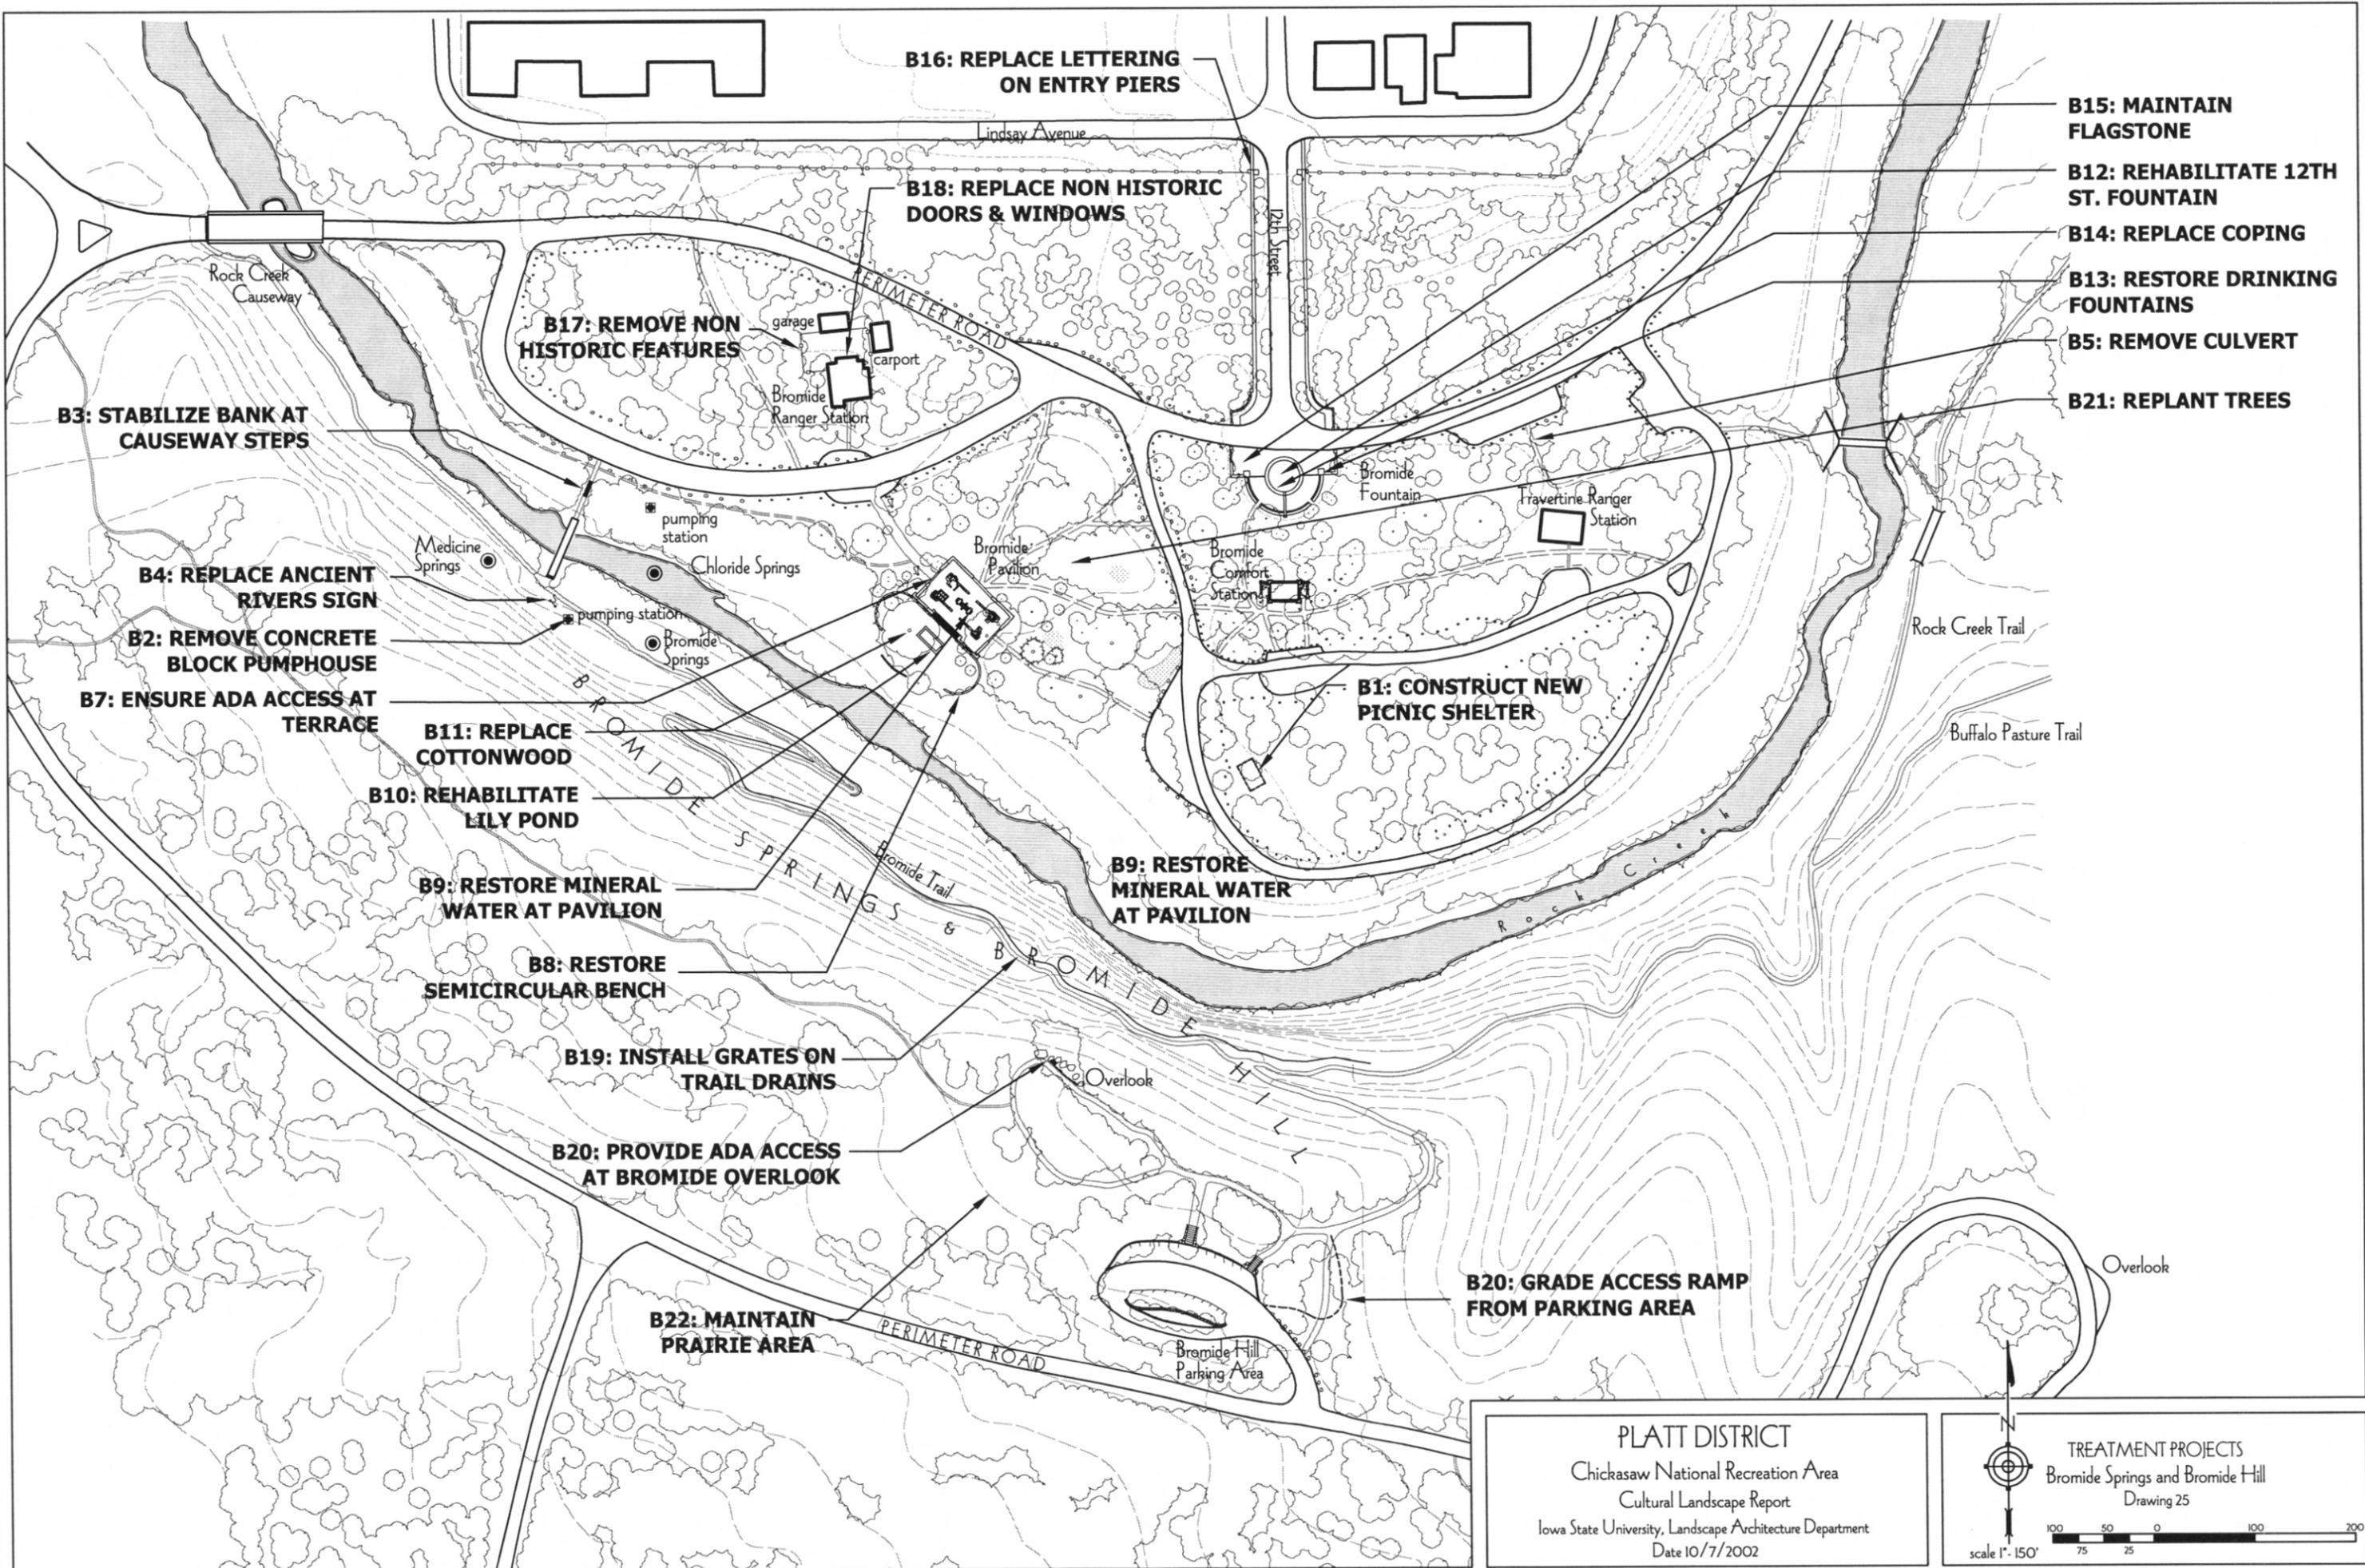

B16: REPLACE LETTERING ON ENTRY PIERS

B18: REPLACE NON HISTORIC DOORS & WINDOWS

B17: REMOVE NON HISTORIC FEATURES

B15: MAINTAIN FLAGSTONE

B12: REHABILITATE 12TH ST. FOUNTAIN

B14: REPLACE COPING

B13: RESTORE DRINKING FOUNTAINS

B5: REMOVE CULVERT

B21: REPLANT TREES

B3: STABILIZE BANK AT CAUSEWAY STEPS

B4: REPLACE ANCIENT RIVERS SIGN

B2: REMOVE CONCRETE BLOCK PUMPHOUSE

B7: ENSURE ADA ACCESS AT TERRACE

B11: REPLACE COTTONWOOD

B10: REHABILITATE LILY POND

B9: RESTORE MINERAL WATER AT PAVILION

B8: RESTORE SEMICIRCULAR BENCH

B19: INSTALL GRATES ON TRAIL DRAINS

B20: PROVIDE ADA ACCESS AT BROMIDE OVERLOOK

B22: MAINTAIN PRAIRIE AREA

B1: CONSTRUCT NEW PICNIC SHELTER


B9: RESTORE MINERAL WATER AT PAVILION

B20: GRADE ACCESS RAMP FROM PARKING AREA

PLATT DISTRICT
 Chickasaw National Recreation Area
 Cultural Landscape Report
 Iowa State University, Landscape Architecture Department
 Date 10/7/2002

TREATMENT PROJECTS
 Bromide Springs and Bromide Hill
 Drawing 25

scale 1" = 150'

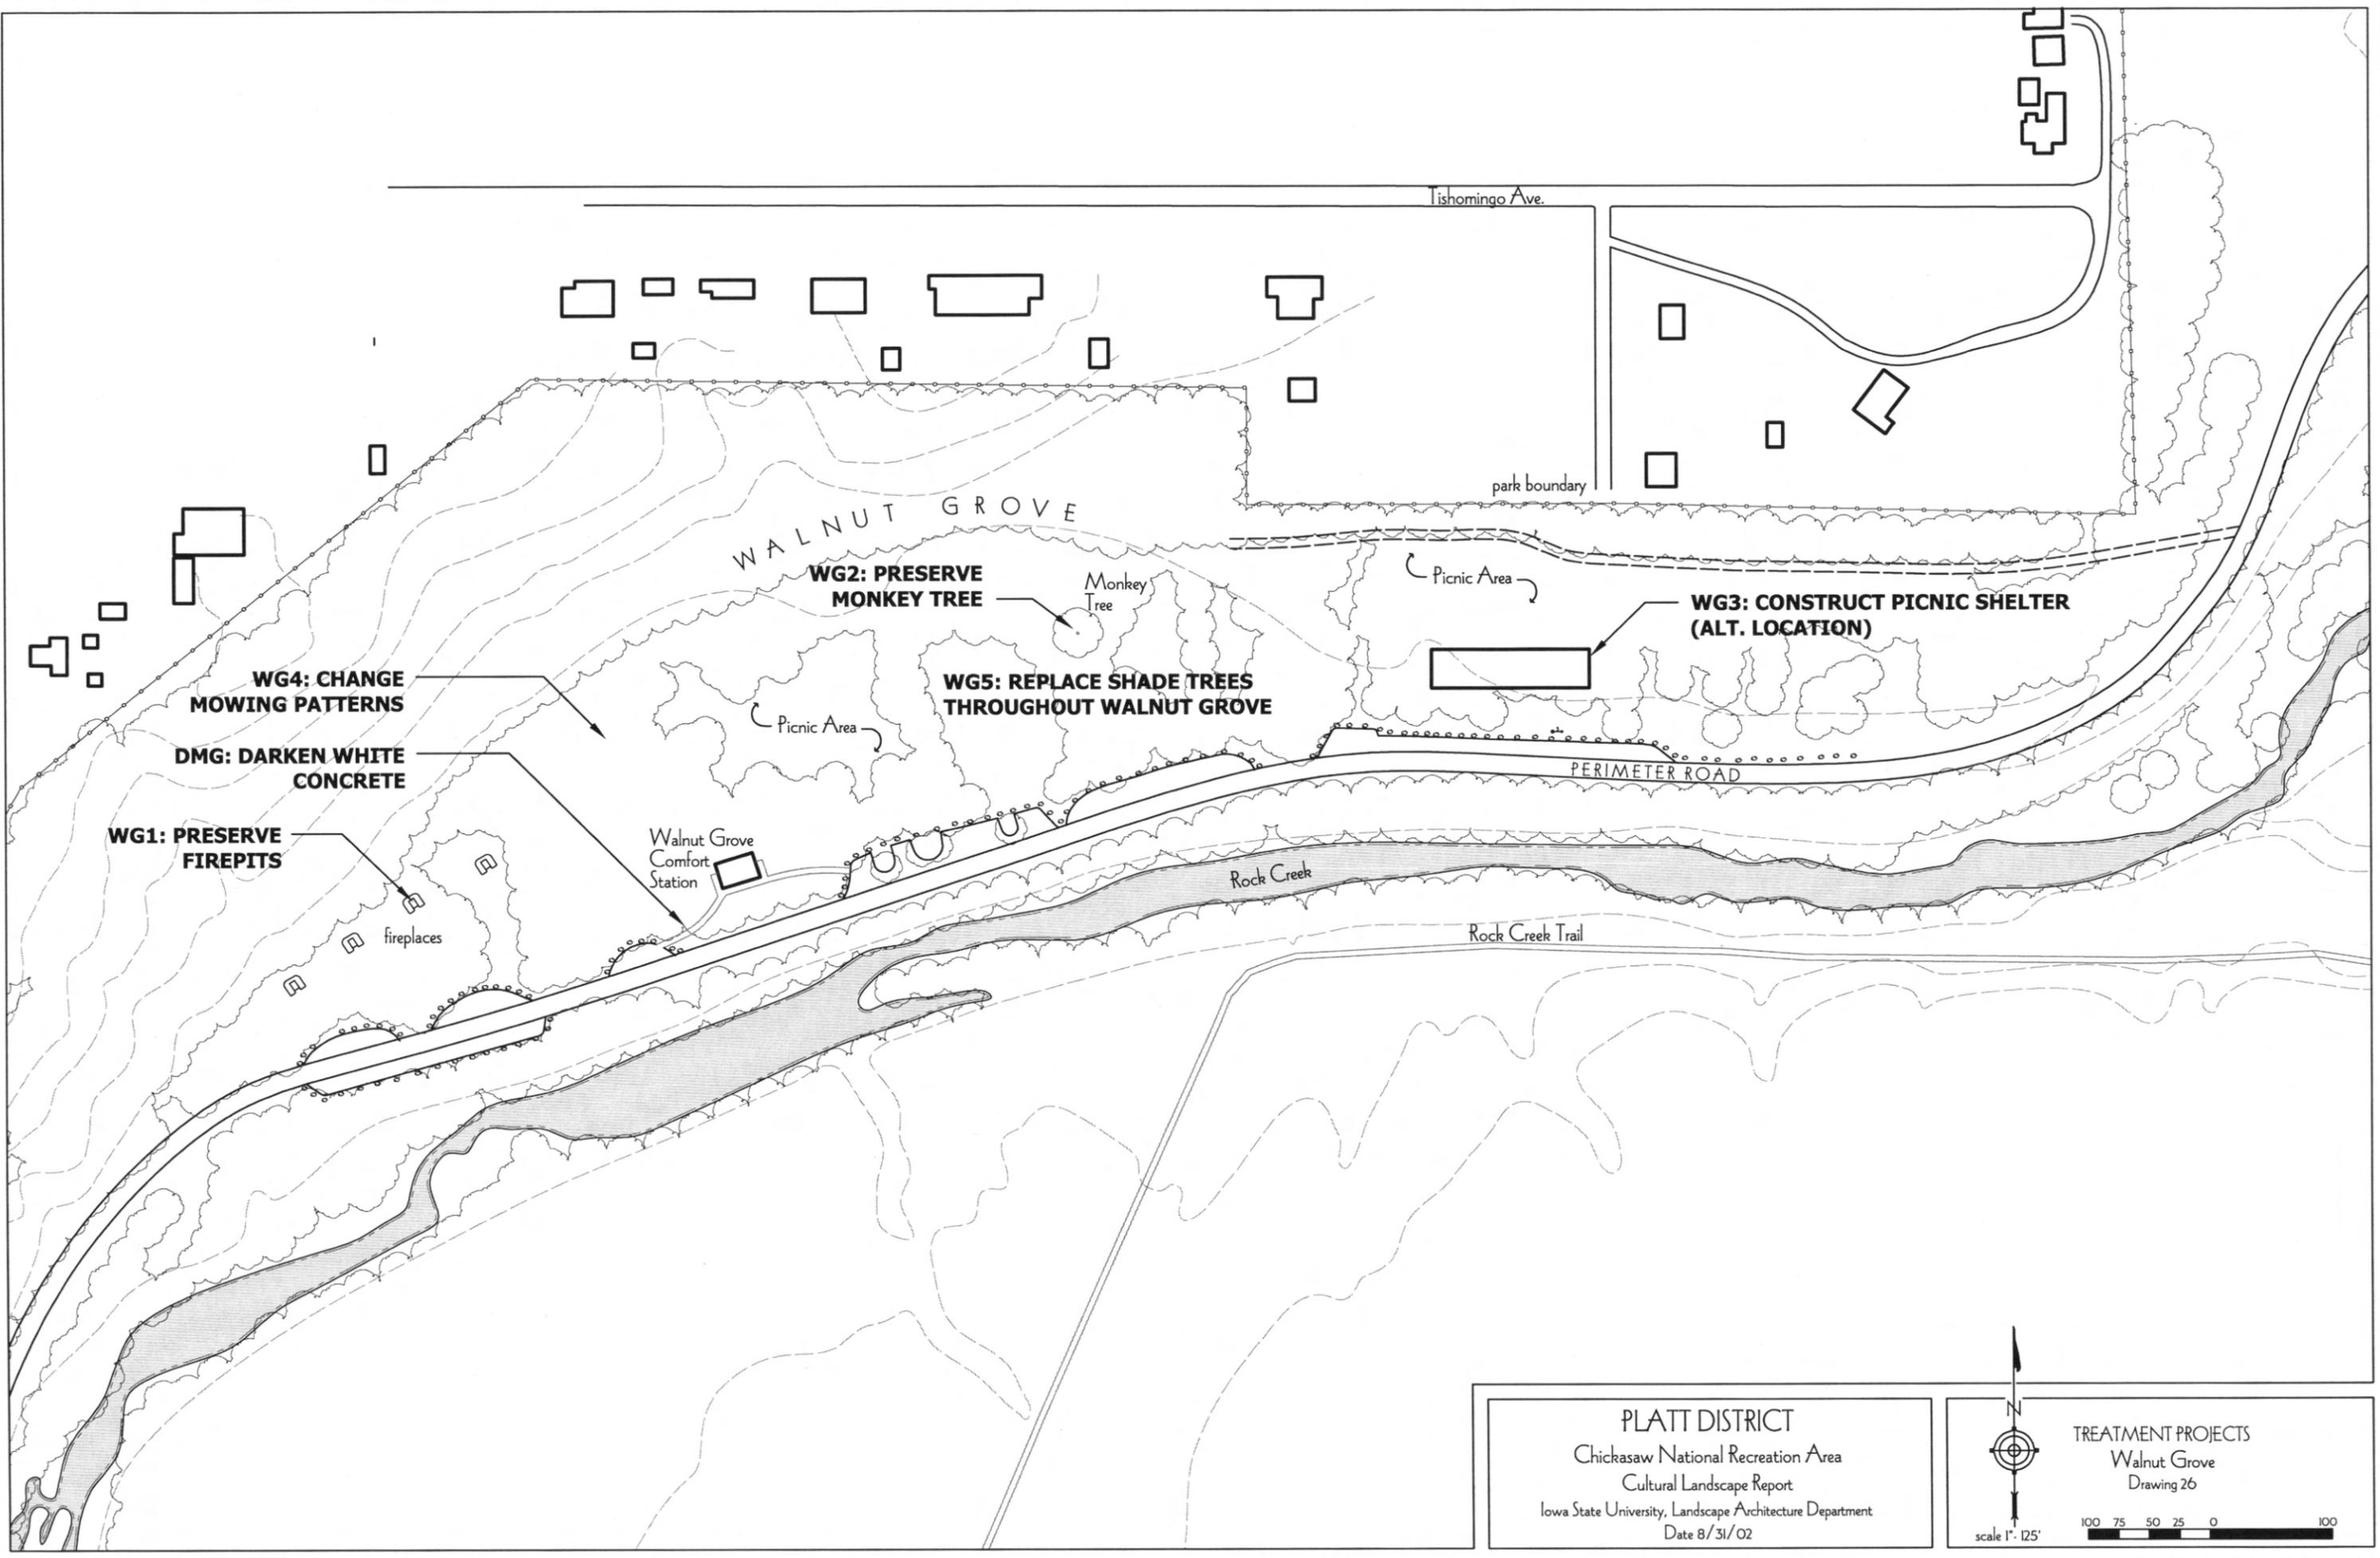

Tishomingo Ave.

park boundary

WALNUT GROVE

WG2: PRESERVE MONKEY TREE

Monkey Tree

Picnic Area

WG3: CONSTRUCT PICNIC SHELTER (ALT. LOCATION)

WG5: REPLACE SHADE TREES THROUGHOUT WALNUT GROVE

Picnic Area

PERIMETER ROAD

Rock Creek

Rock Creek Trail

WG4: CHANGE MOWING PATTERNS

DMG: DARKEN WHITE CONCRETE

WG1: PRESERVE FIREPITS

fireplaces

Walnut Grove Comfort Station

PLATT DISTRICT

Chickasaw National Recreation Area
Cultural Landscape Report


Iowa State University, Landscape Architecture Department
Date 8/31/02



TREATMENT PROJECTS
Walnut Grove
Drawing 26

scale 1" = 125'



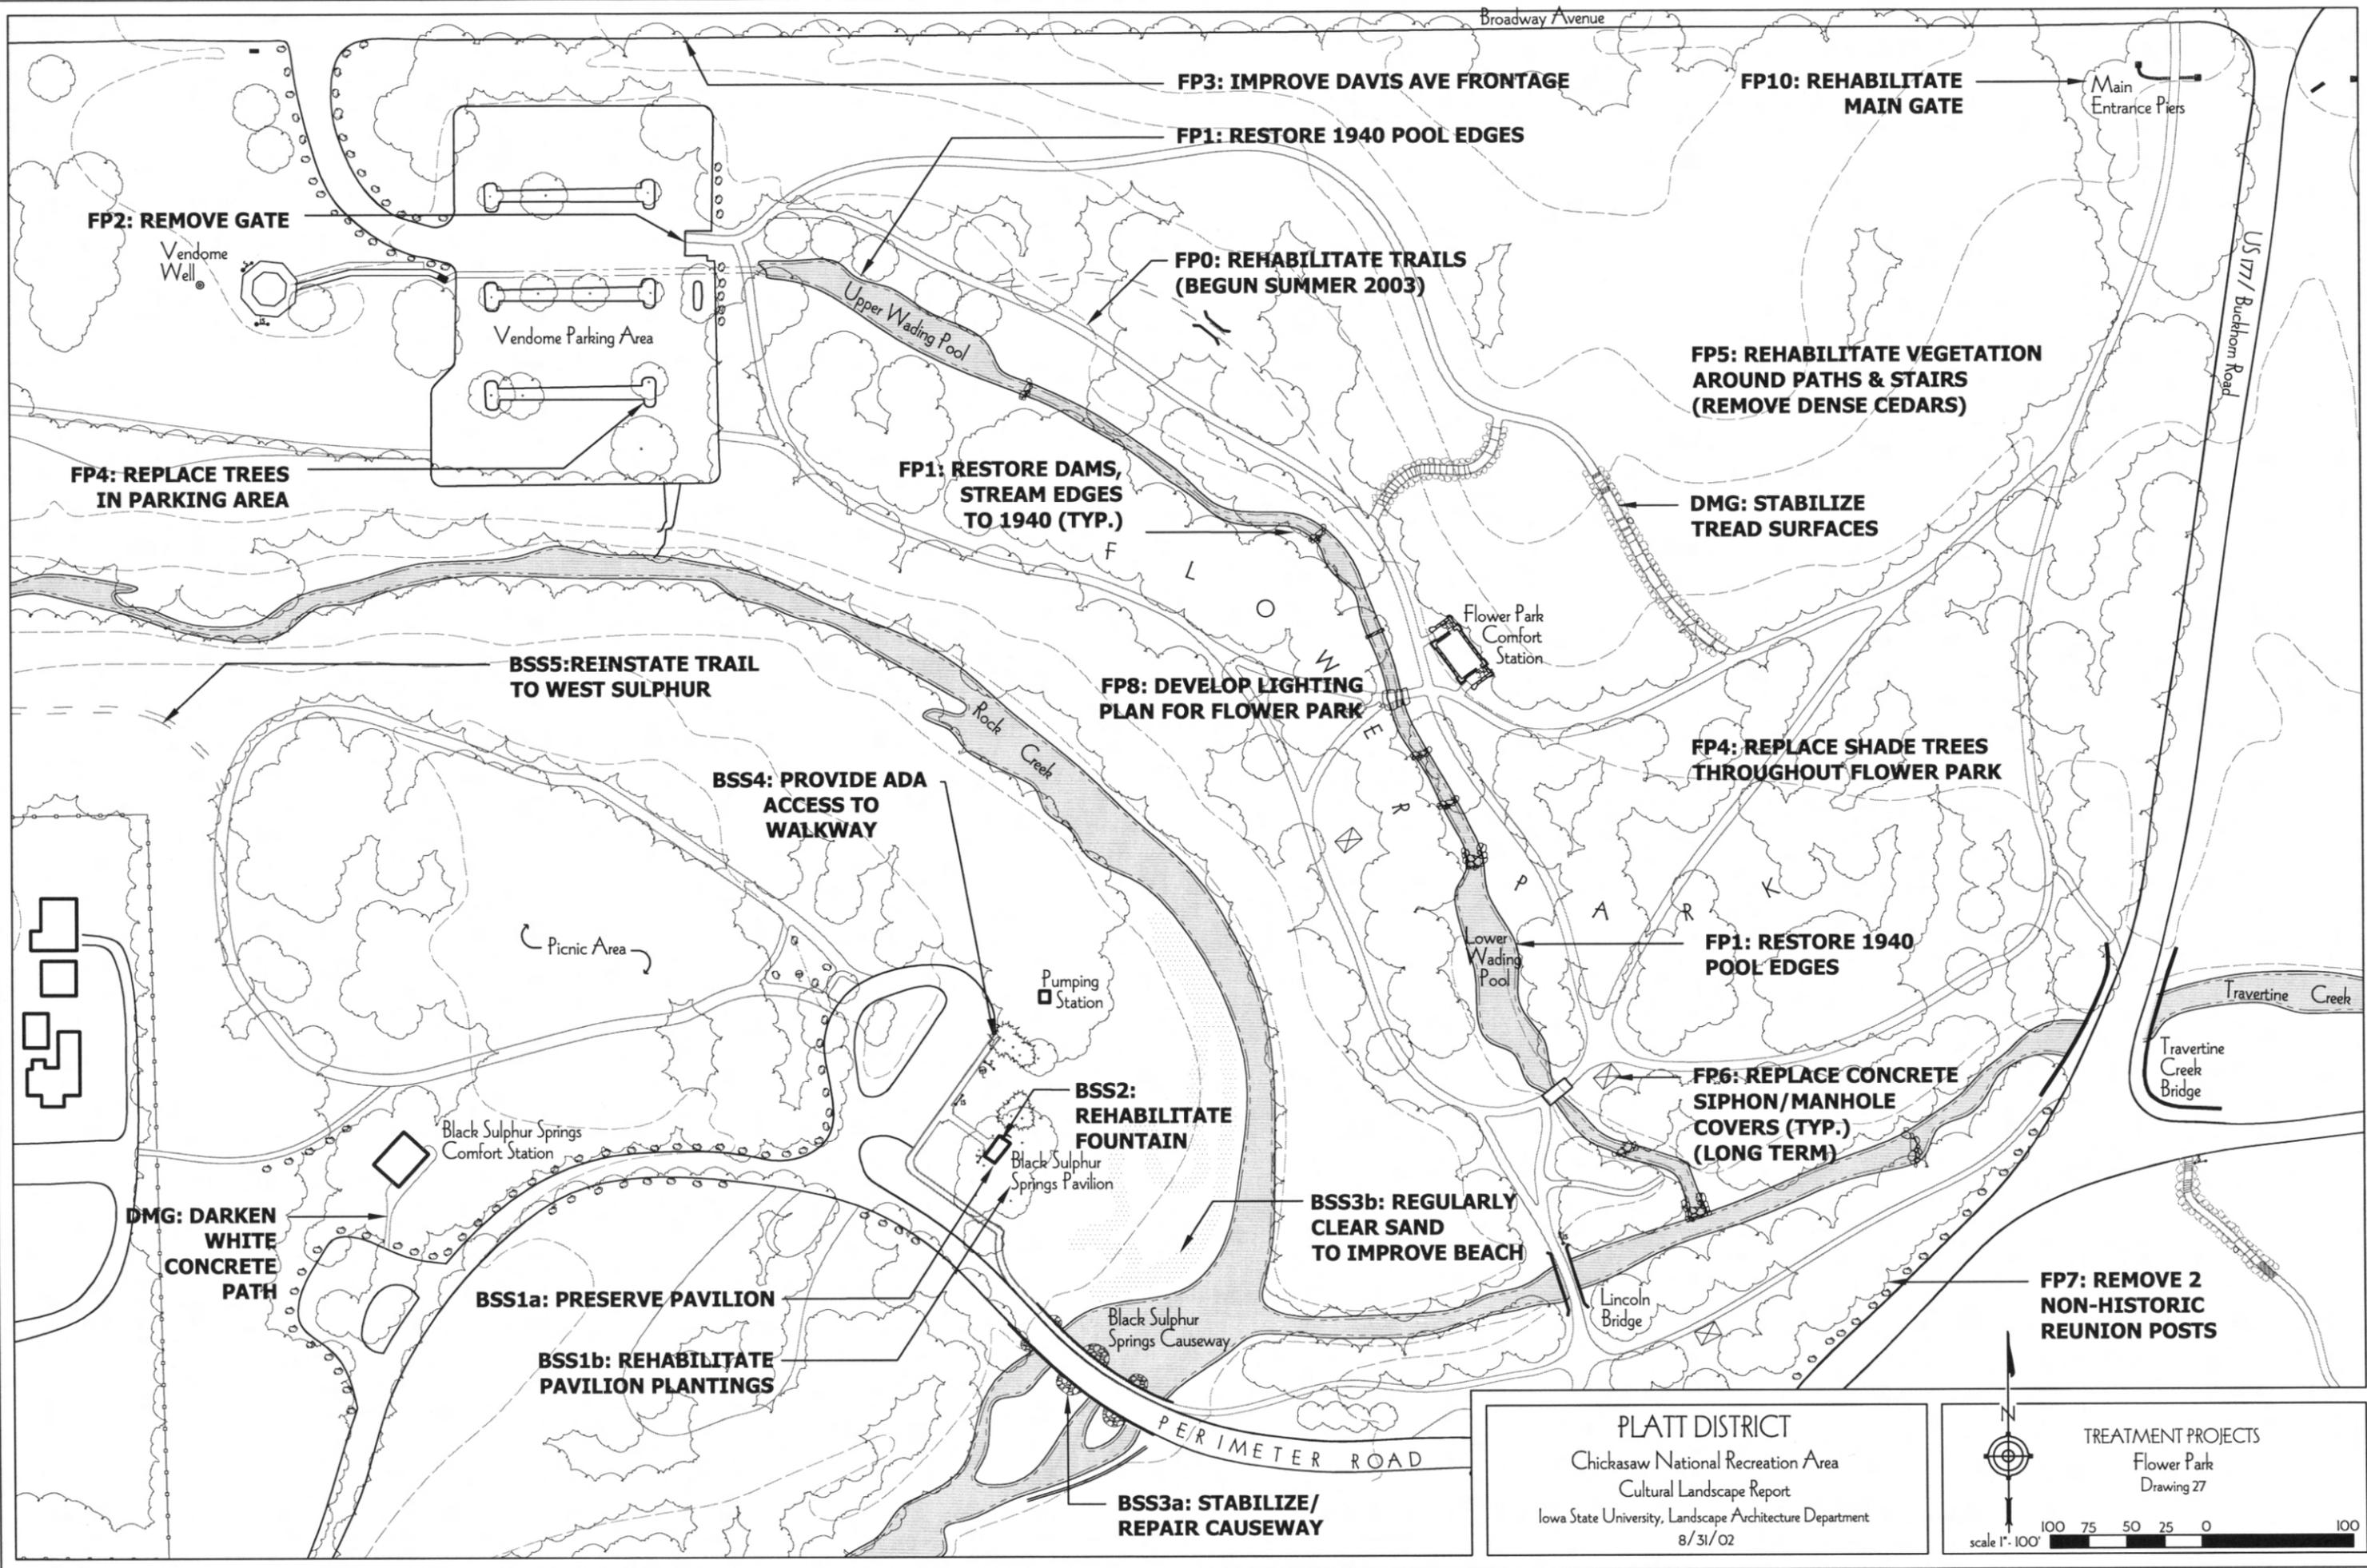

FP2: REMOVE GATE

FP4: REPLACE TREES IN PARKING AREA

DMG: DARKEN WHITE CONCRETE PATH

BSS1a: PRESERVE PAVILION

BSS1b: REHABILITATE PAVILION PLANTINGS

FP2: REMOVE GATE

FP3: IMPROVE DAVIS AVE FRONTAGE

FP1: RESTORE 1940 POOL EDGES

FP0: REHABILITATE TRAILS (BEGUN SUMMER 2003)

FP1: RESTORE DAMS, STREAM EDGES TO 1940 (TYP.)

FP8: DEVELOP LIGHTING PLAN FOR FLOWER PARK

BSS2: REHABILITATE FOUNTAIN

BSS3b: REGULARLY CLEAR SAND TO IMPROVE BEACH

BSS3a: STABILIZE/REPAIR CAUSEWAY

FP10: REHABILITATE MAIN GATE

FP5: REHABILITATE VEGETATION AROUND PATHS & STAIRS (REMOVE DENSE CEDARS)

DMG: STABILIZE TREAD SURFACES


FP4: REPLACE SHADE TREES THROUGHOUT FLOWER PARK

FP1: RESTORE 1940 POOL EDGES


FP6: REPLACE CONCRETE SIPHON/MANHOLE COVERS (TYP.) (LONG TERM)

FP7: REMOVE 2 NON-HISTORIC REUNION POSTS

PLATT DISTRICT
 Chickasaw National Recreation Area
 Cultural Landscape Report
 Iowa State University, Landscape Architecture Department
 8/31/02

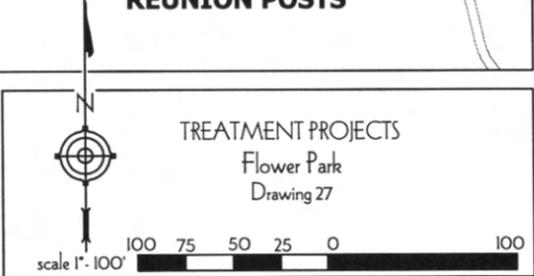

See drawing 19

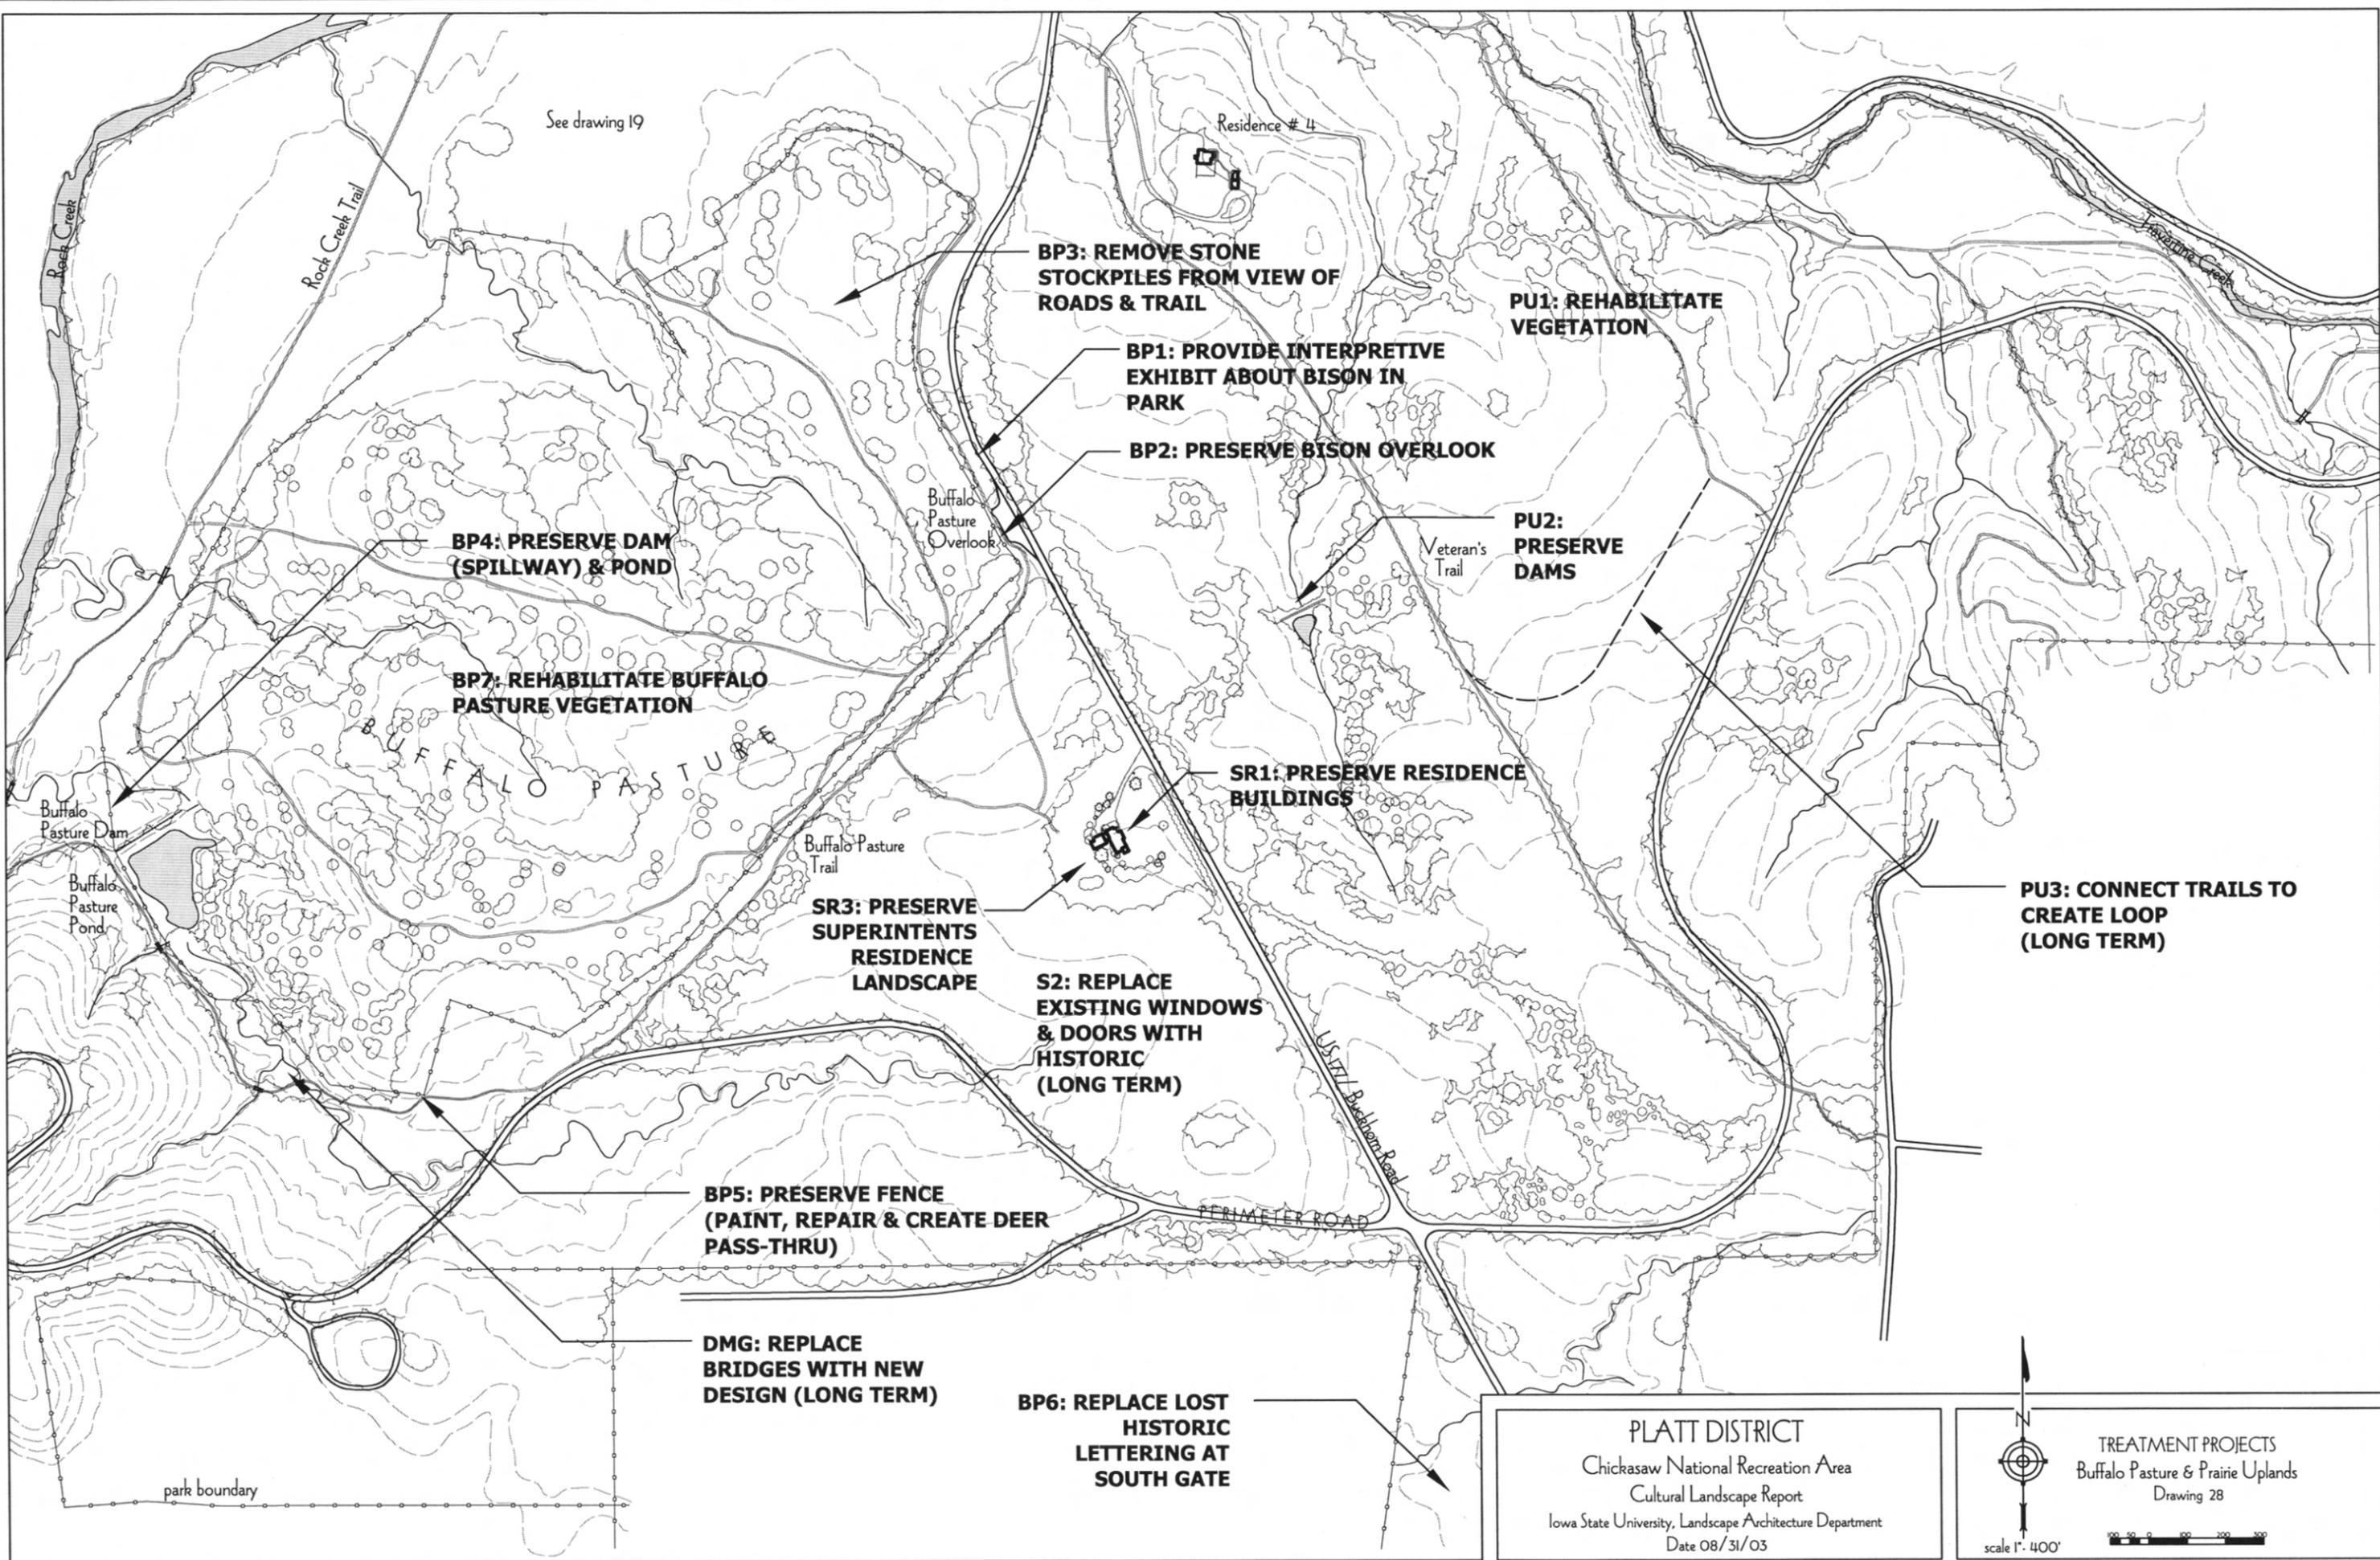

BP3: REMOVE STONE STOCKPILES FROM VIEW OF ROADS & TRAIL

PU1: REHABILITATE VEGETATION

BP1: PROVIDE INTERPRETIVE EXHIBIT ABOUT BISON IN PARK

BP2: PRESERVE BISON OVERLOOK

PU2: PRESERVE DAMS

BP4: PRESERVE DAM (SPILLWAY) & POND

BP7: REHABILITATE BUFFALO PASTURE VEGETATION

SR1: PRESERVE RESIDENCE BUILDINGS

PU3: CONNECT TRAILS TO CREATE LOOP (LONG TERM)

SR3: PRESERVE SUPERINTENDENTS RESIDENCE LANDSCAPE

S2: REPLACE EXISTING WINDOWS & DOORS WITH HISTORIC (LONG TERM)

BP5: PRESERVE FENCE (PAINT, REPAIR & CREATE DEER PASS-THRU)

DMG: REPLACE BRIDGES WITH NEW DESIGN (LONG TERM)


BP6: REPLACE LOST HISTORIC LETTERING AT SOUTH GATE

PLATT DISTRICT
 Chickasaw National Recreation Area
 Cultural Landscape Report
 Iowa State University, Landscape Architecture Department
 Date 08/31/03

TREATMENT PROJECTS
 Buffalo Pasture & Prairie Uplands
 Drawing 28

scale 1" = 400'

park boundary

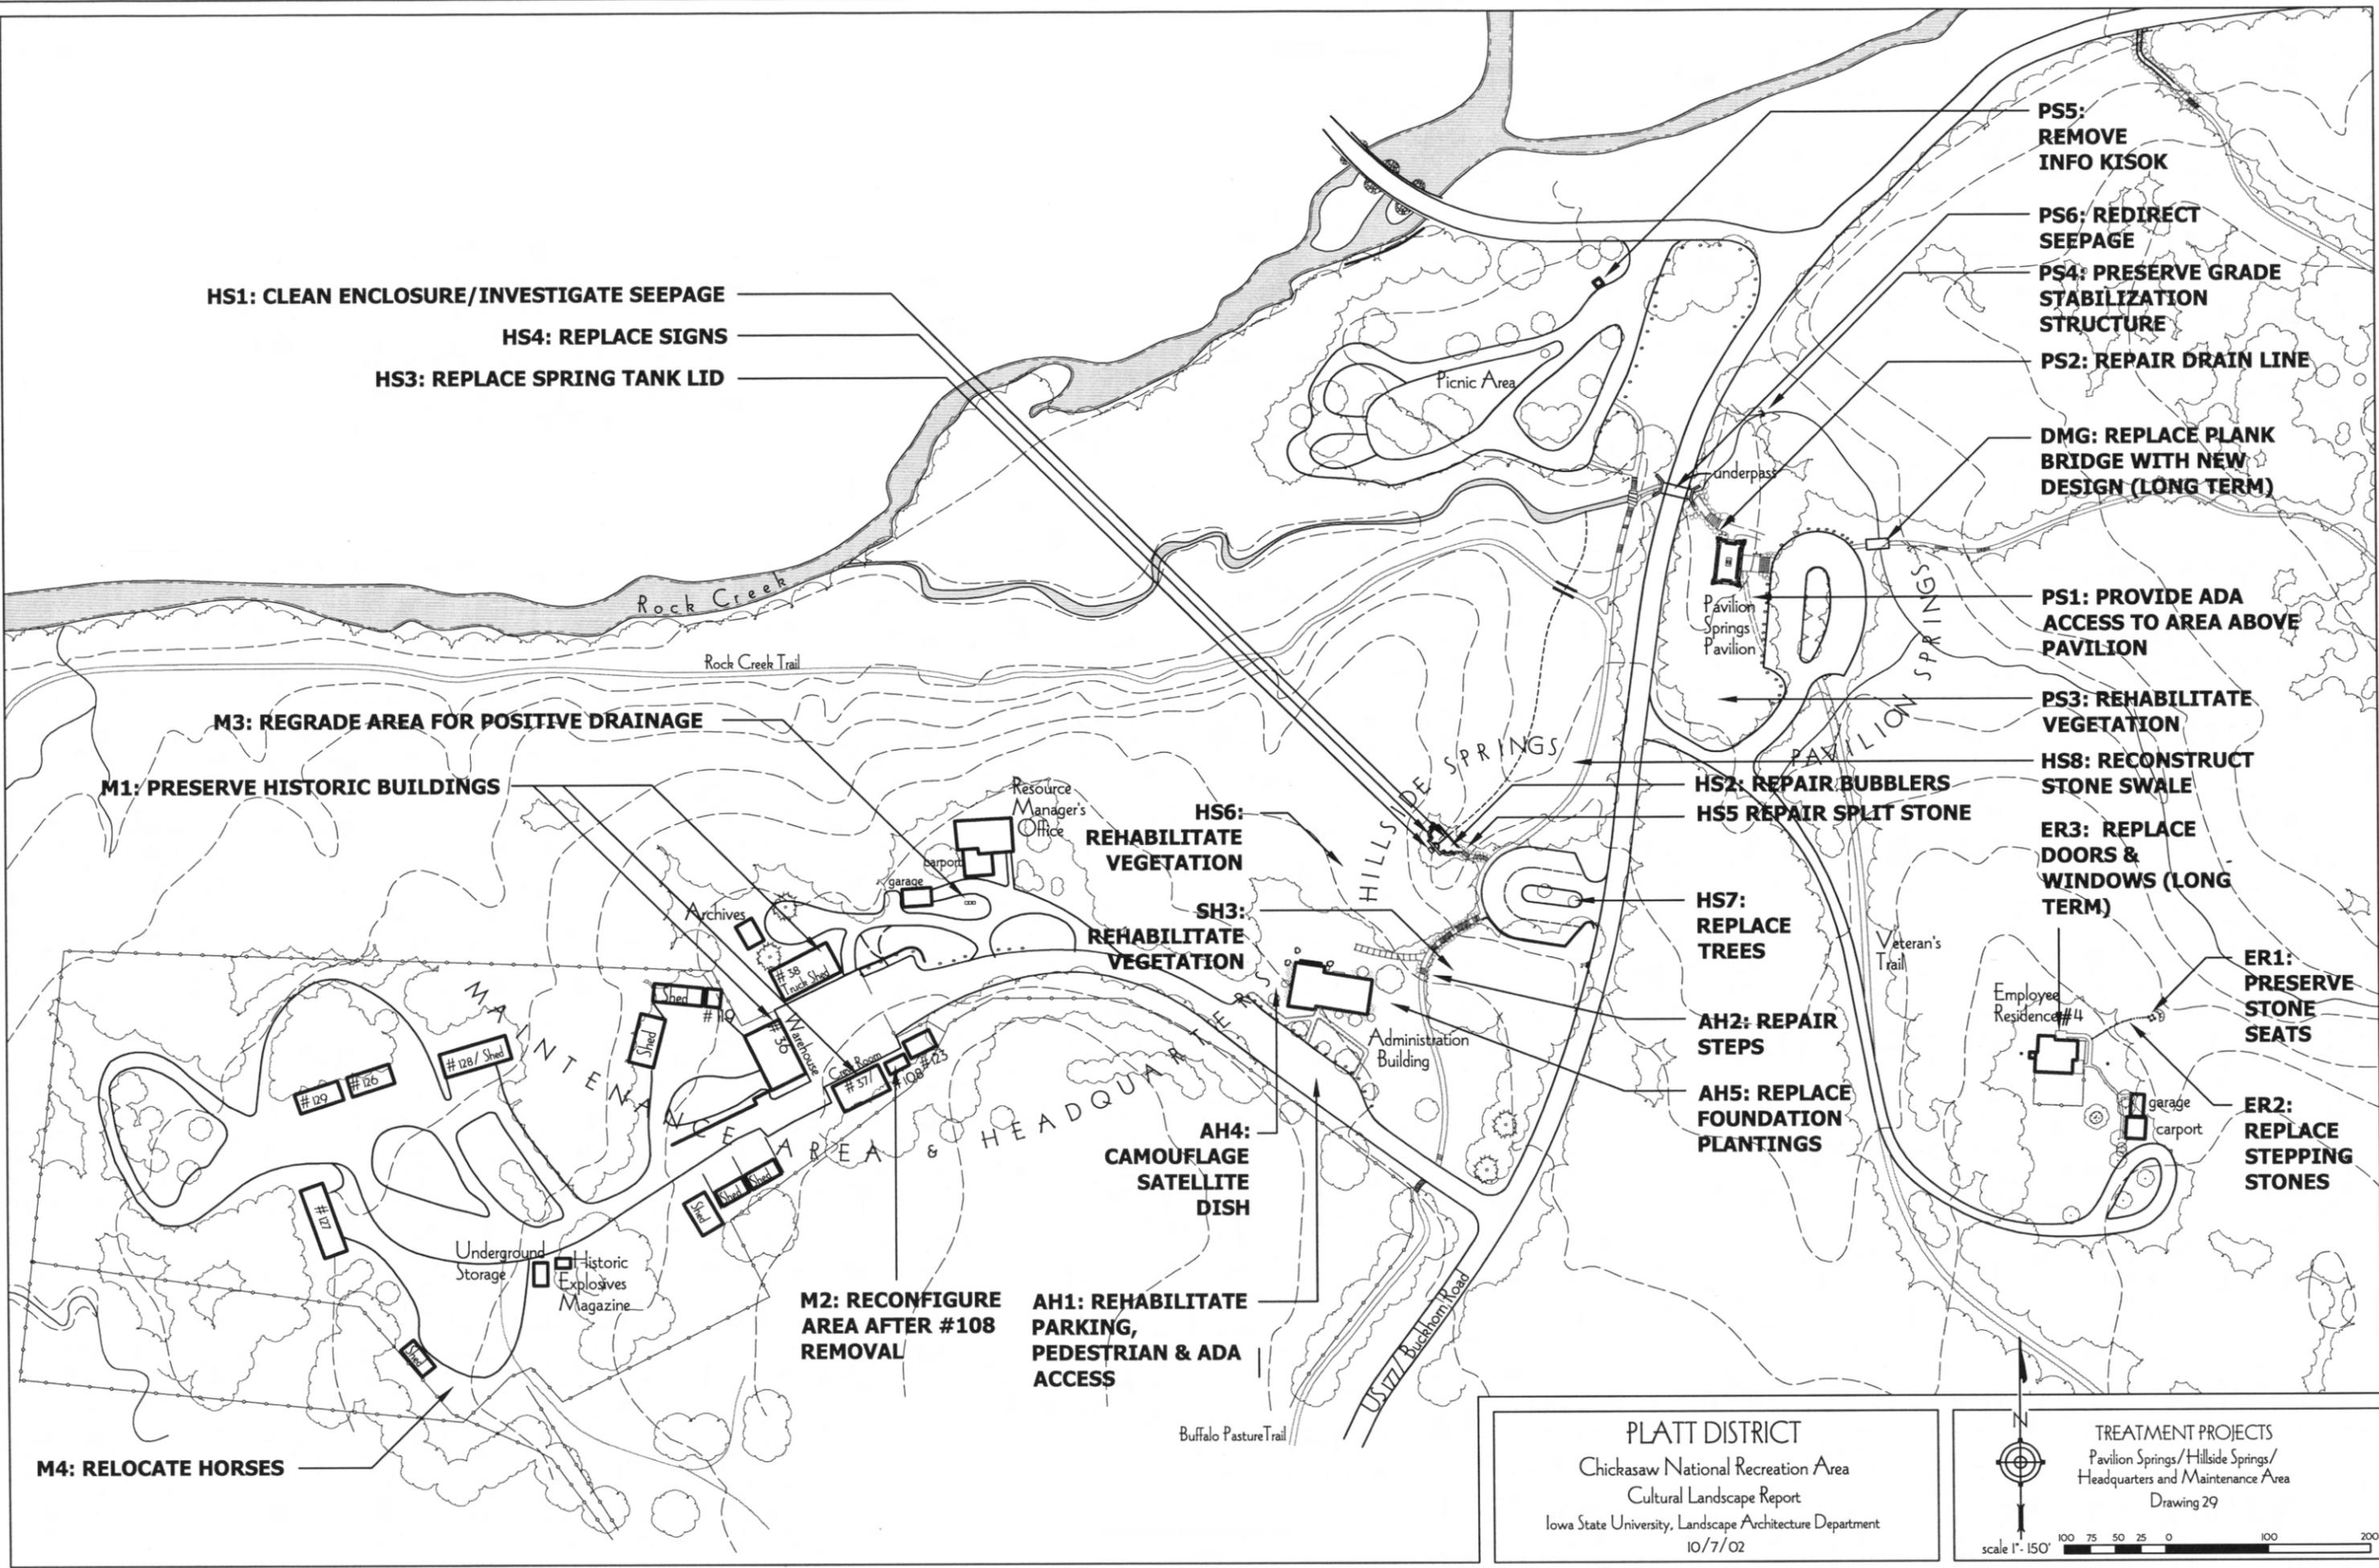

HS1: CLEAN ENCLOSURE/INVESTIGATE SEEPAGE
HS4: REPLACE SIGNS
HS3: REPLACE SPRING TANK LID

PS5: REMOVE INFO KISOK
PS6: REDIRECT SEEPAGE
PS4: PRESERVE GRADE STABILIZATION STRUCTURE
PS2: REPAIR DRAIN LINE
DMG: REPLACE PLANK BRIDGE WITH NEW DESIGN (LONG TERM)

PS1: PROVIDE ADA ACCESS TO AREA ABOVE PAVILION

PS3: REHABILITATE VEGETATION
HS8: RECONSTRUCT STONE SWALE

ER3: REPLACE DOORS & WINDOWS (LONG TERM)

ER1: PRESERVE STONE SEATS

ER2: REPLACE STEPPING STONES

M3: REGRADE AREA FOR POSITIVE DRAINAGE
M1: PRESERVE HISTORIC BUILDINGS

HS6: REHABILITATE VEGETATION

SH3: REHABILITATE VEGETATION

HS2: REPAIR BUBBLERS
HS5 REPAIR SPLIT STONE

HS7: REPLACE TREES

AH2: REPAIR STEPS

AH5: REPLACE FOUNDATION PLANTINGS


AH4: CAMOUFLAGE SATELLITE DISH


M2: RECONFIGURE AREA AFTER #108 REMOVAL

AH1: REHABILITATE PARKING, PEDESTRIAN & ADA ACCESS


M4: RELOCATE HORSES


PLATT DISTRICT
 Chickasaw National Recreation Area
 Cultural Landscape Report
 Iowa State University, Landscape Architecture Department
 10/7/02

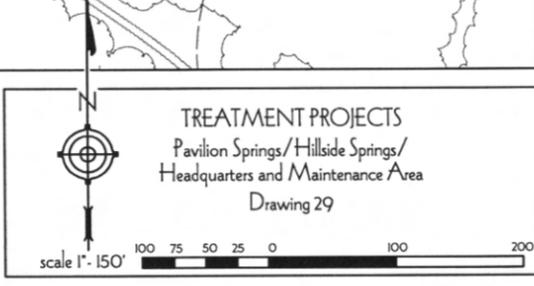

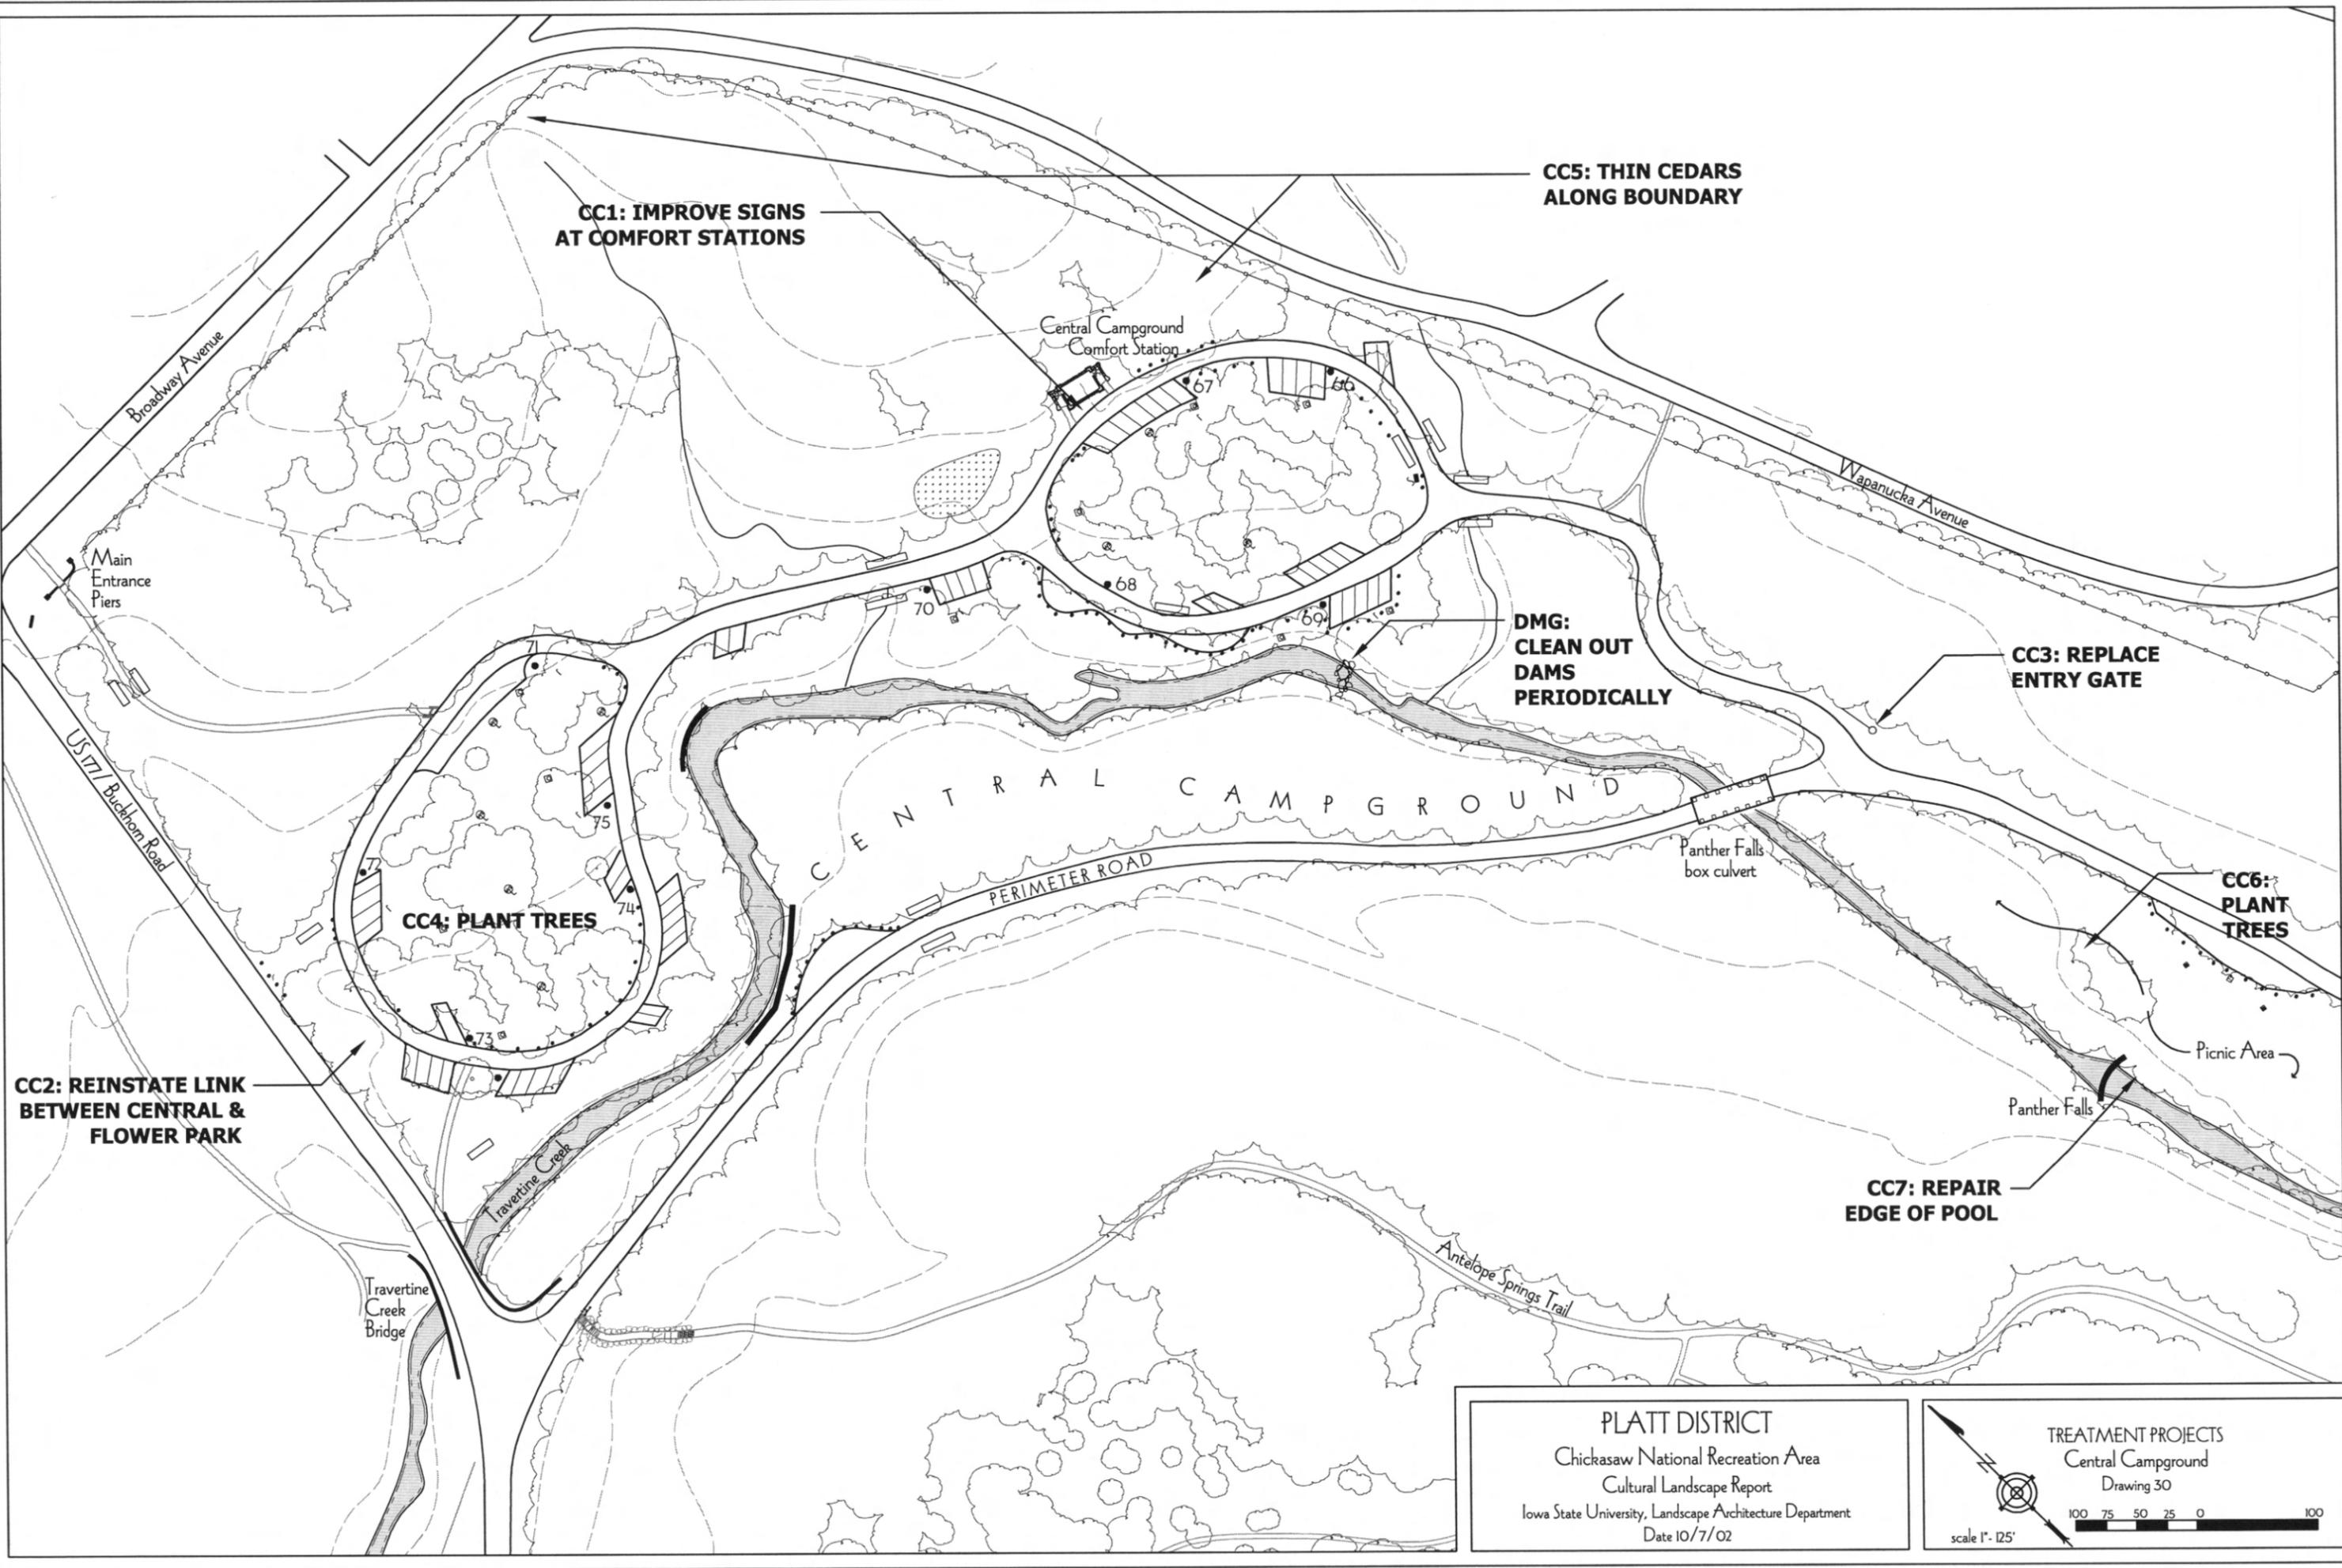

PLATT DISTRICT
 Chickasaw National Recreation Area
 Cultural Landscape Report
 Iowa State University, Landscape Architecture Department
 Date 10/7/02

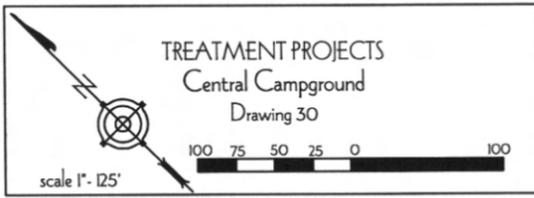

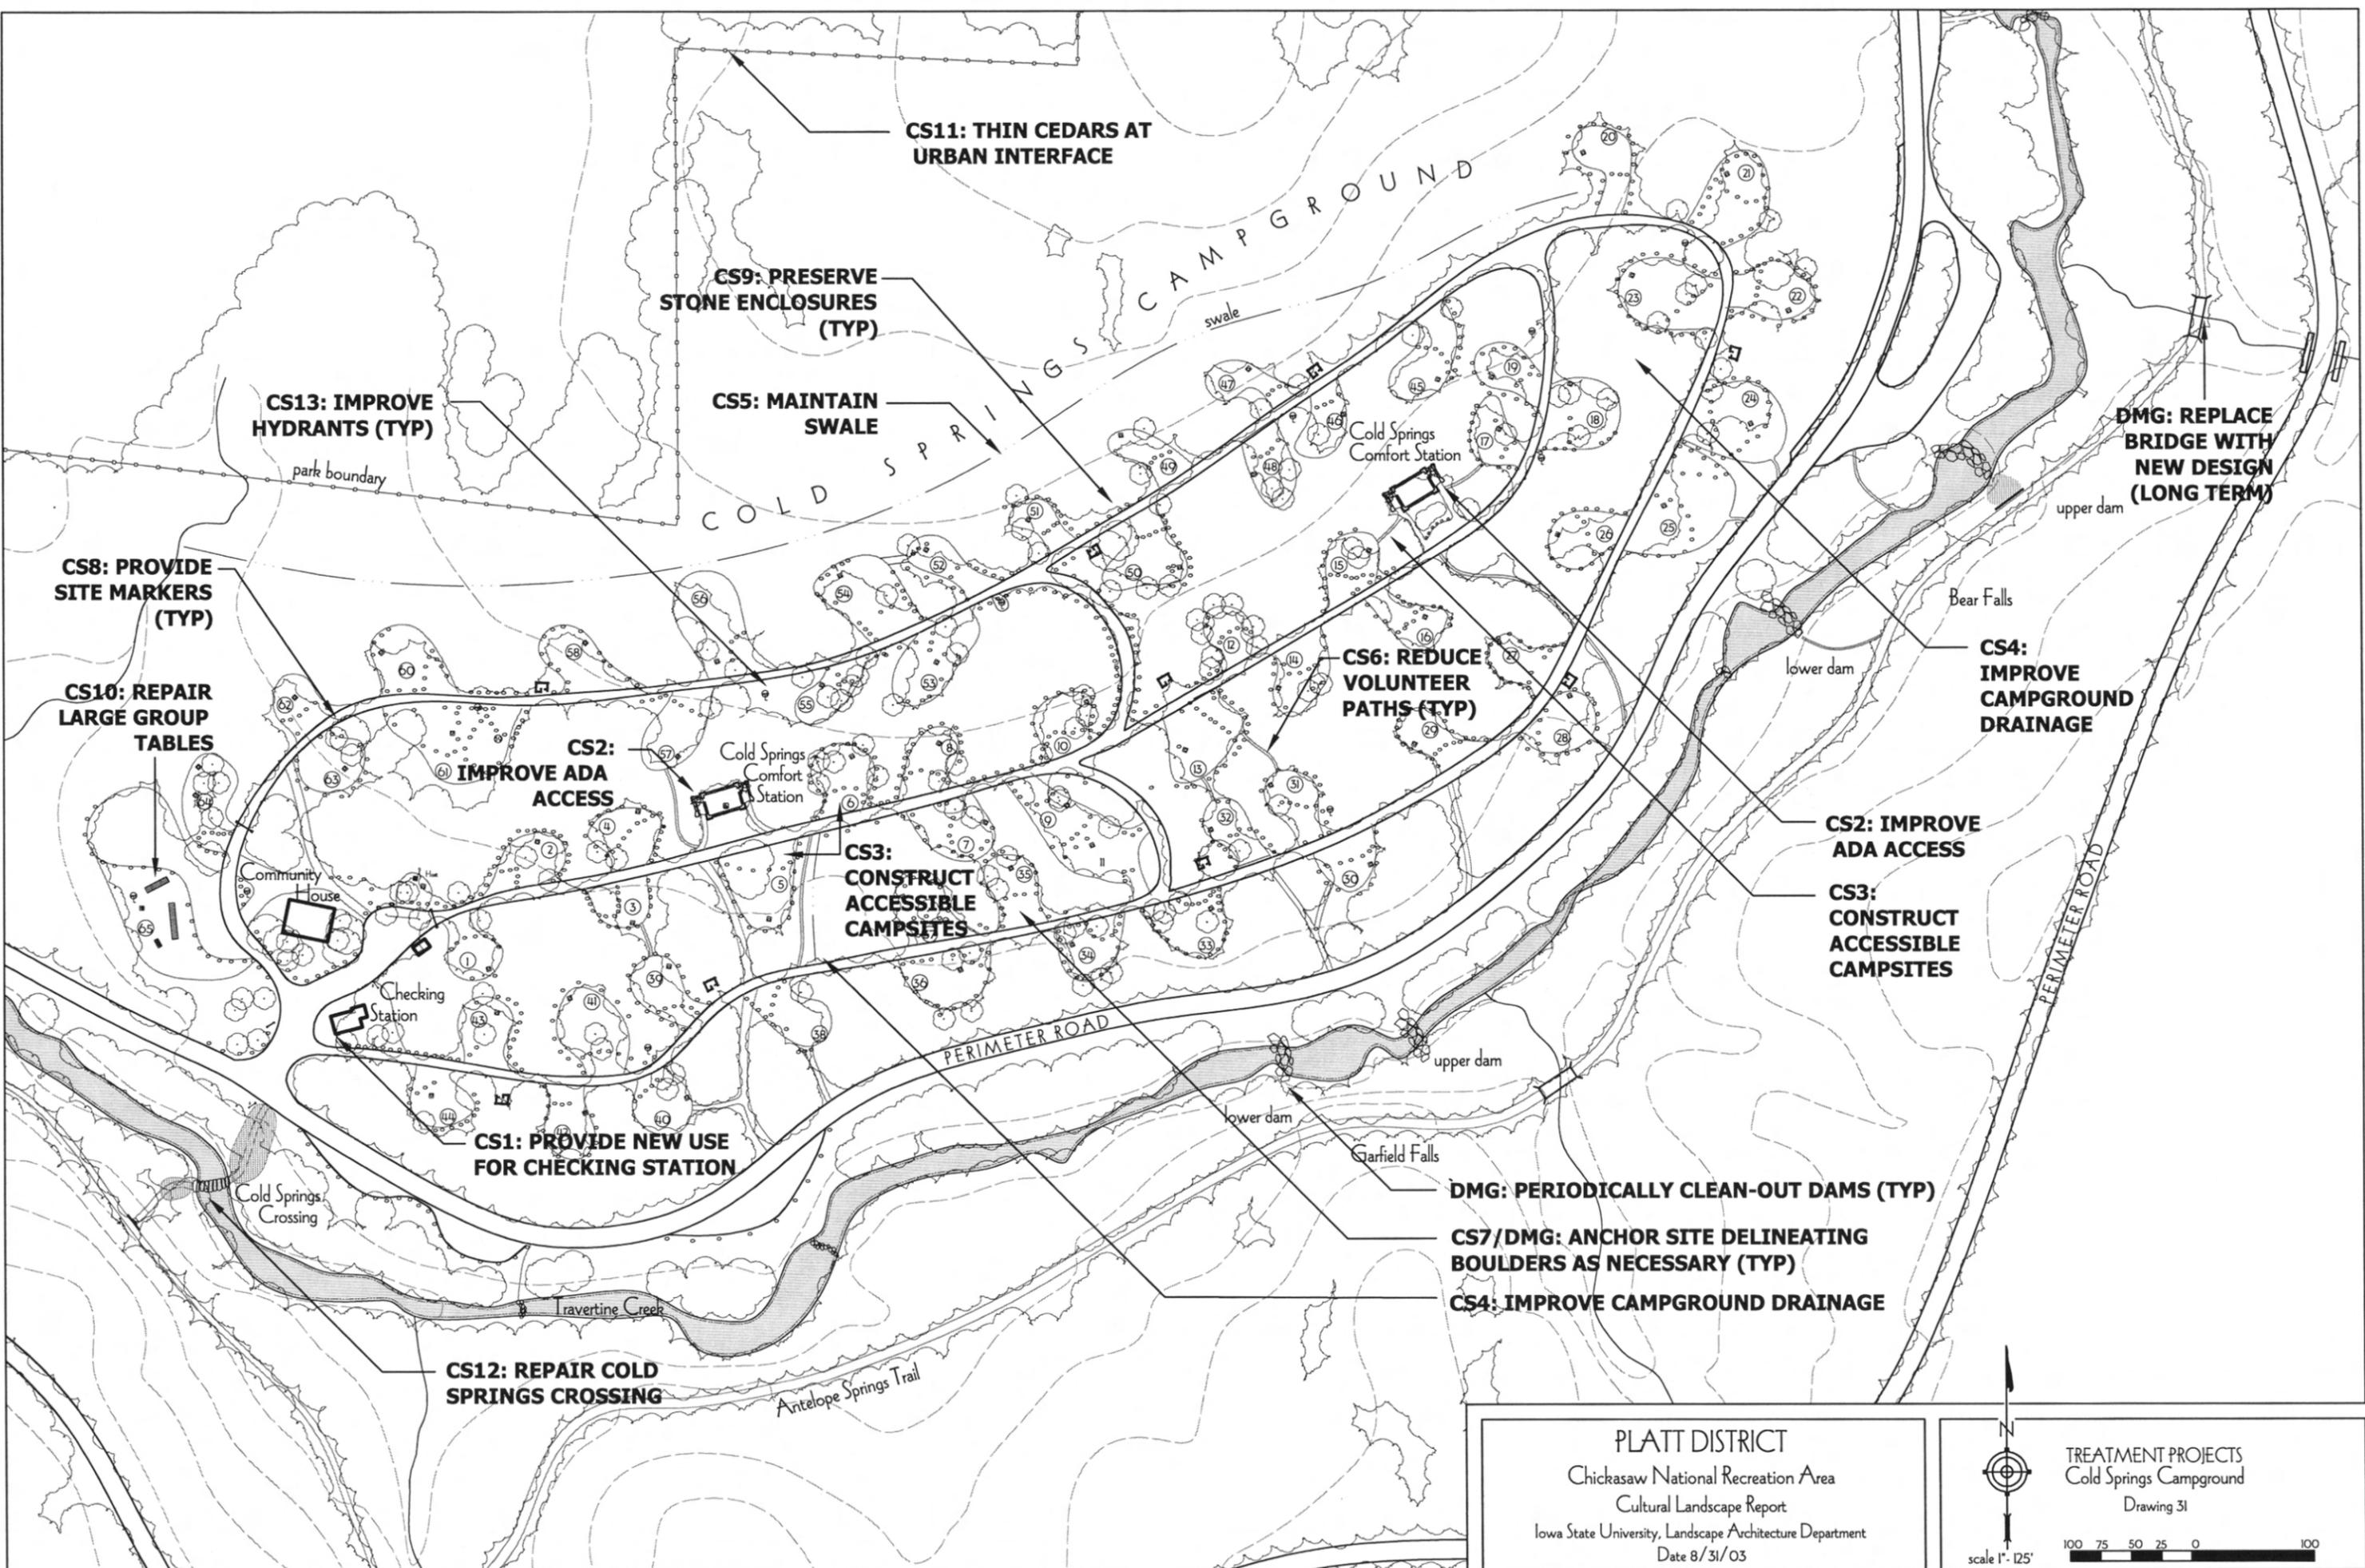

CS11: THIN CEDARS AT URBAN INTERFACE

CS9: PRESERVE STONE ENCLOSURES (TYP)

CS13: IMPROVE HYDRANTS (TYP)

CS5: MAINTAIN SWALE

CS8: PROVIDE SITE MARKERS (TYP)

CS10: REPAIR LARGE GROUP TABLES

CS2: IMPROVE ADA ACCESS

CS6: REDUCE VOLUNTEER PATHS (TYP)

DMG: REPLACE BRIDGE WITH NEW DESIGN (LONG TERM)

CS4: IMPROVE CAMPGROUND DRAINAGE

CS3: CONSTRUCT ACCESSIBLE CAMPSITES

CS2: IMPROVE ADA ACCESS

CS3: CONSTRUCT ACCESSIBLE CAMPSITES

CS1: PROVIDE NEW USE FOR CHECKING STATION

DMG: PERIODICALLY CLEAN-OUT DAMS (TYP)

CS7/DMG: ANCHOR SITE DELINEATING BOULDERS AS NECESSARY (TYP)


CS4: IMPROVE CAMPGROUND DRAINAGE

CS12: REPAIR COLD SPRINGS CROSSING

PLATT DISTRICT
 Chickasaw National Recreation Area
 Cultural Landscape Report
 Iowa State University, Landscape Architecture Department
 Date 8/31/03

TREATMENT PROJECTS
 Cold Springs Campground
 Drawing 31

scale 1" = 125'

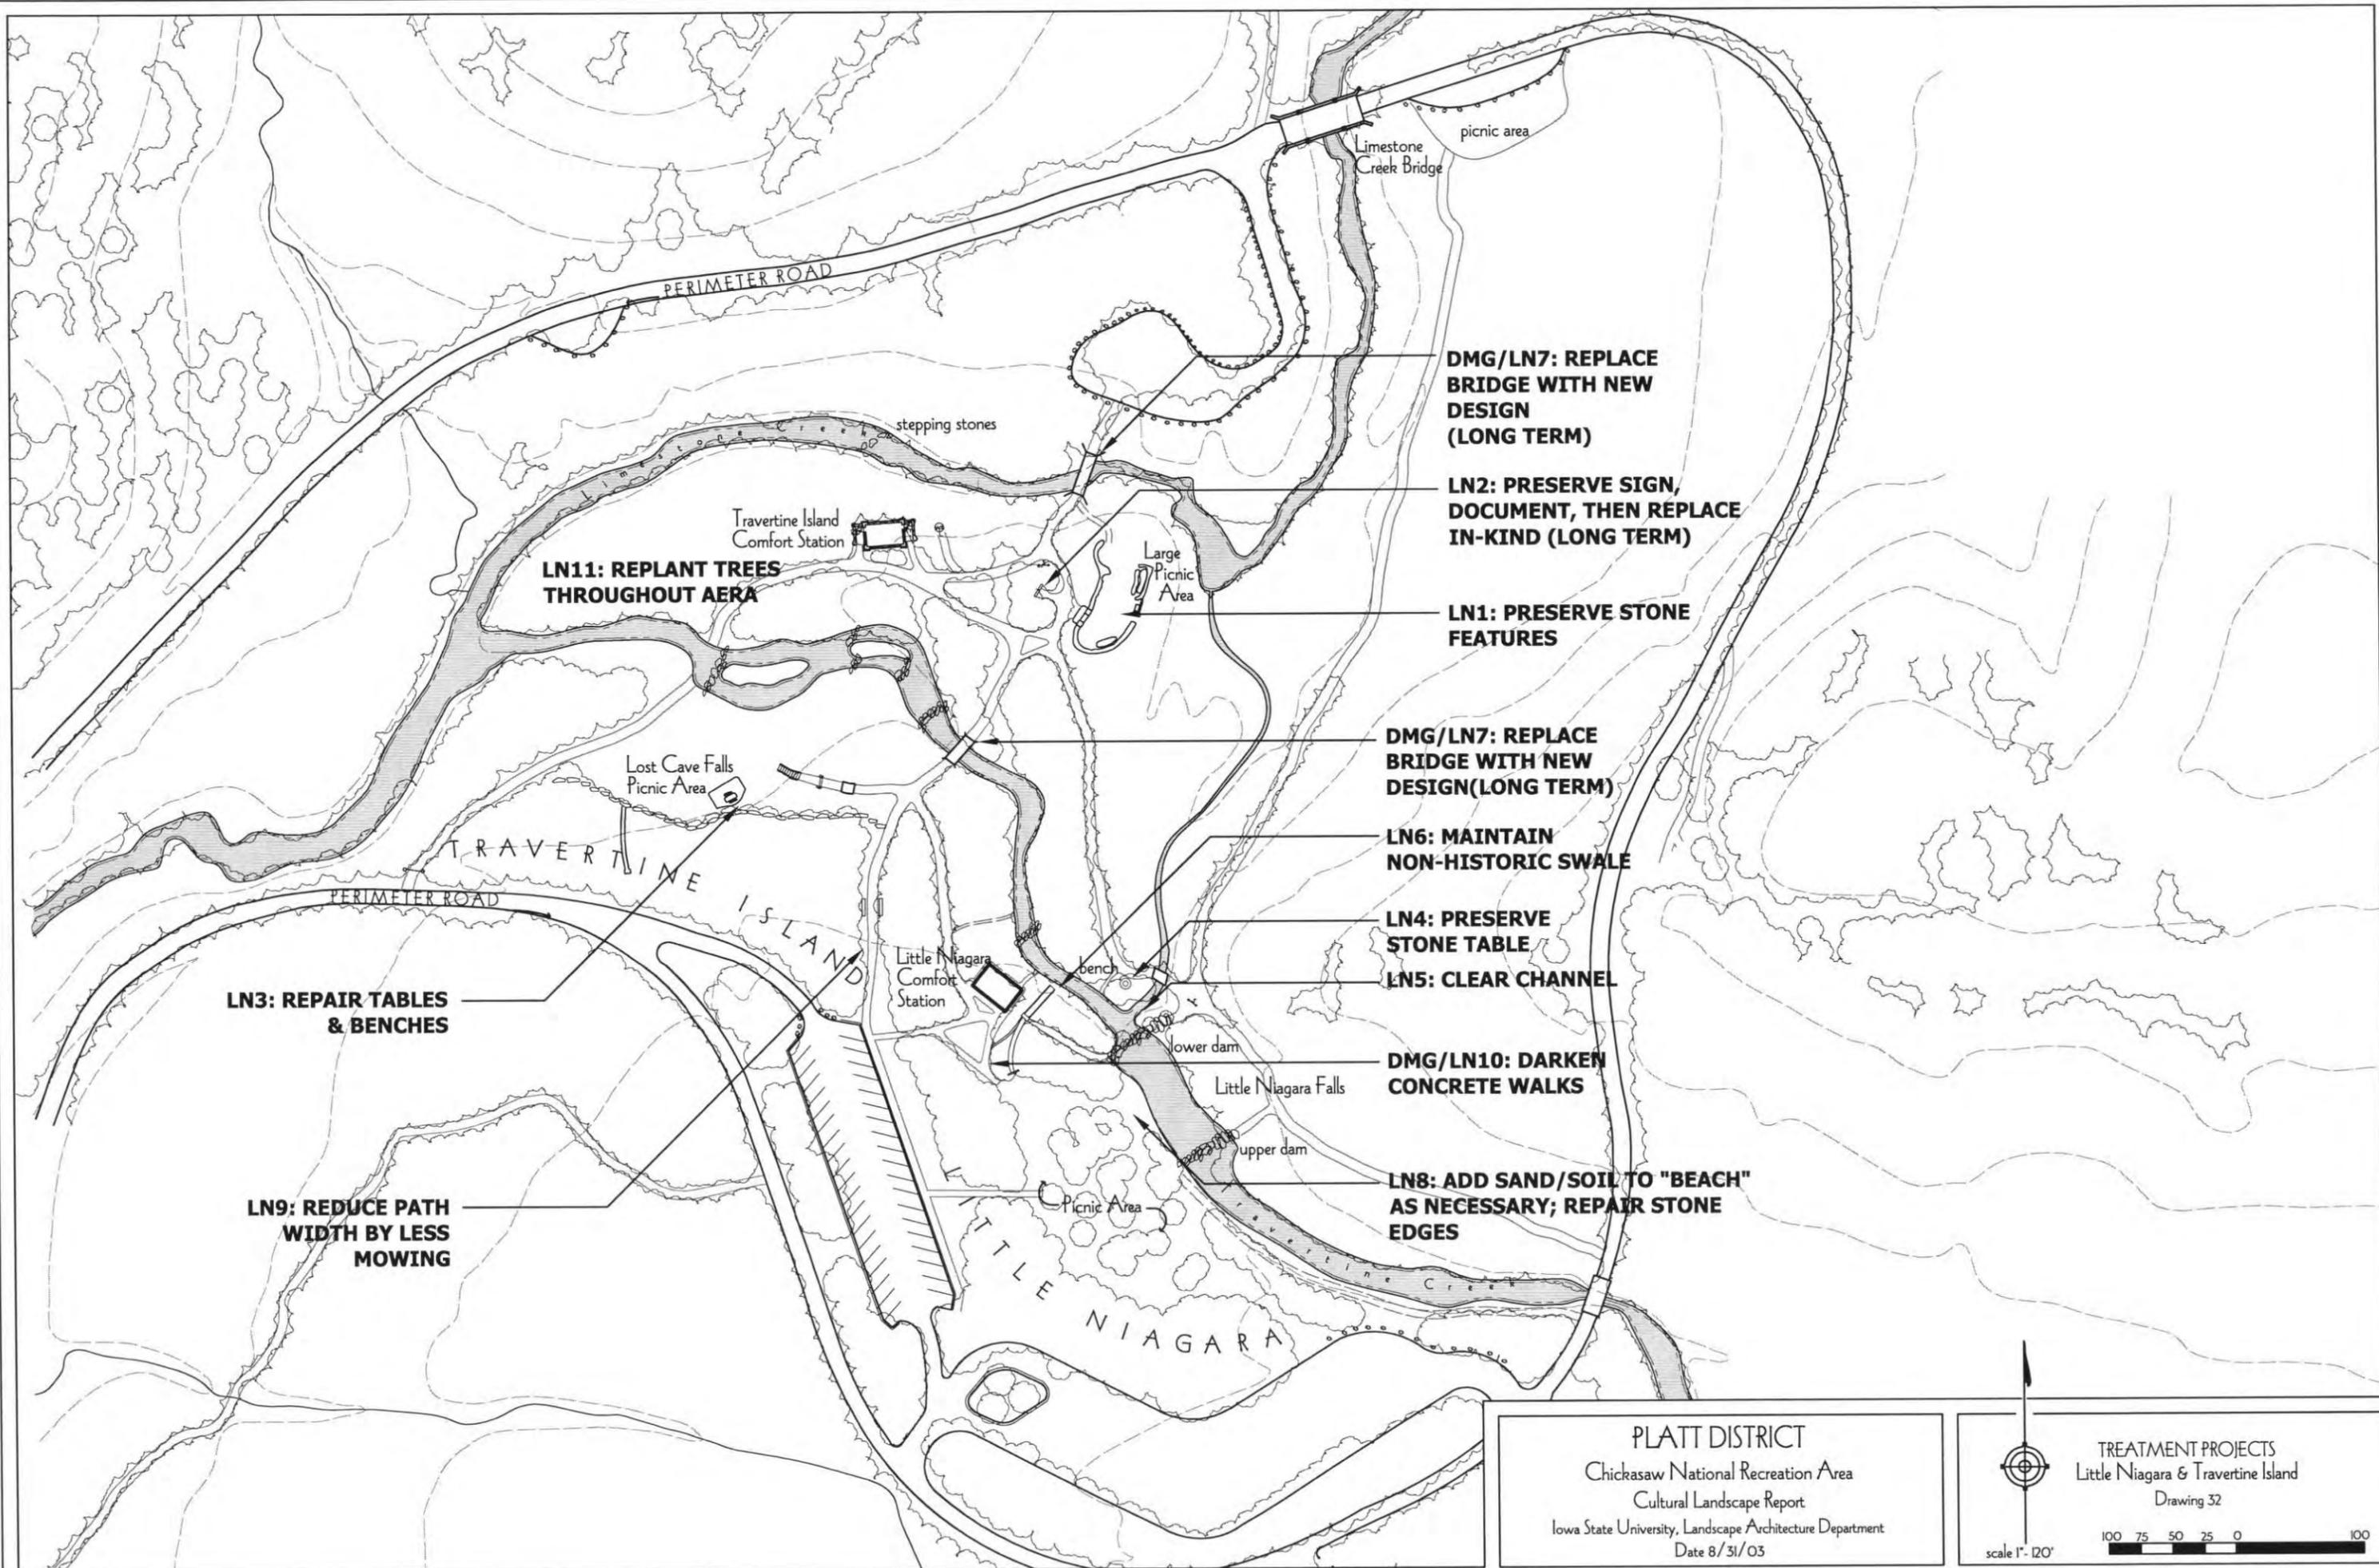

LN11: REPLANT TREES THROUGHOUT AREA

LN3: REPAIR TABLES & BENCHES

LN9: REDUCE PATH WIDTH BY LESS MOWING

DMG/LN7: REPLACE BRIDGE WITH NEW DESIGN (LONG TERM)

LN2: PRESERVE SIGN, DOCUMENT, THEN REPLACE IN-KIND (LONG TERM)

LN1: PRESERVE STONE FEATURES

DMG/LN7: REPLACE BRIDGE WITH NEW DESIGN (LONG TERM)

LN6: MAINTAIN NON-HISTORIC SWALE

LN4: PRESERVE STONE TABLE

LN5: CLEAR CHANNEL


DMG/LN10: DARKEN CONCRETE WALKS

LN8: ADD SAND/SOIL TO "BEACH" AS NECESSARY; REPAIR STONE EDGES

PLATT DISTRICT
 Chickasaw National Recreation Area
 Cultural Landscape Report
 Iowa State University, Landscape Architecture Department
 Date 8/31/03

TREATMENT PROJECTS
 Little Niagara & Travertine Island
 Drawing 32

scale 1" = 120'

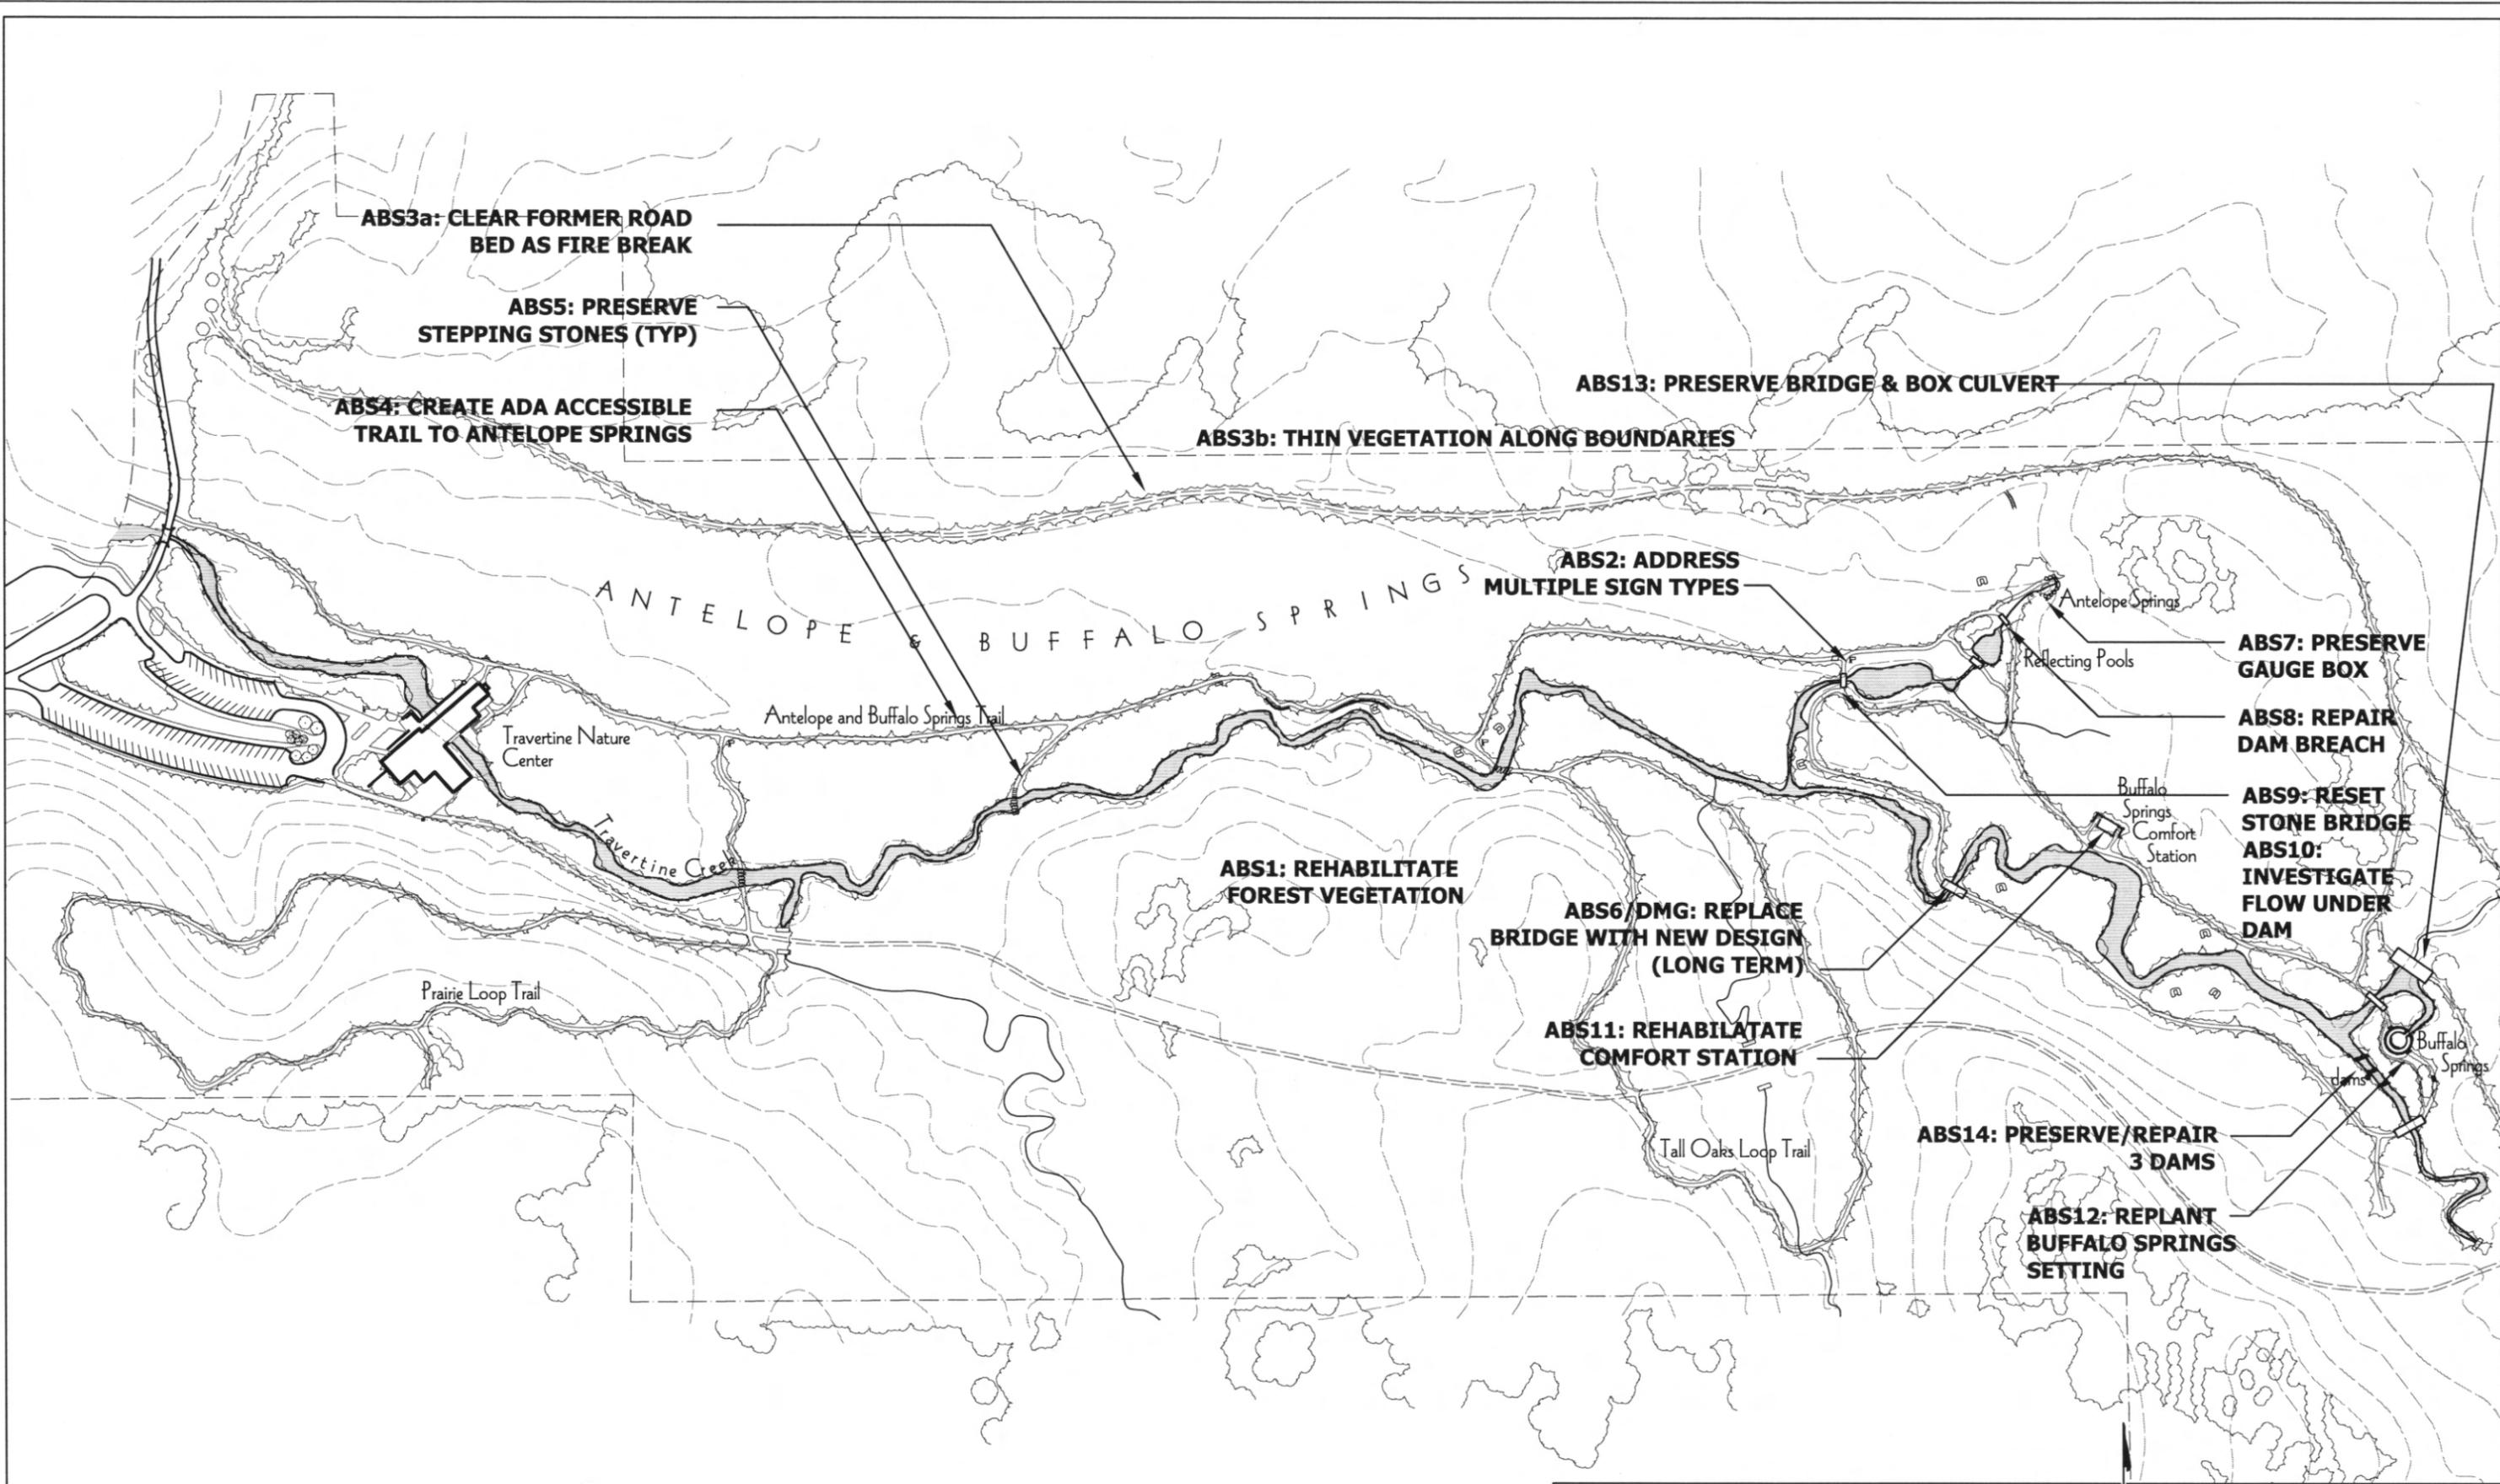

**ABS3a: CLEAR FORMER ROAD
BED AS FIRE BREAK**

**ABS5: PRESERVE
STEPPING STONES (TYP)**

**ABS4: CREATE ADA ACCESSIBLE
TRAIL TO ANTELOPE SPRINGS**

ABS3b: THIN VEGETATION ALONG BOUNDARIES

ABS13: PRESERVE BRIDGE & BOX CULVERT

**ABS2: ADDRESS
MULTIPLE SIGN TYPES**

**ABS7: PRESERVE
GAUGE BOX**

**ABS8: REPAIR
DAM BREACH**

**ABS9: RESET
STONE BRIDGE
ABS10:
INVESTIGATE
FLOW UNDER
DAM**

**ABS1: REHABILITATE
FOREST VEGETATION**

**ABS6/DMG: REPLACE
BRIDGE WITH NEW DESIGN
(LONG TERM)**

**ABS11: REHABILITATE
COMFORT STATION**


**ABS14: PRESERVE/REPAIR
3 DAMS**

**ABS12: REPLANT
BUFFALO SPRINGS
SETTING**

PLATT DISTRICT
Chickasaw National Recreation Area
Cultural Landscape Report
Iowa State University, Landscape Architecture Department
Date 8/31/03

TREATMENT PROJECTS
Antelope Springs & Buffalo Springs
Drawing 33

scale 1" = 250'

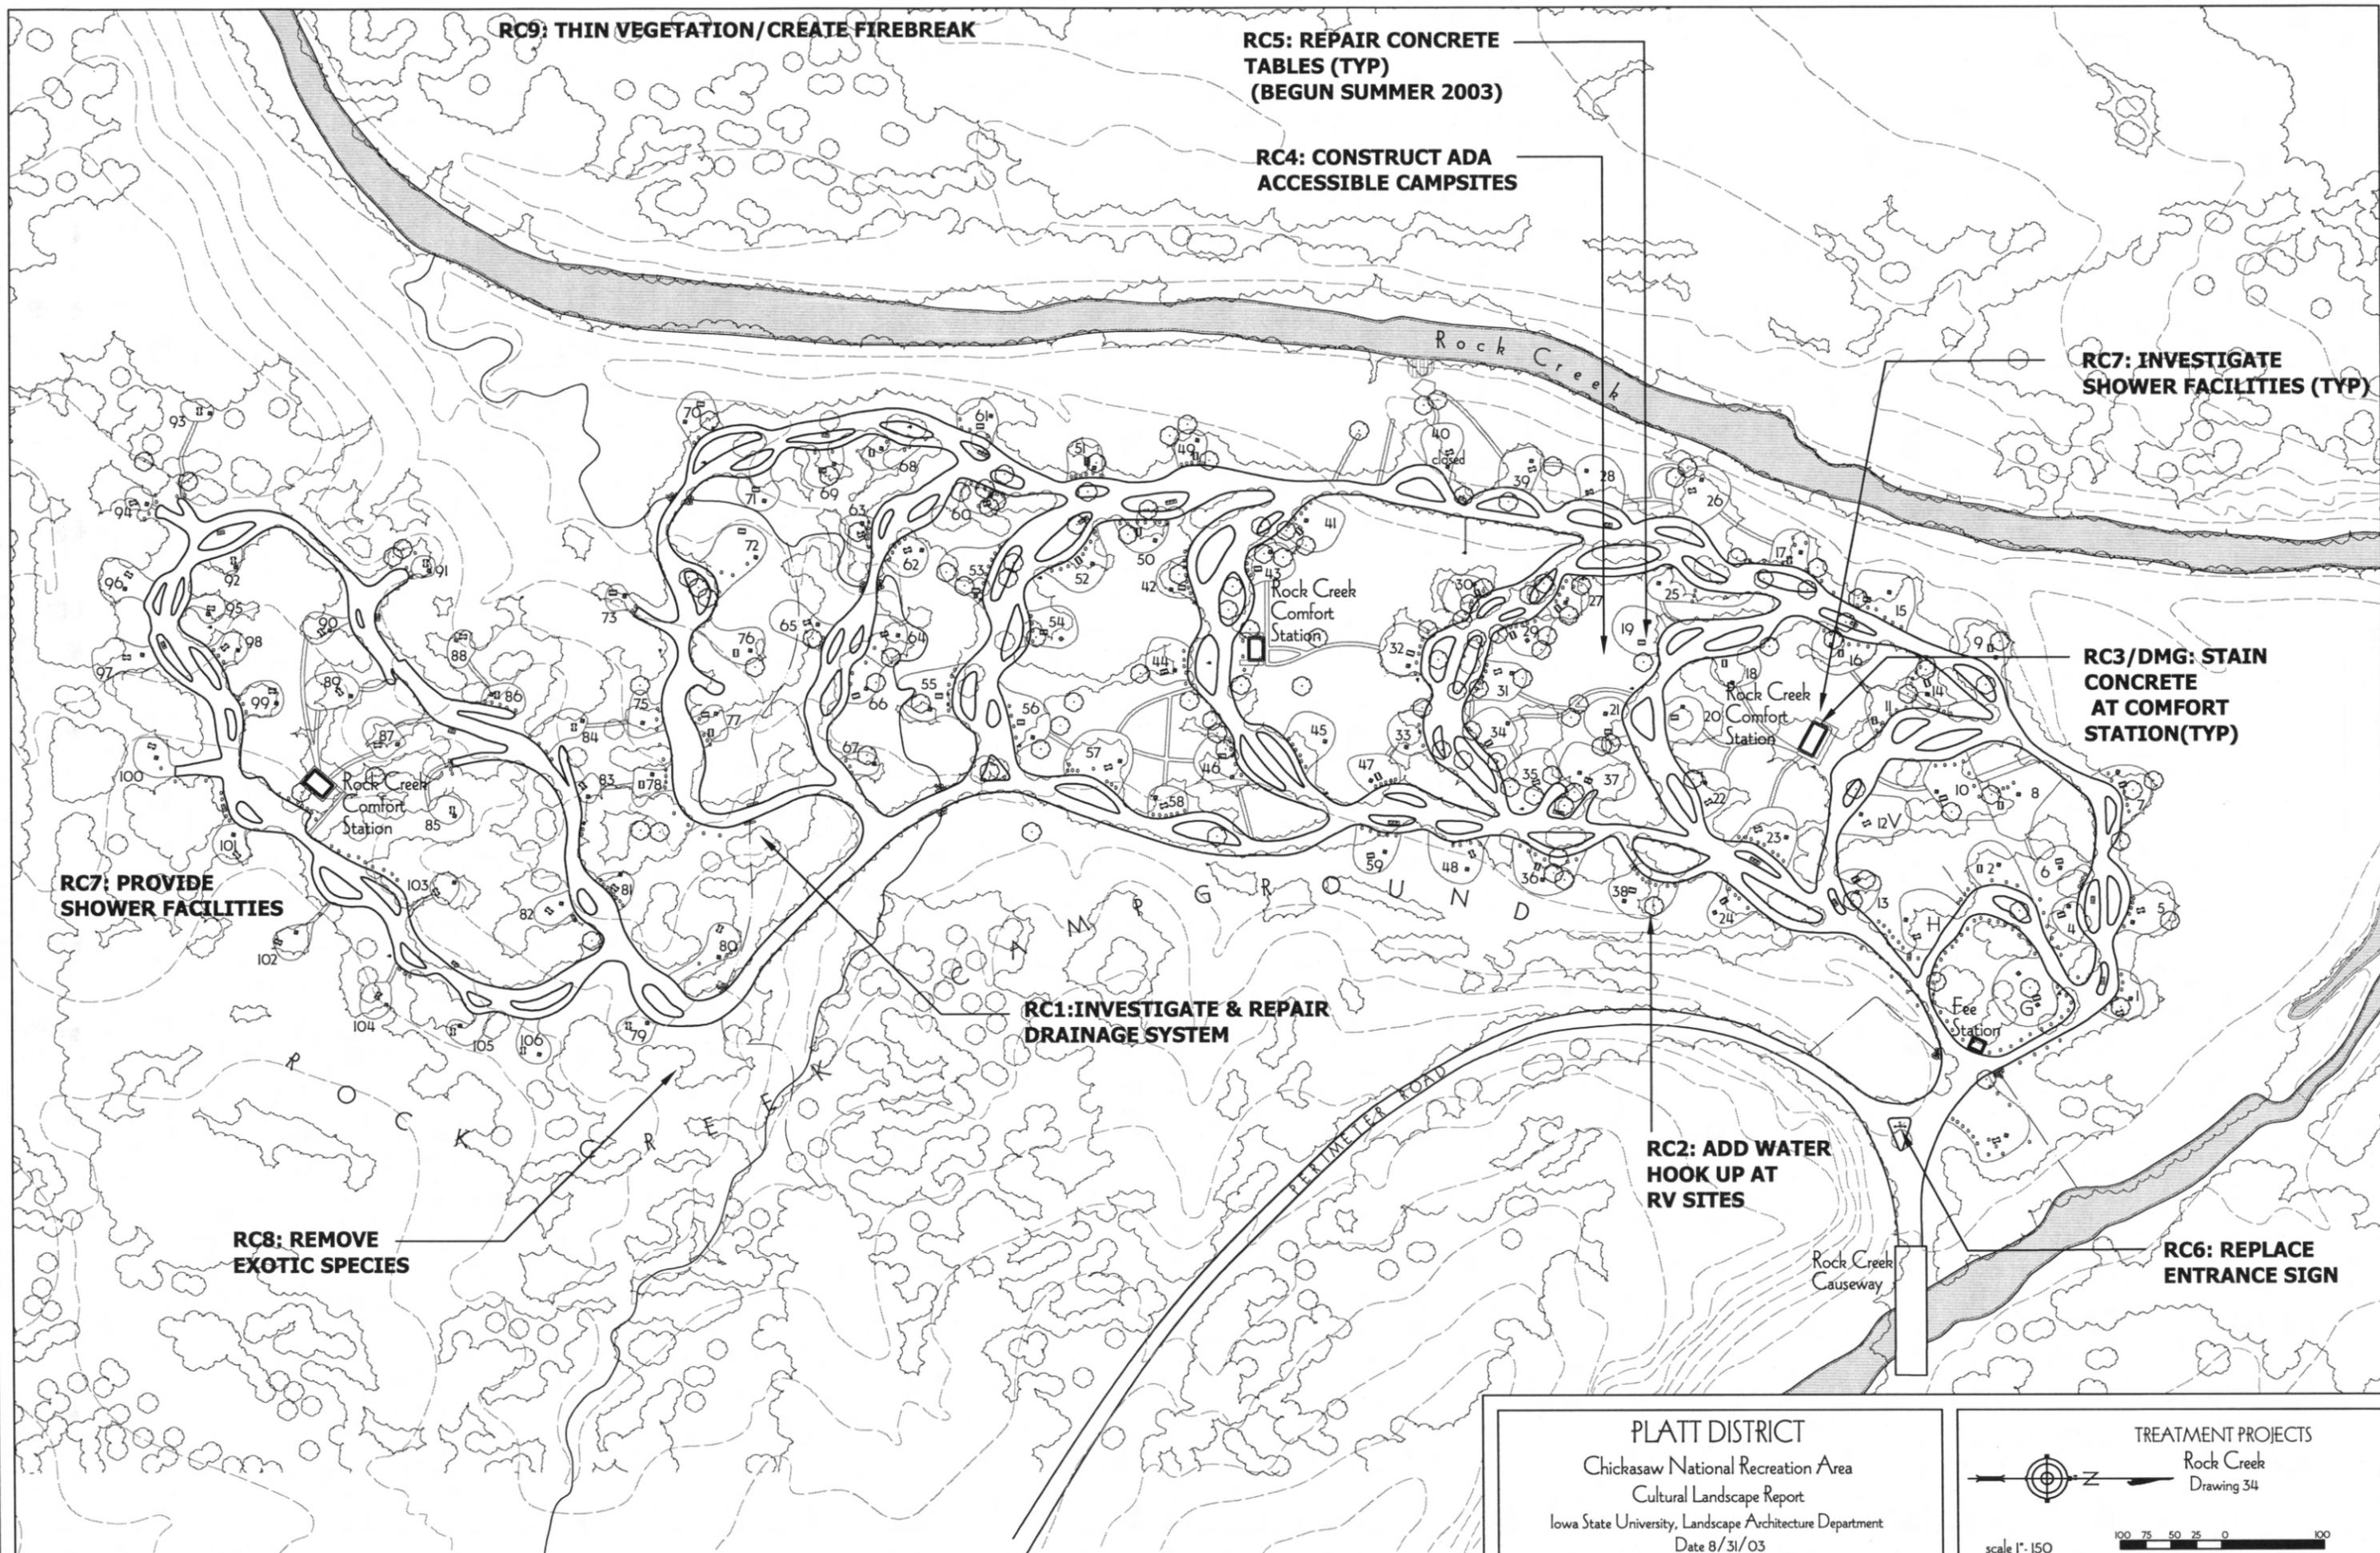

RC9: THIN VEGETATION/CREATE FIREBREAK

RC5: REPAIR CONCRETE TABLES (TYP) (BEGUN SUMMER 2003)

RC4: CONSTRUCT ADA ACCESSIBLE CAMPSITES

RC7: INVESTIGATE SHOWER FACILITIES (TYP)

RC3/DMG: STAIN CONCRETE AT COMFORT STATION(TYP)

RC7: PROVIDE SHOWER FACILITIES


RC1: INVESTIGATE & REPAIR DRAINAGE SYSTEM


RC2: ADD WATER HOOK UP AT RV SITES

RC8: REMOVE EXOTIC SPECIES

RC6: REPLACE ENTRANCE SIGN

PLATT DISTRICT
 Chickasaw National Recreation Area
 Cultural Landscape Report
 Iowa State University, Landscape Architecture Department
 Date 8/31/03

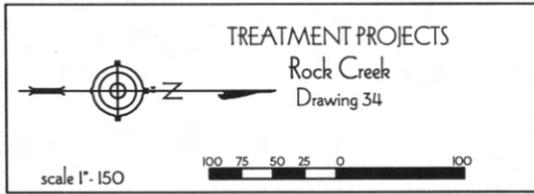


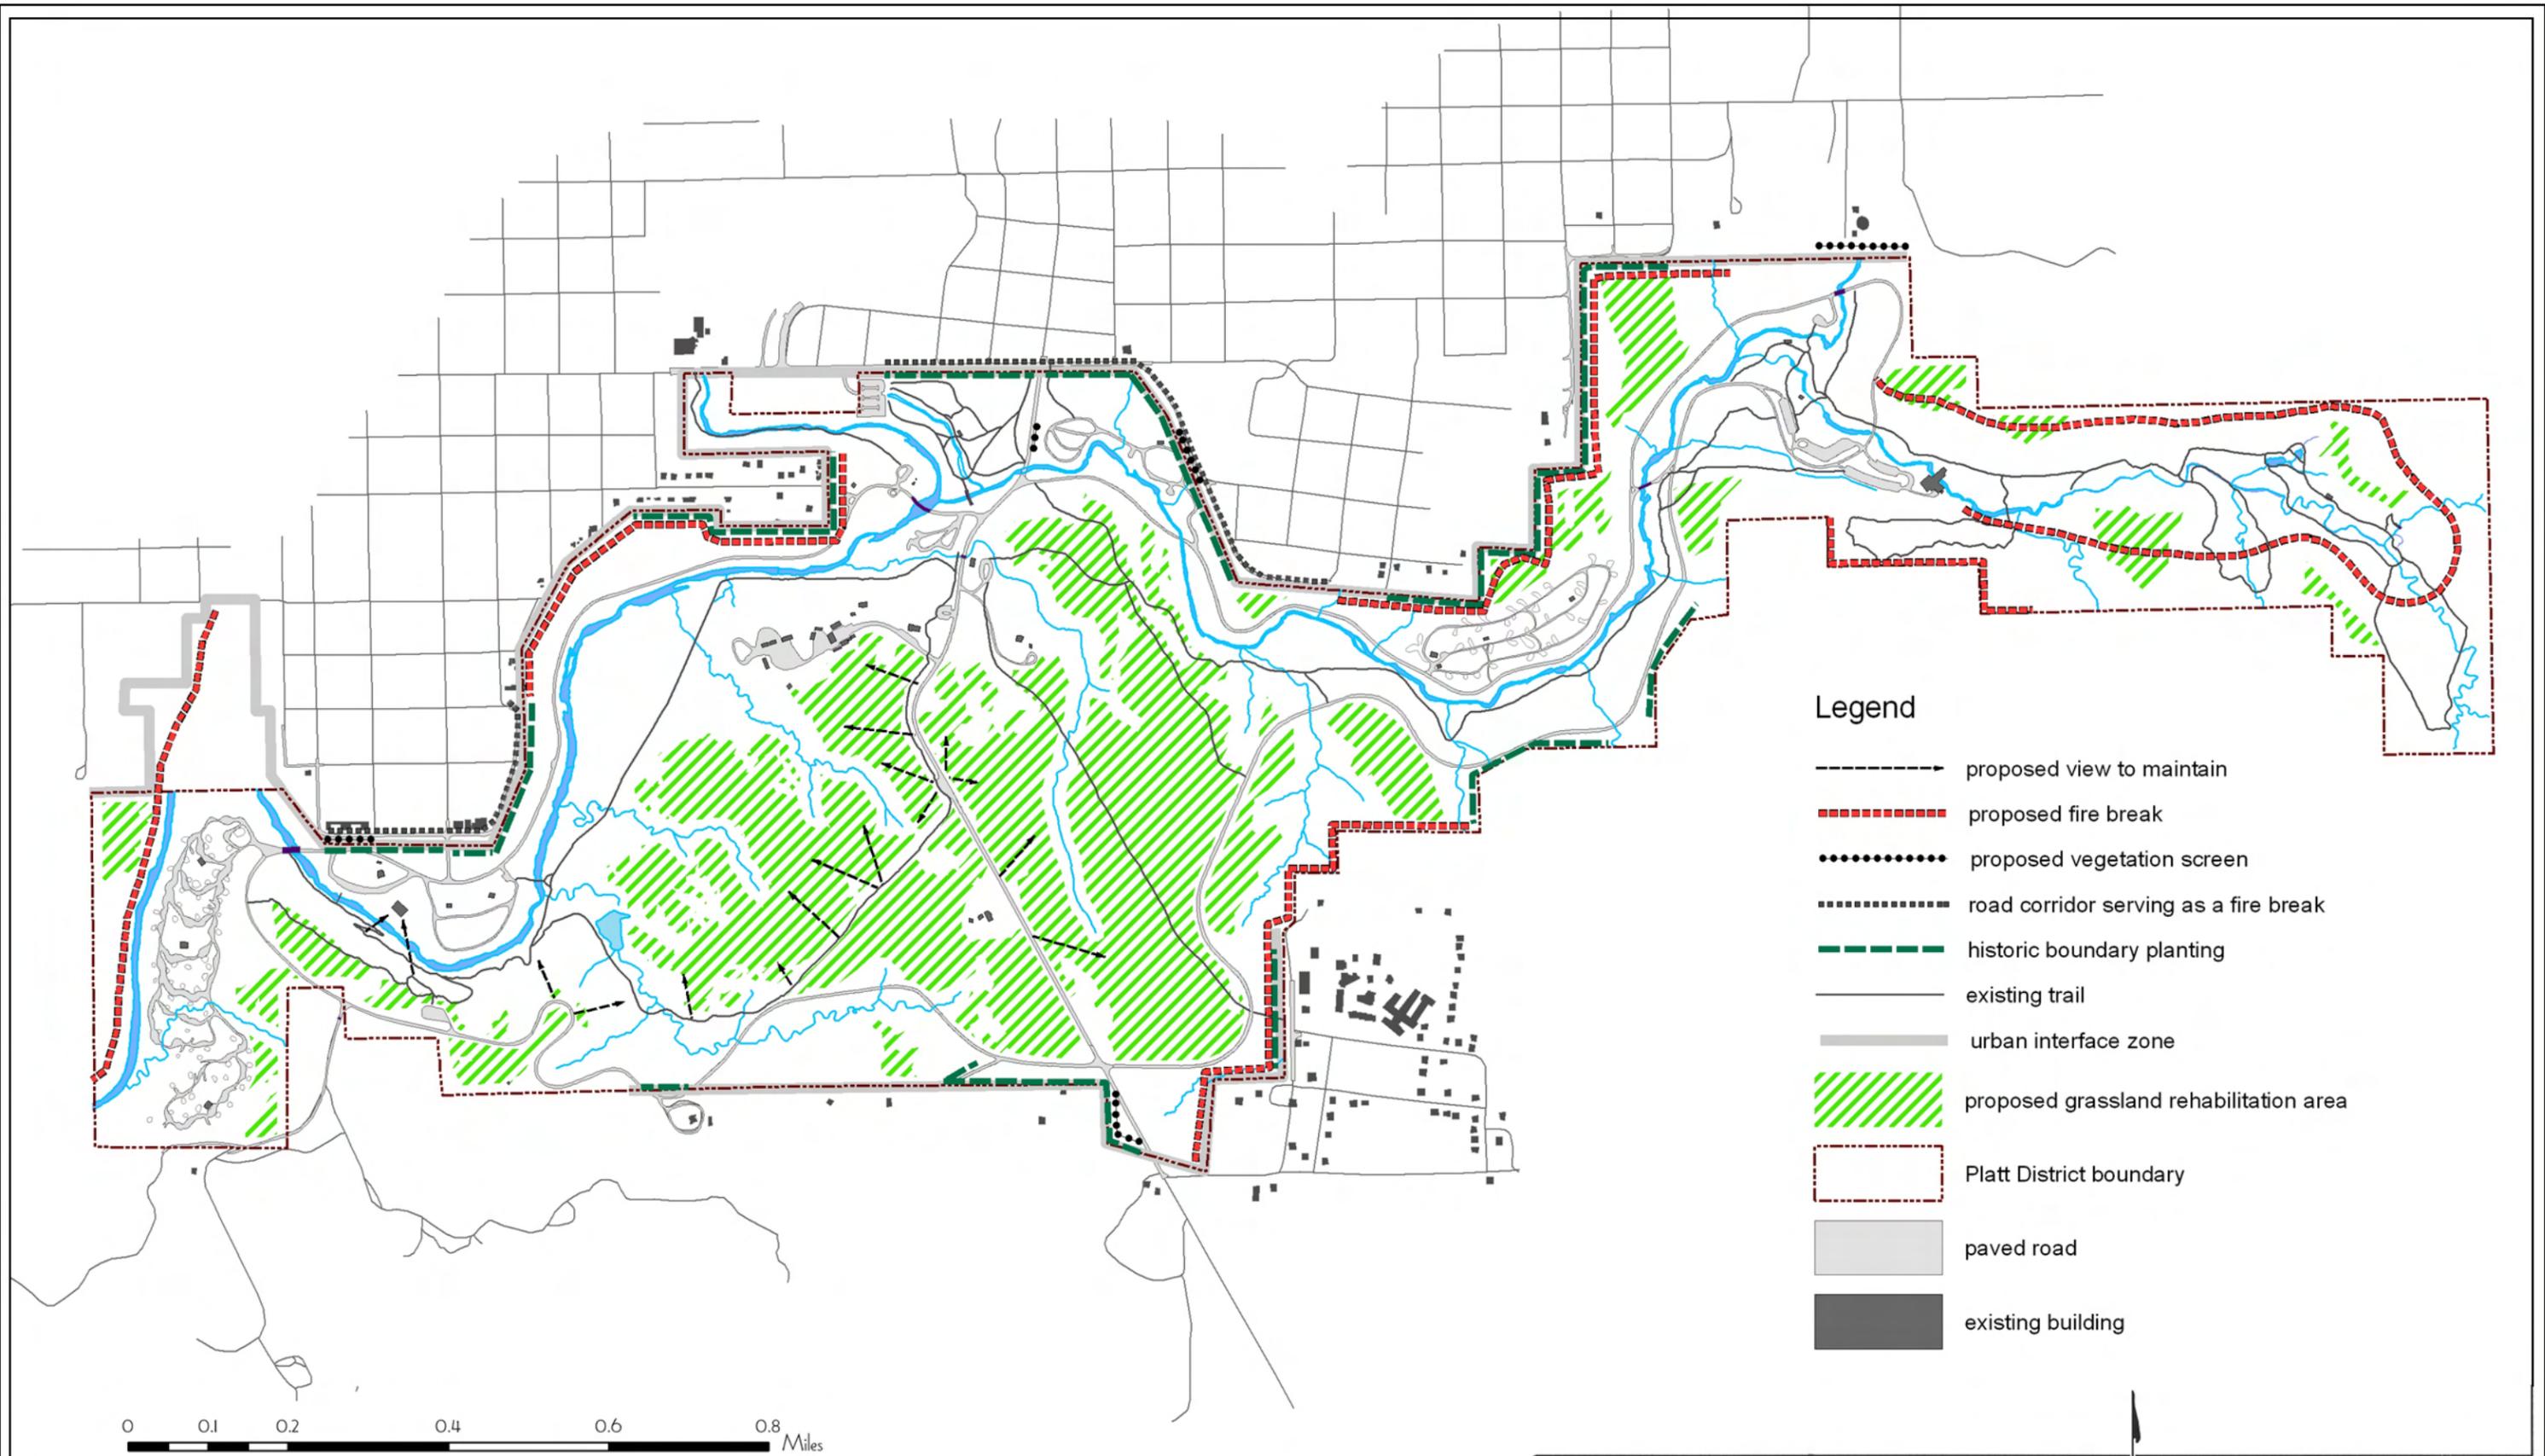


Legend

- > proposed view to maintain
- proposed fire break
- proposed vegetation screen
- road corridor serving as a fire break
- historic boundary planting
- existing trail
- urban interface zone
- proposed grassland rehabilitation area
- Platt District boundary
- paved road
- existing building

PLATT DISTRICT
 Chickasaw National Recreation Area
 Cultural Landscape Report
 Iowa State University, Landscape Architecture Department
 Date 08/31/03

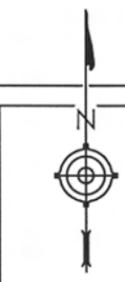

Proposed Overall
 Vegetation Management Plan
 Drawing 35

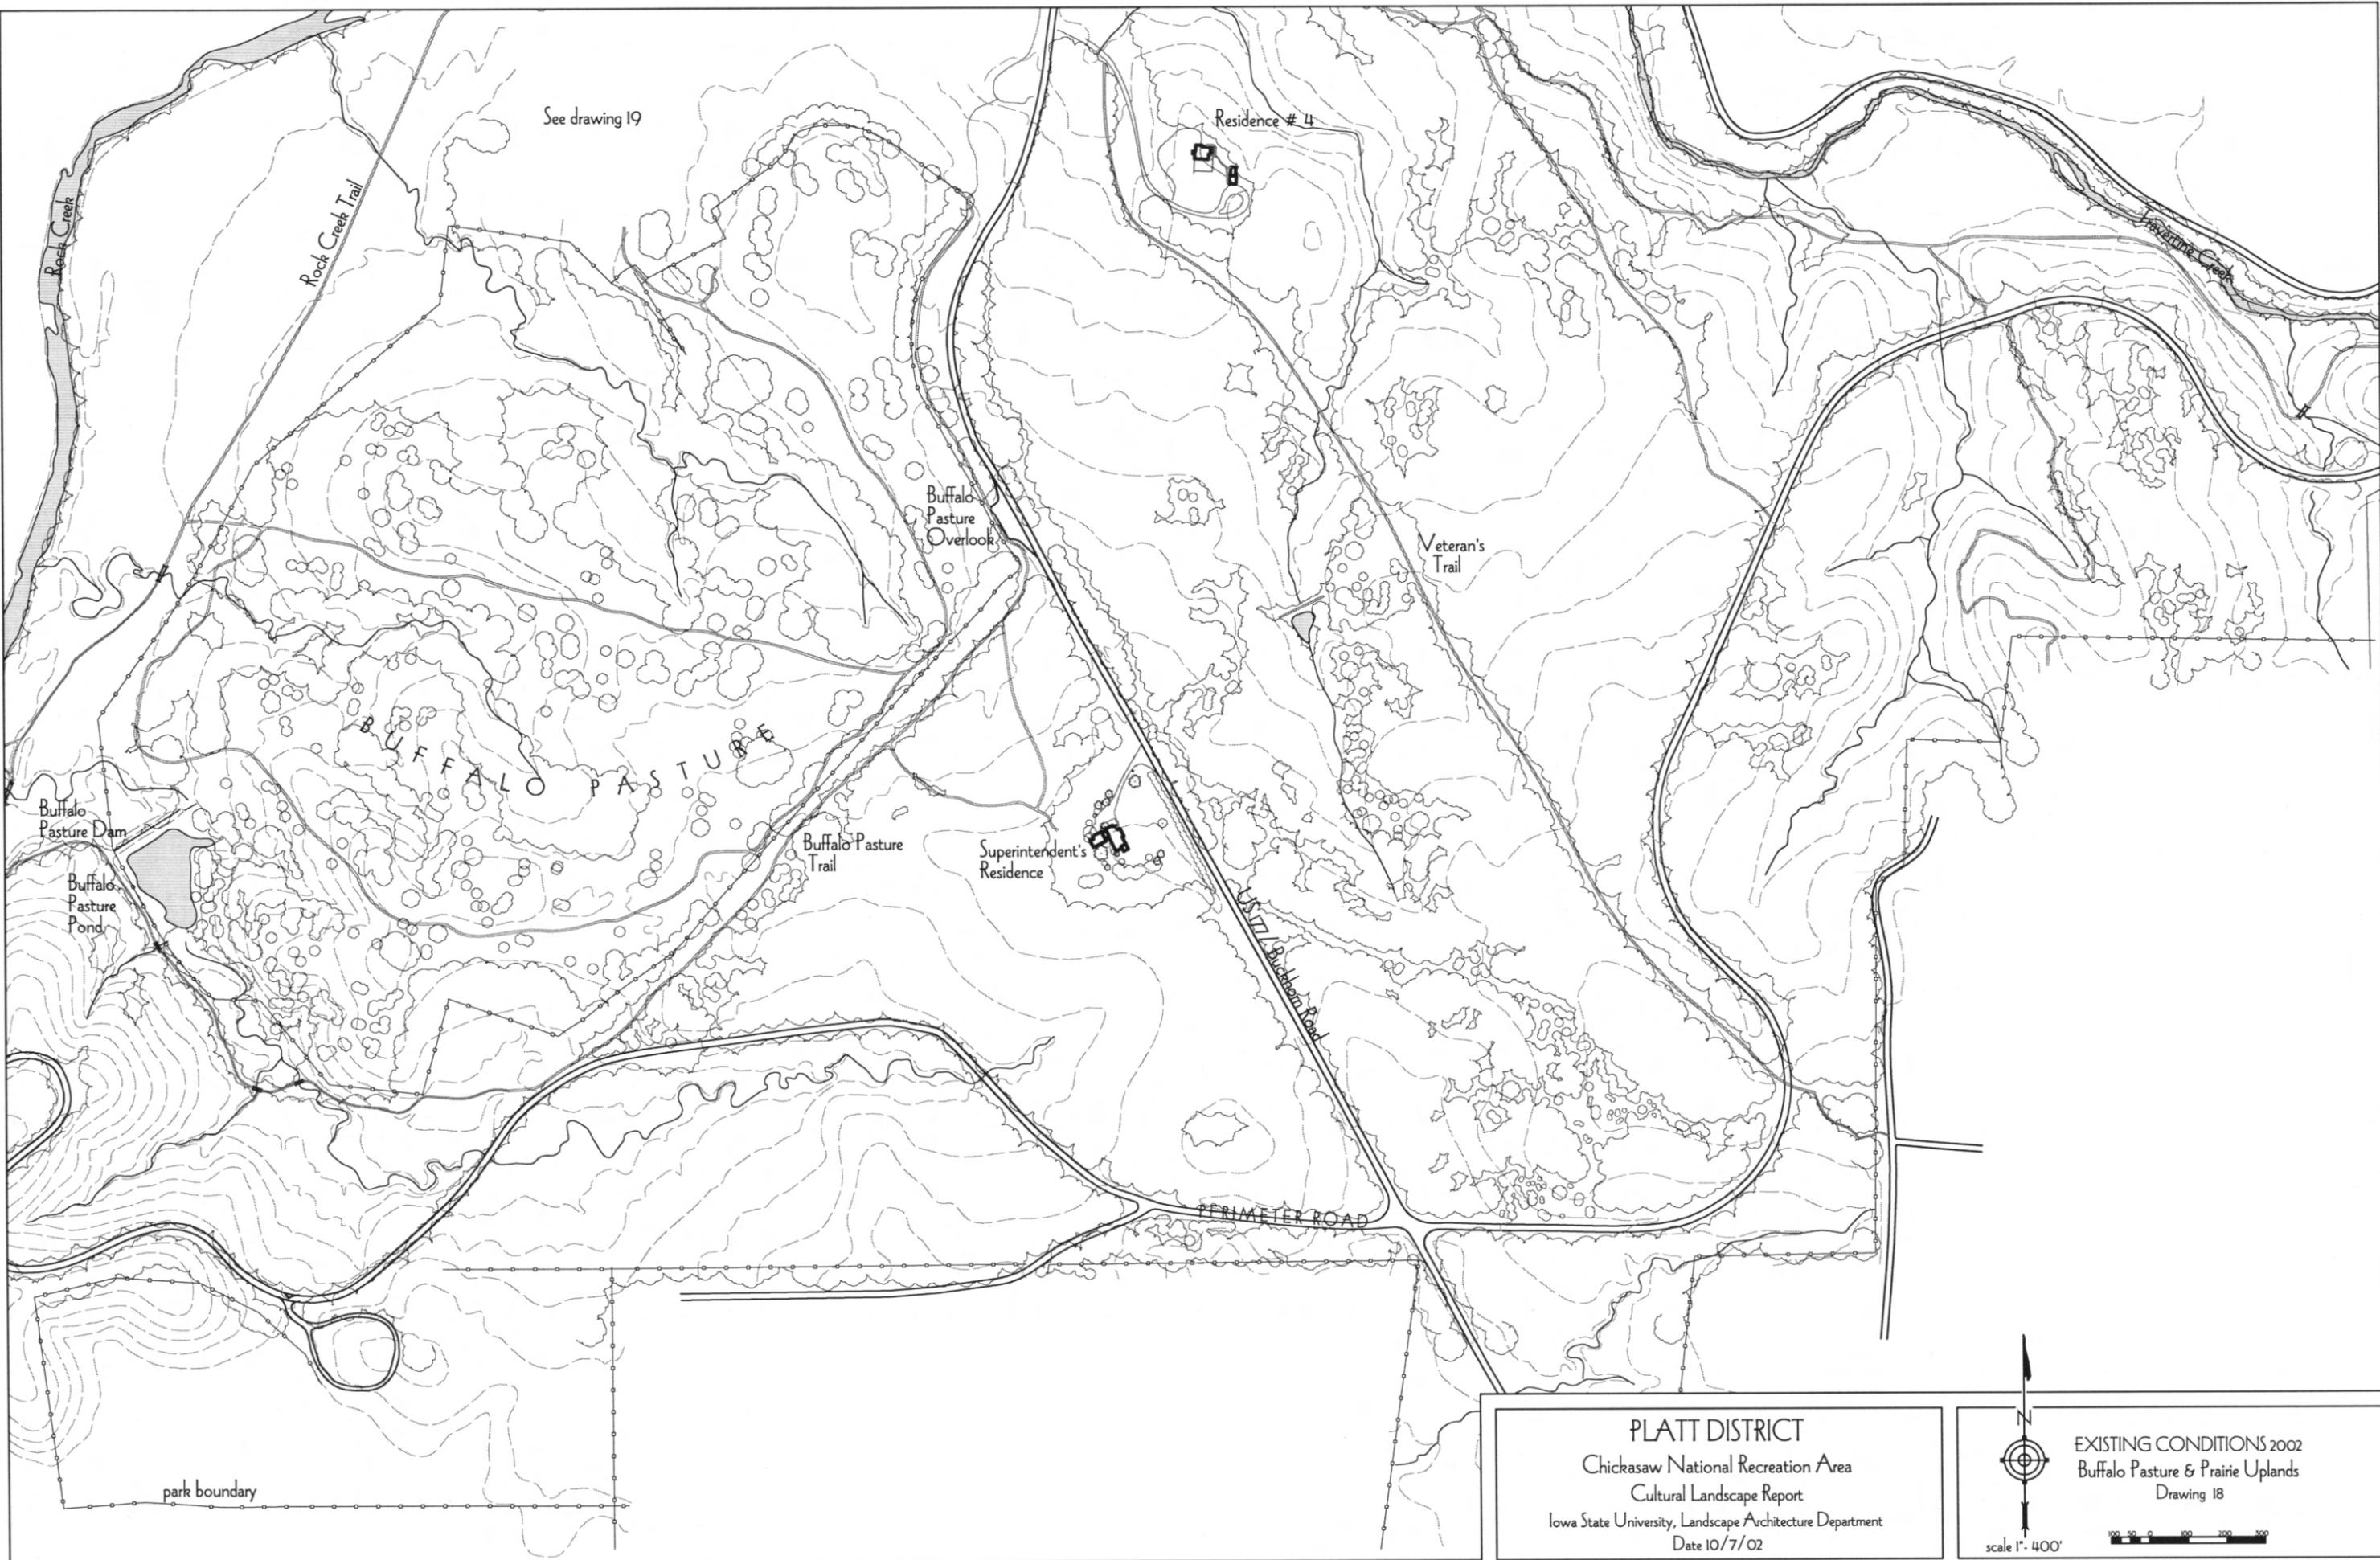


See drawing 19


PLATT DISTRICT
Chickasaw National Recreation Area
Cultural Landscape Report
Iowa State University, Landscape Architecture Department
Date 10/7/02

EXISTING CONDITIONS 2002
Buffalo Pasture & Prairie Uplands
Drawing 18

scale 1" = 400'

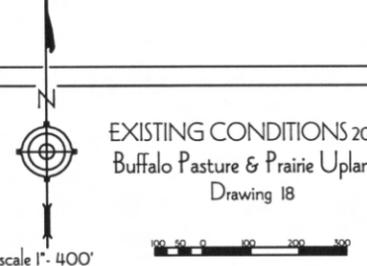

park boundary

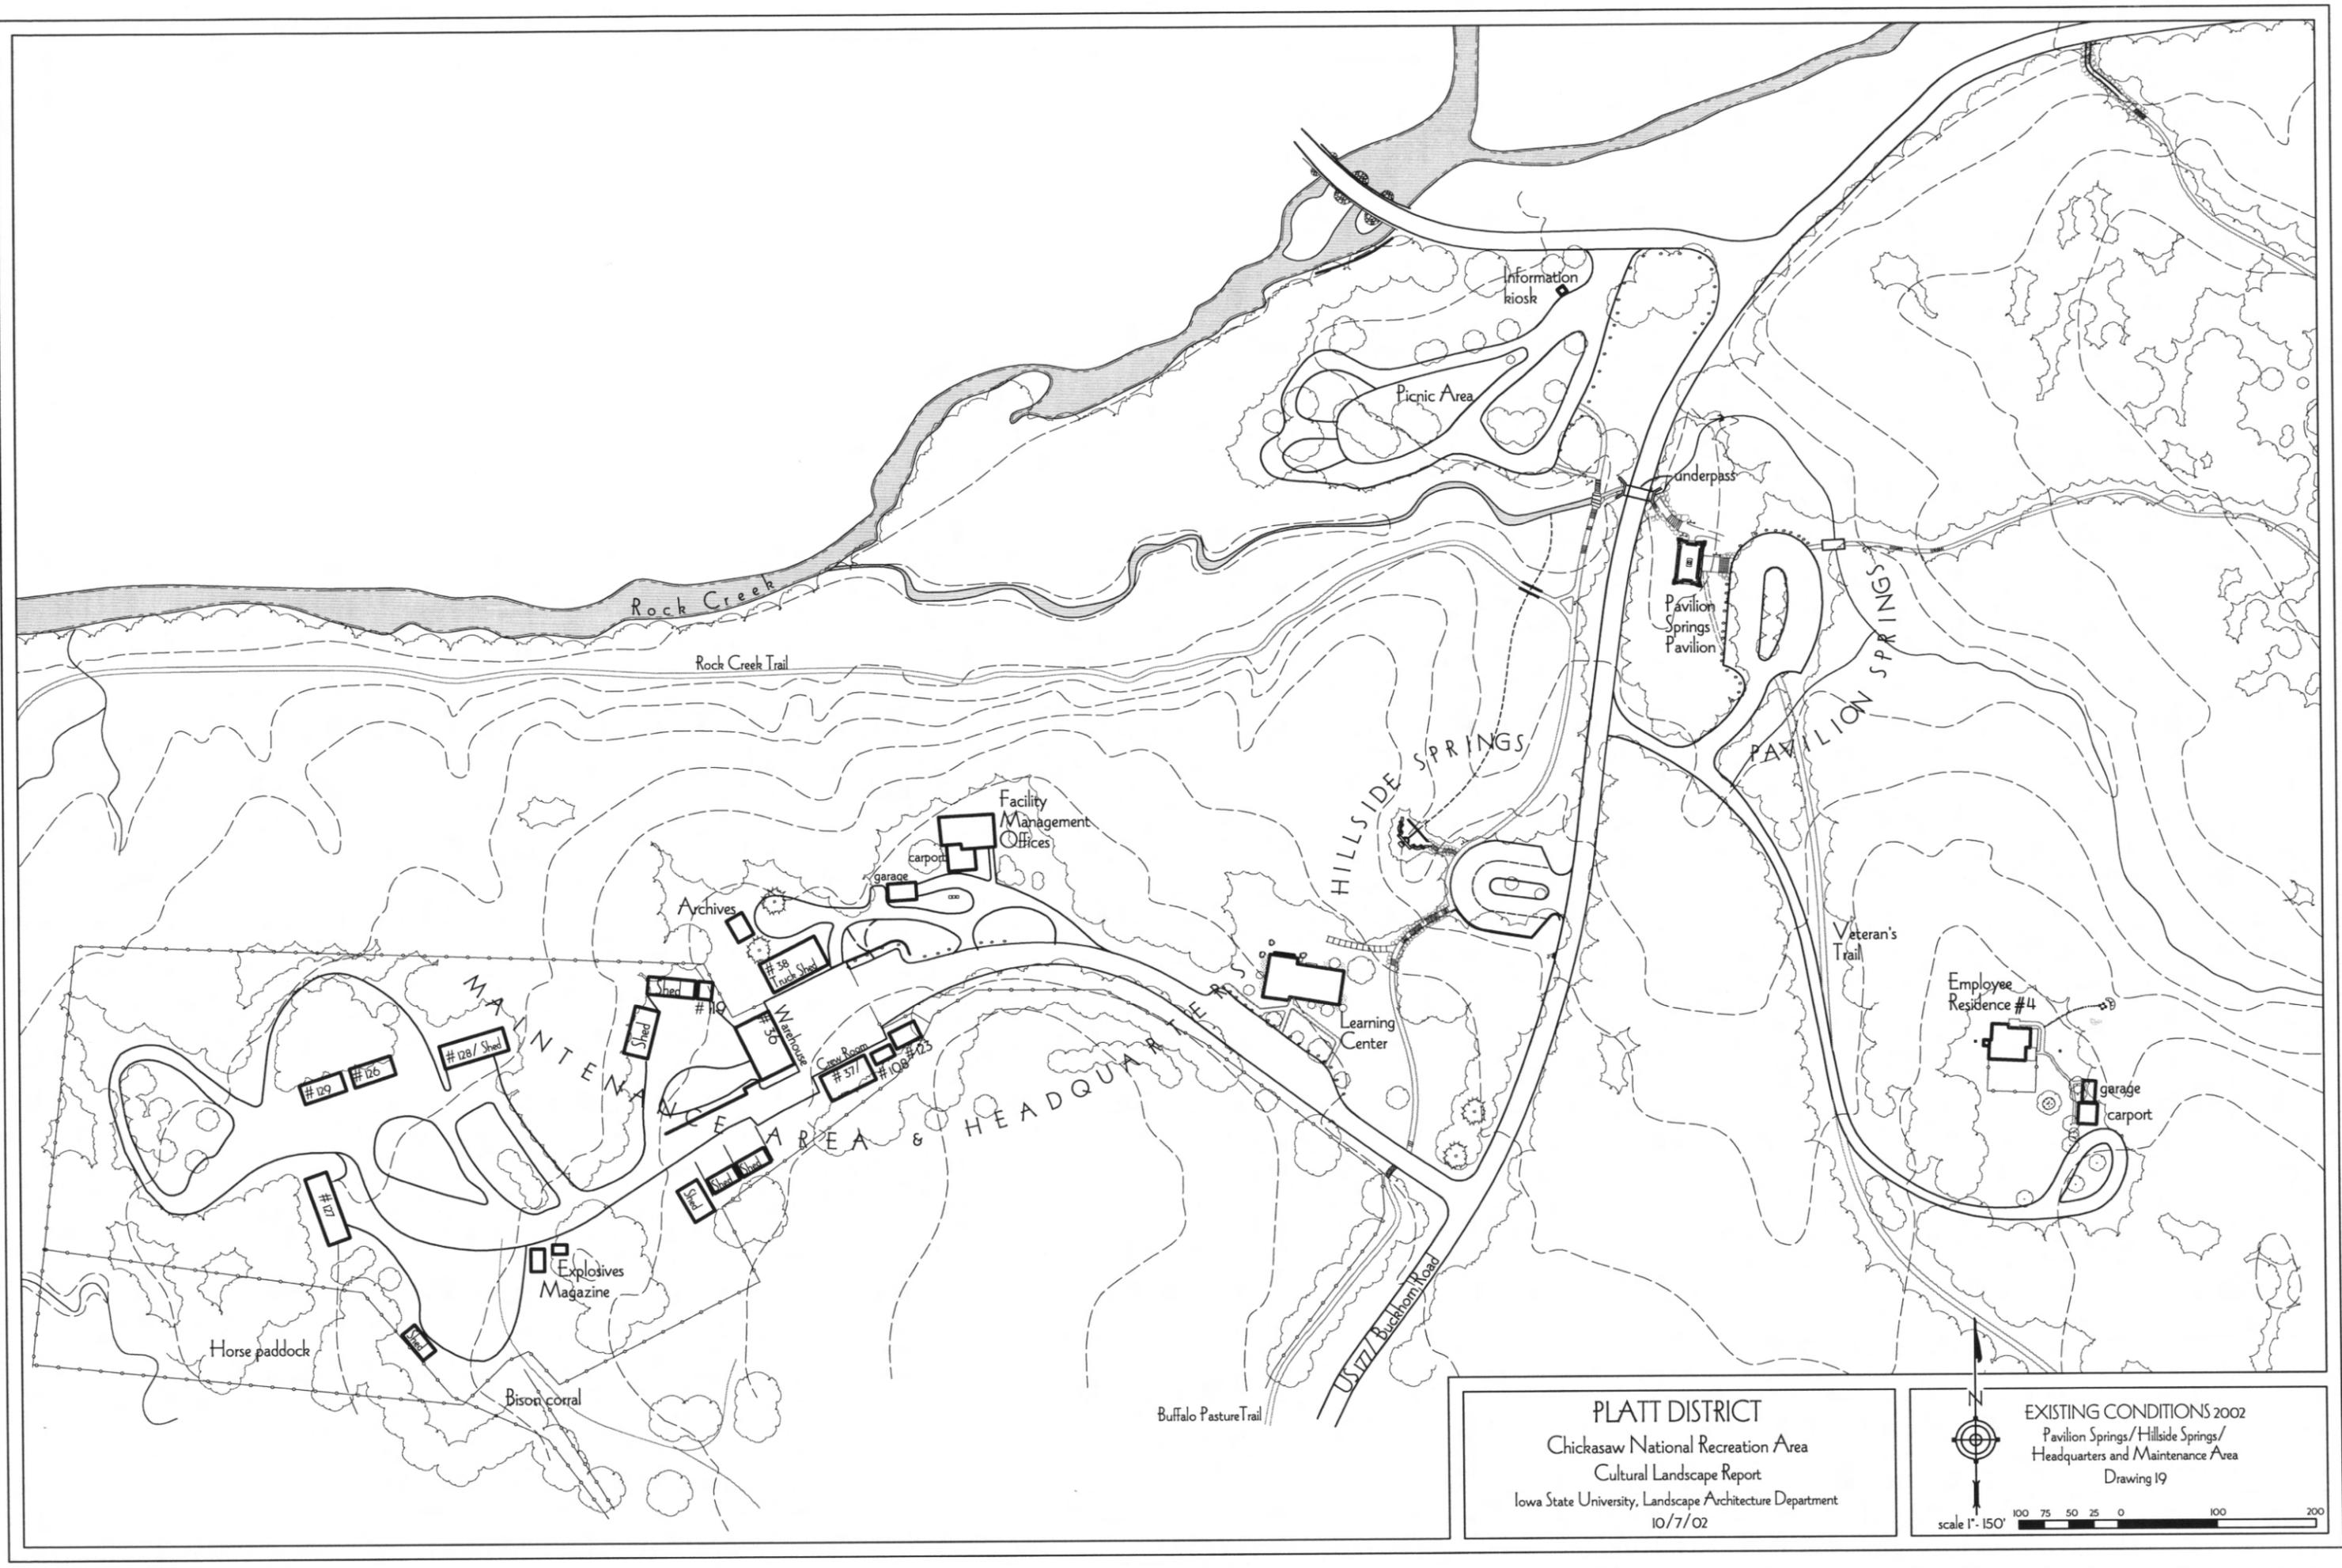

PLATT DISTRICT
 Chickasaw National Recreation Area
 Cultural Landscape Report
 Iowa State University, Landscape Architecture Department
 10/7/02


EXISTING CONDITIONS 2002
 Pavilion Springs/Hillside Springs/
 Headquarters and Maintenance Area
 Drawing 19


scale 1" = 150'

100 75 50 25 0 100 200



PLATT DISTRICT
 Chickasaw National Recreation Area
 Cultural Landscape Report
 Iowa State University, Landscape Architecture Department
 Date 10/7/02

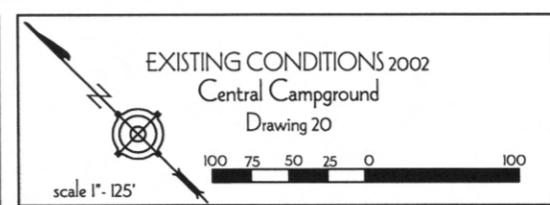

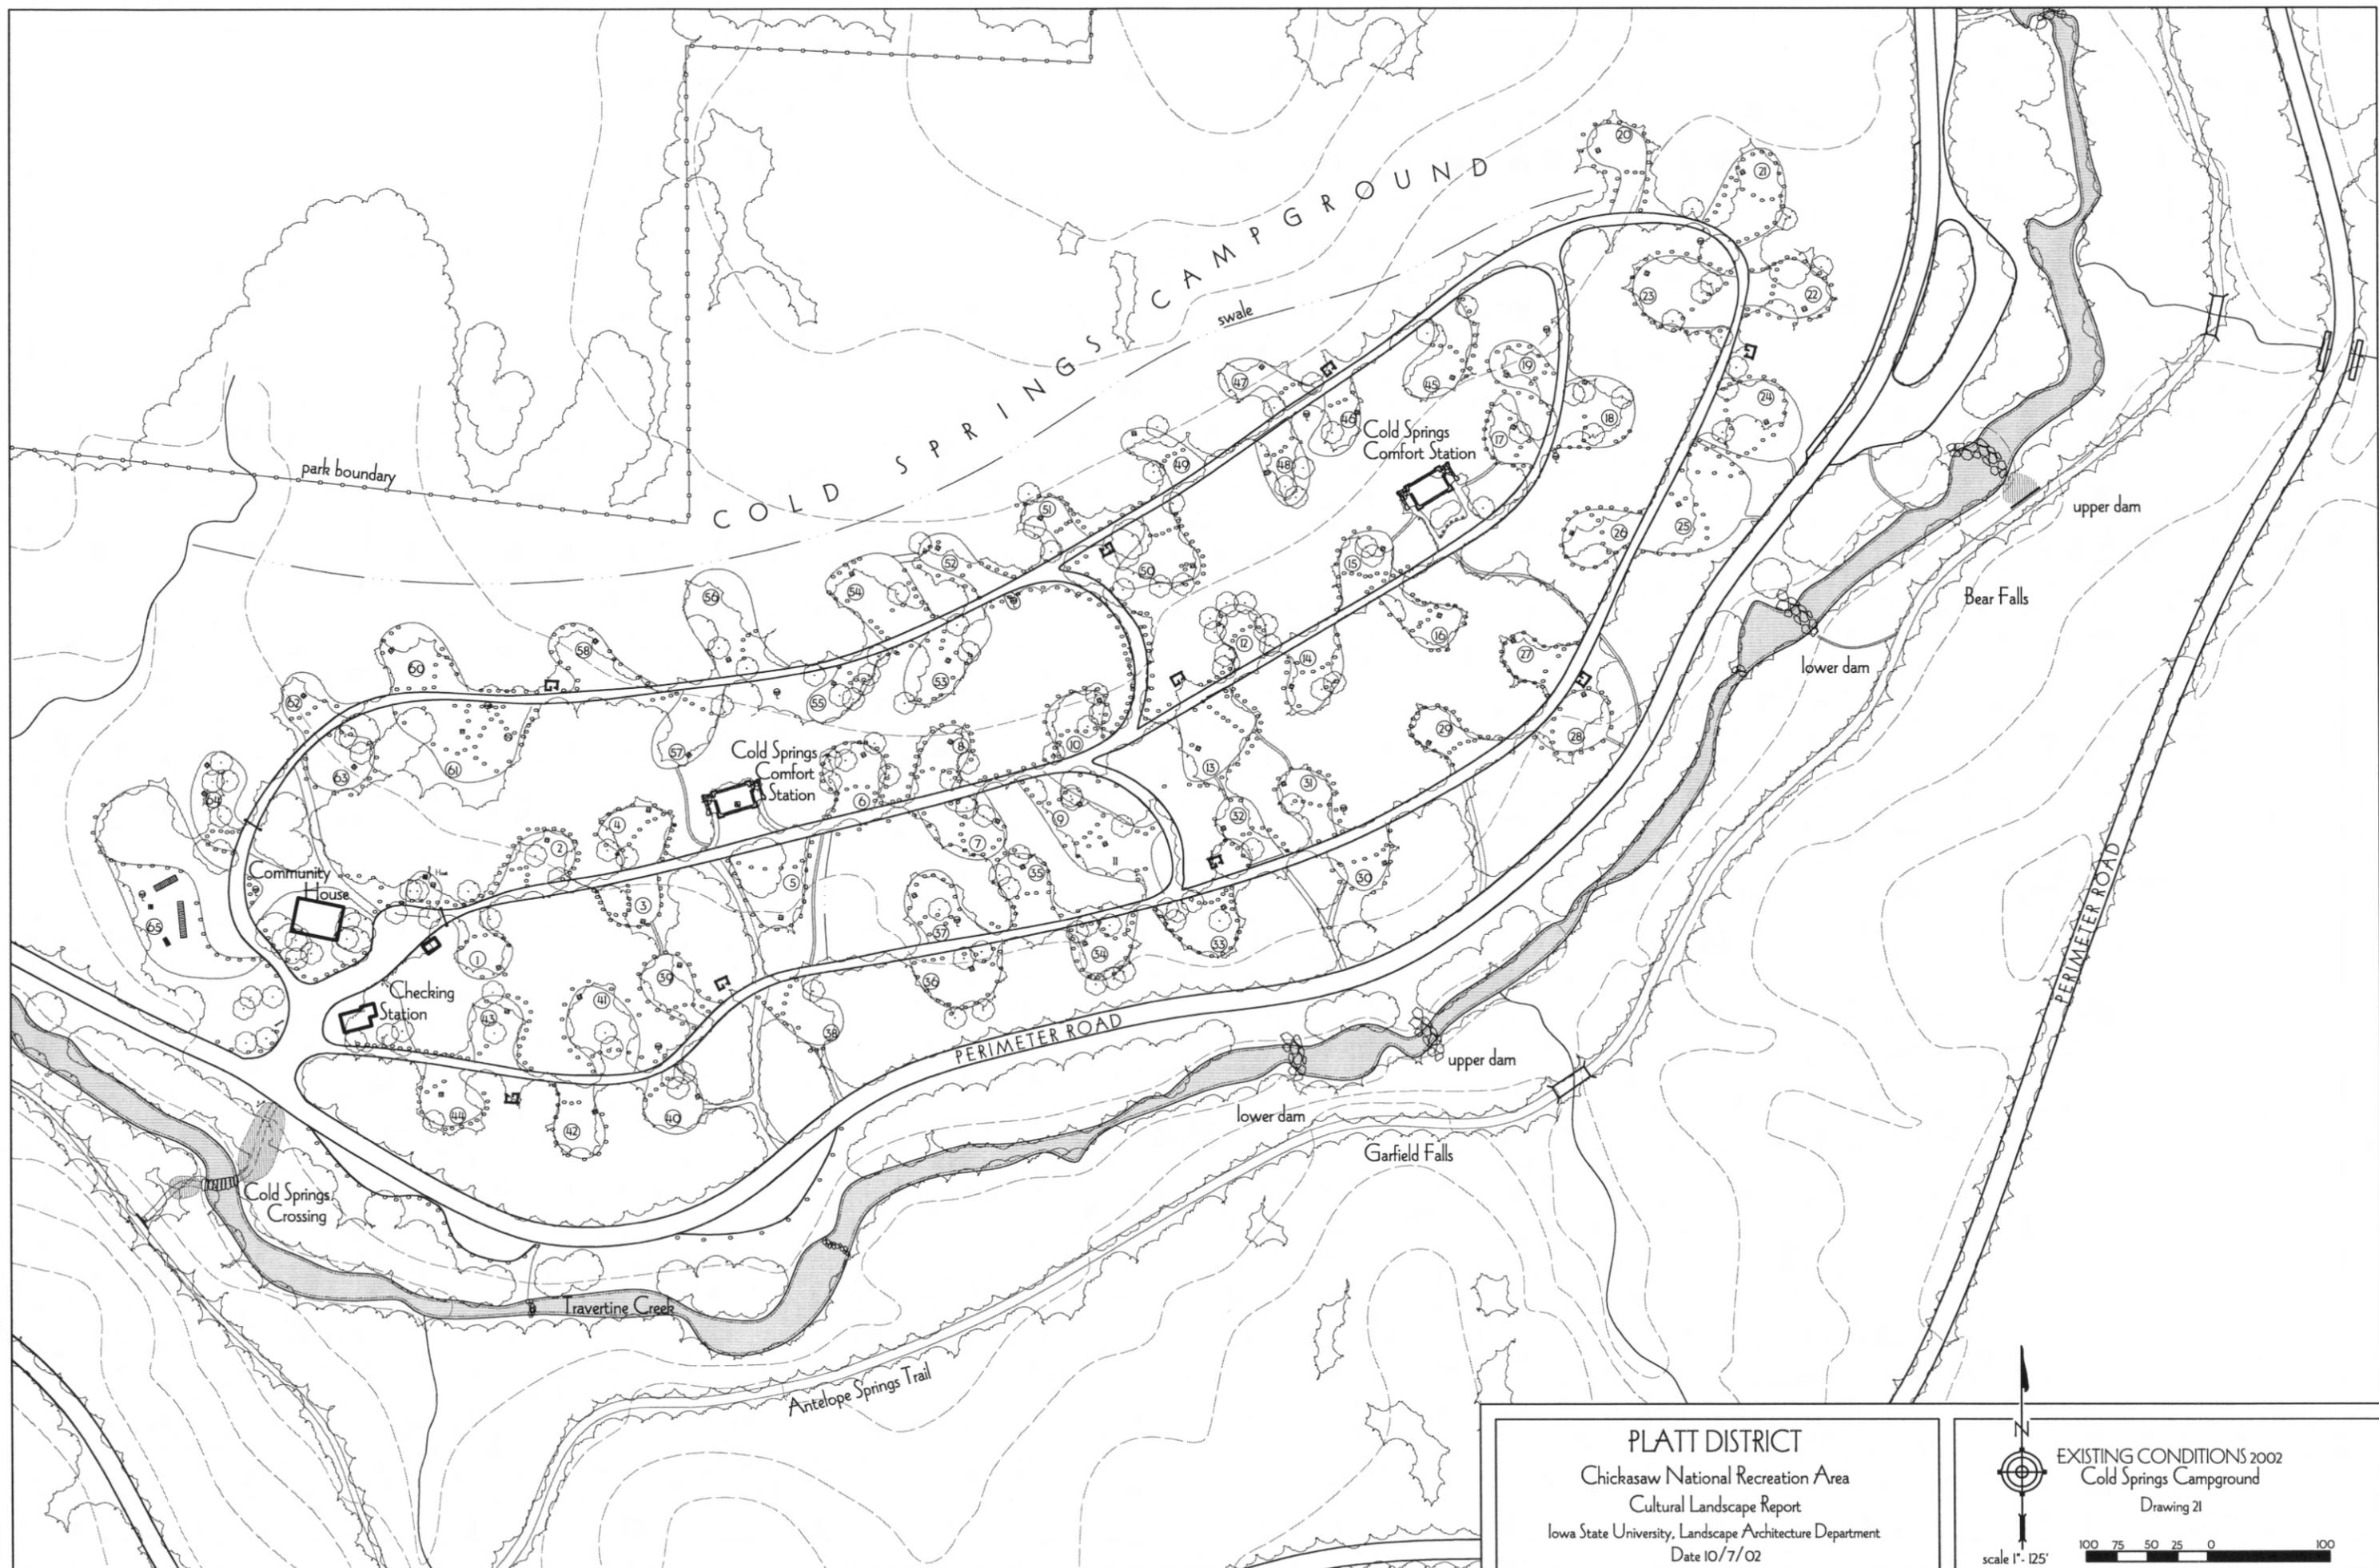


PLATT DISTRICT
 Chickasaw National Recreation Area
 Cultural Landscape Report
 Iowa State University, Landscape Architecture Department
 Date 10/7/02

EXISTING CONDITIONS 2002
 Cold Springs Campground
 Drawing 21

scale 1" = 125'

100 75 50 25 0 100

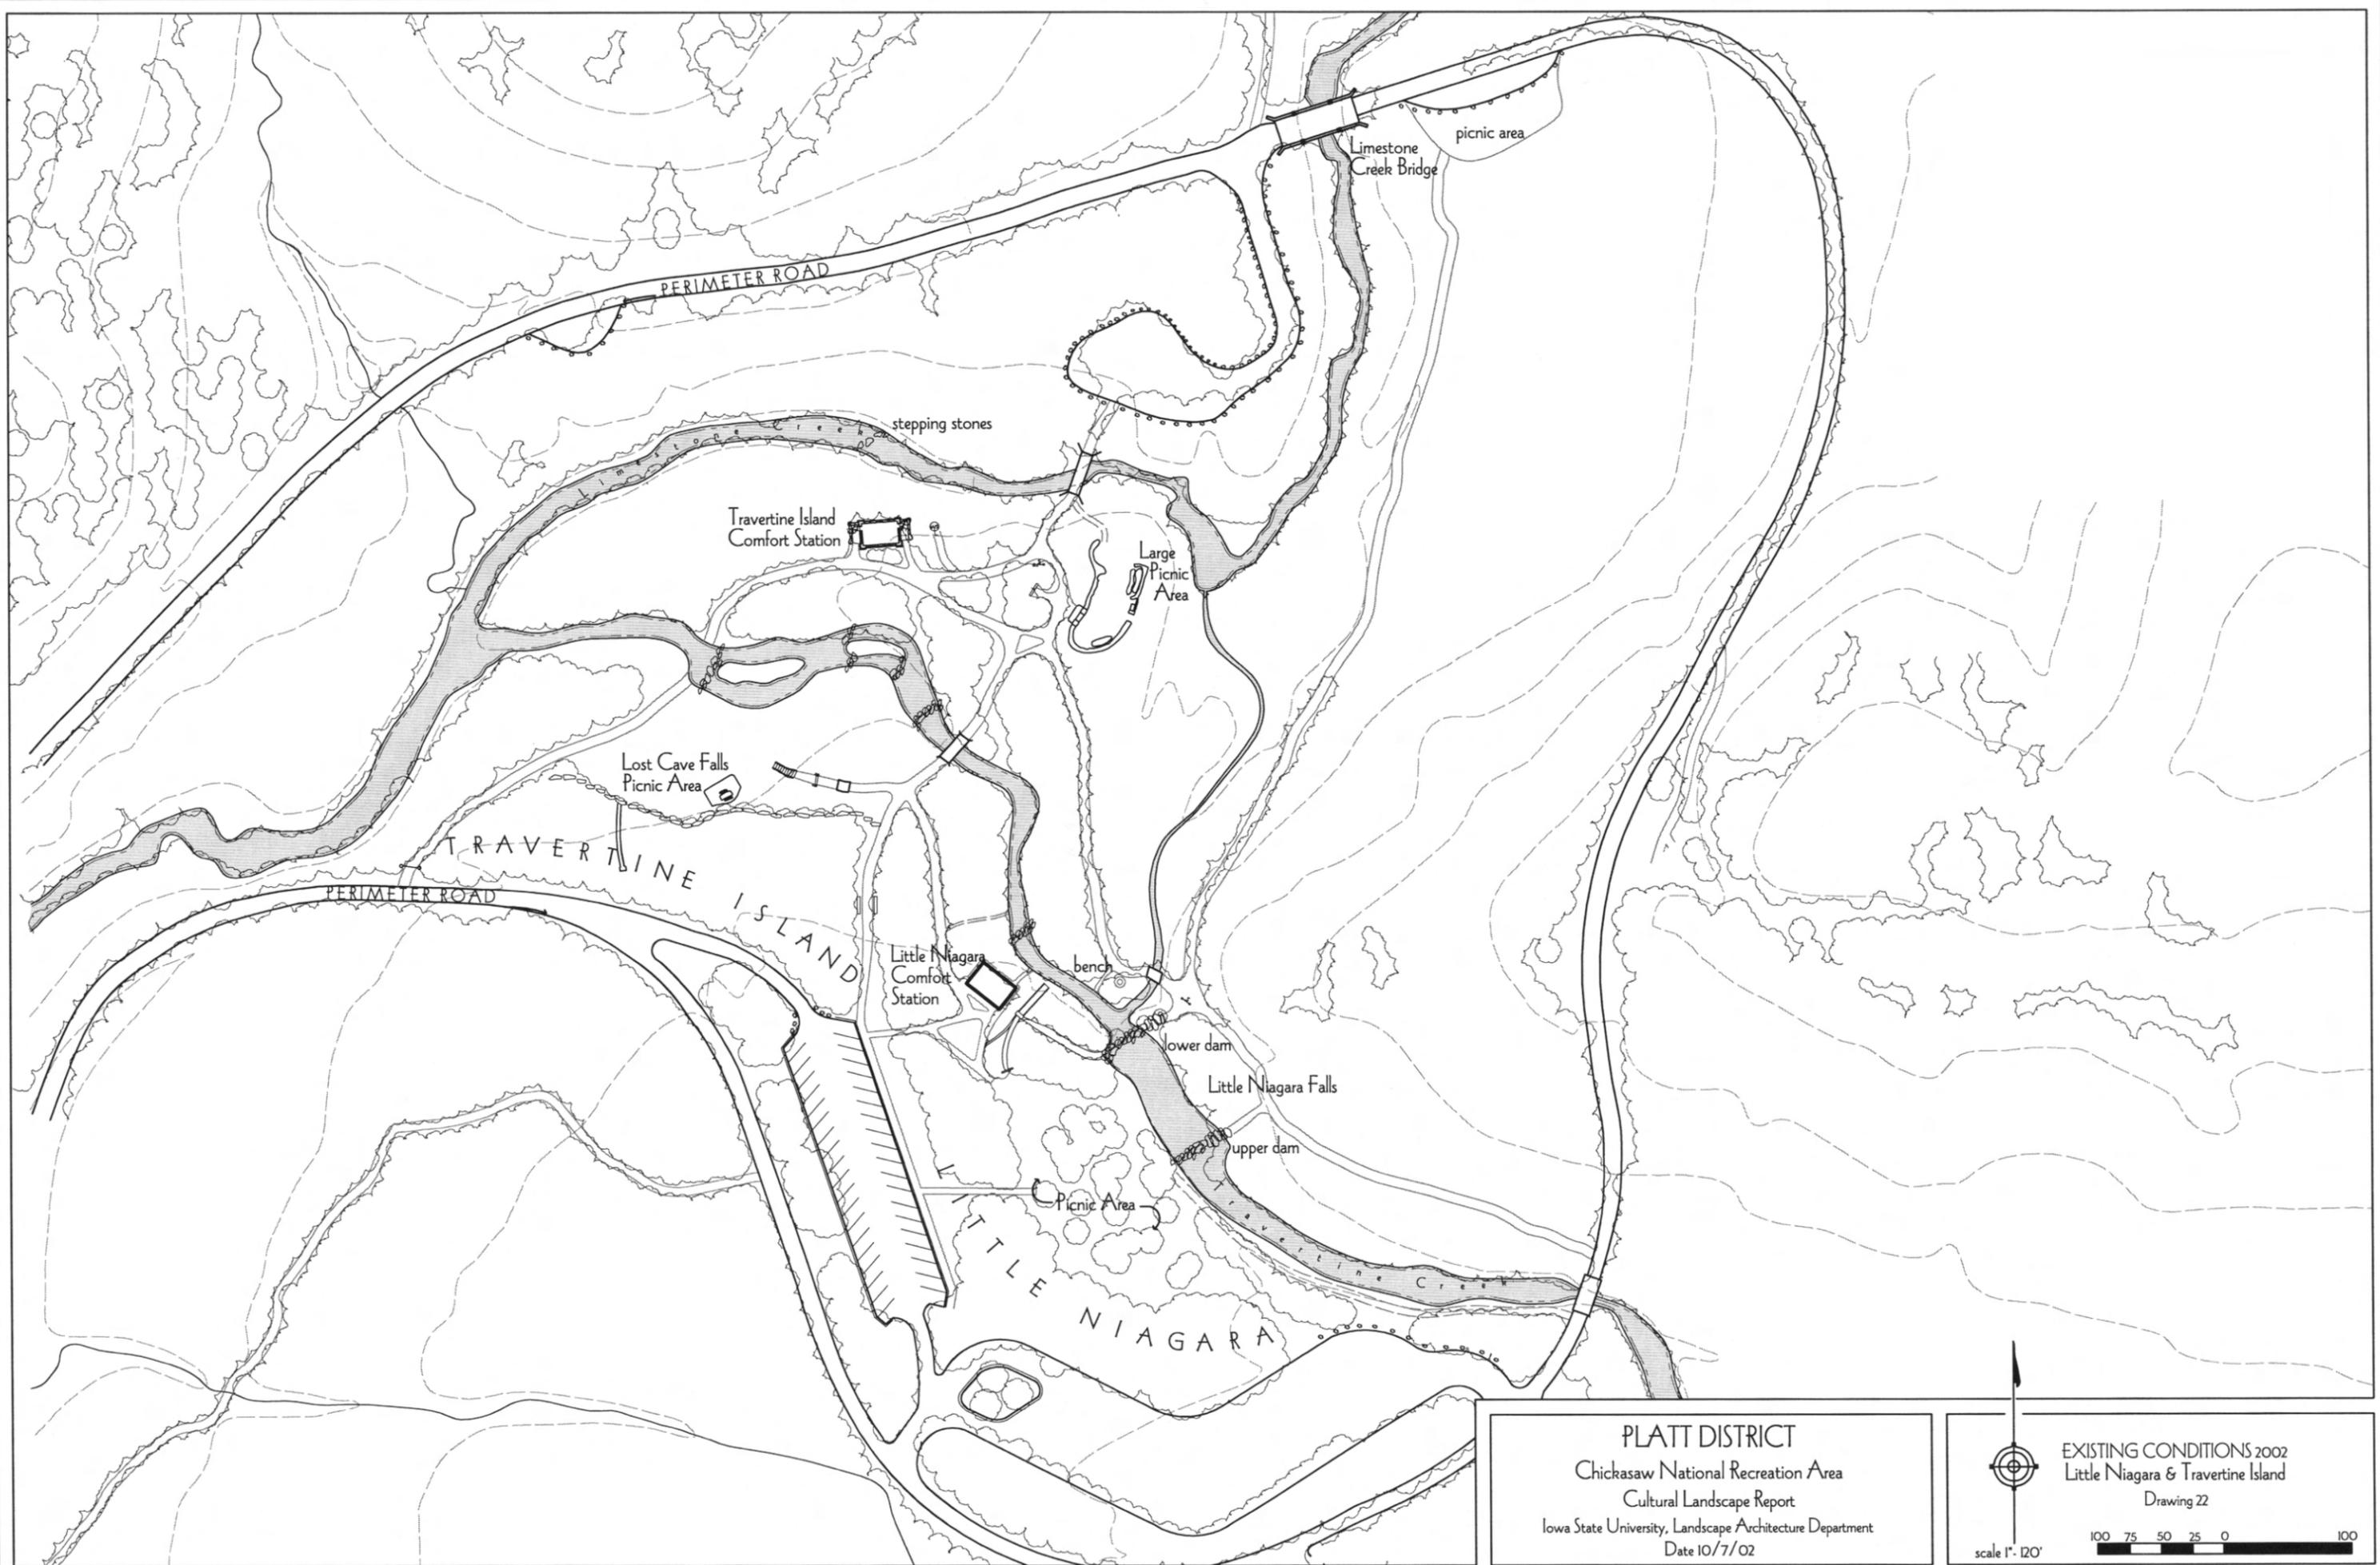

PLATT DISTRICT
 Chickasaw National Recreation Area
 Cultural Landscape Report
 Iowa State University, Landscape Architecture Department
 Date 10/7/02

EXISTING CONDITIONS 2002
 Little Niagara & Travertine Island
 Drawing 22

scale 1" = 120'




PLATT DISTRICT
 Chickasaw National Recreation Area
 Cultural Landscape Report
 Iowa State University, Landscape Architecture Department
 Date 10/7/02

EXISTING CONDITIONS 2002
 Antelope Springs & Buffalo Springs
 Drawing 23

scale 1" = 250'


A north arrow pointing upwards and a graphic scale bar with markings from 0 to 200 feet are located in the bottom right corner.

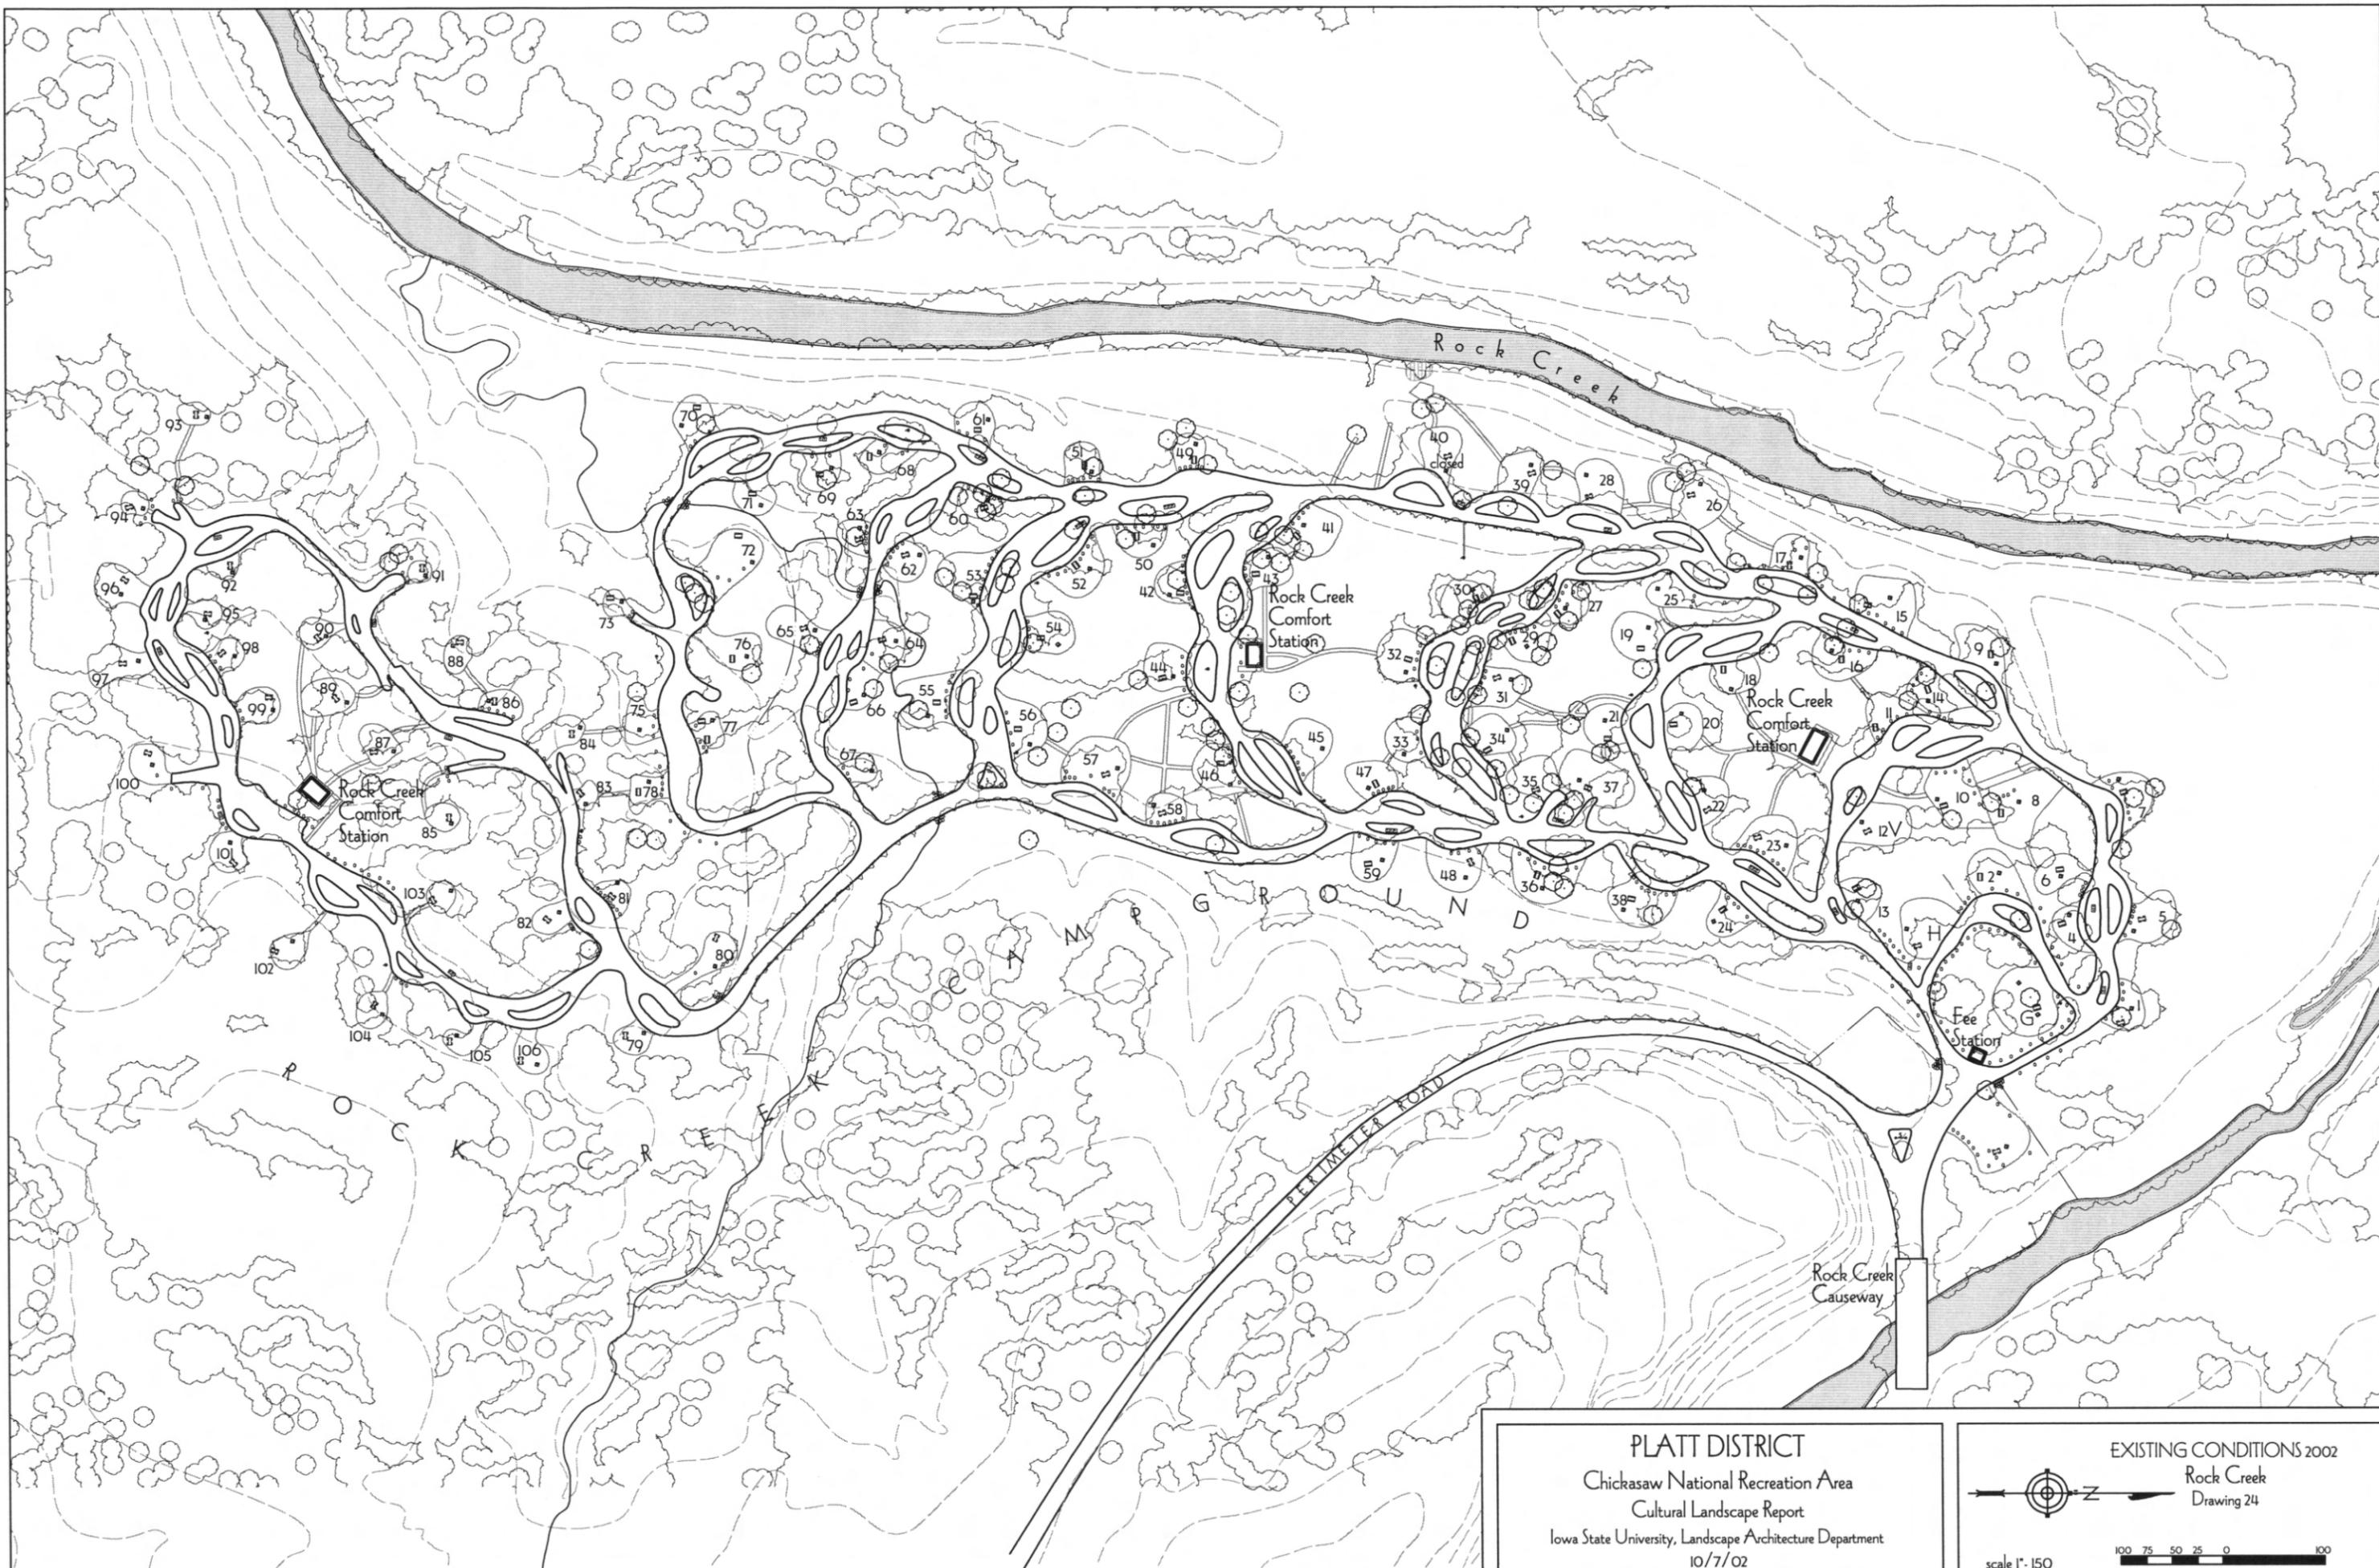

PLATT DISTRICT
 Chickasaw National Recreation Area
 Cultural Landscape Report
 Iowa State University, Landscape Architecture Department
 10/7/02

EXISTING CONDITIONS 2002
 Rock Creek
 Drawing 24

scale 1" = 150'

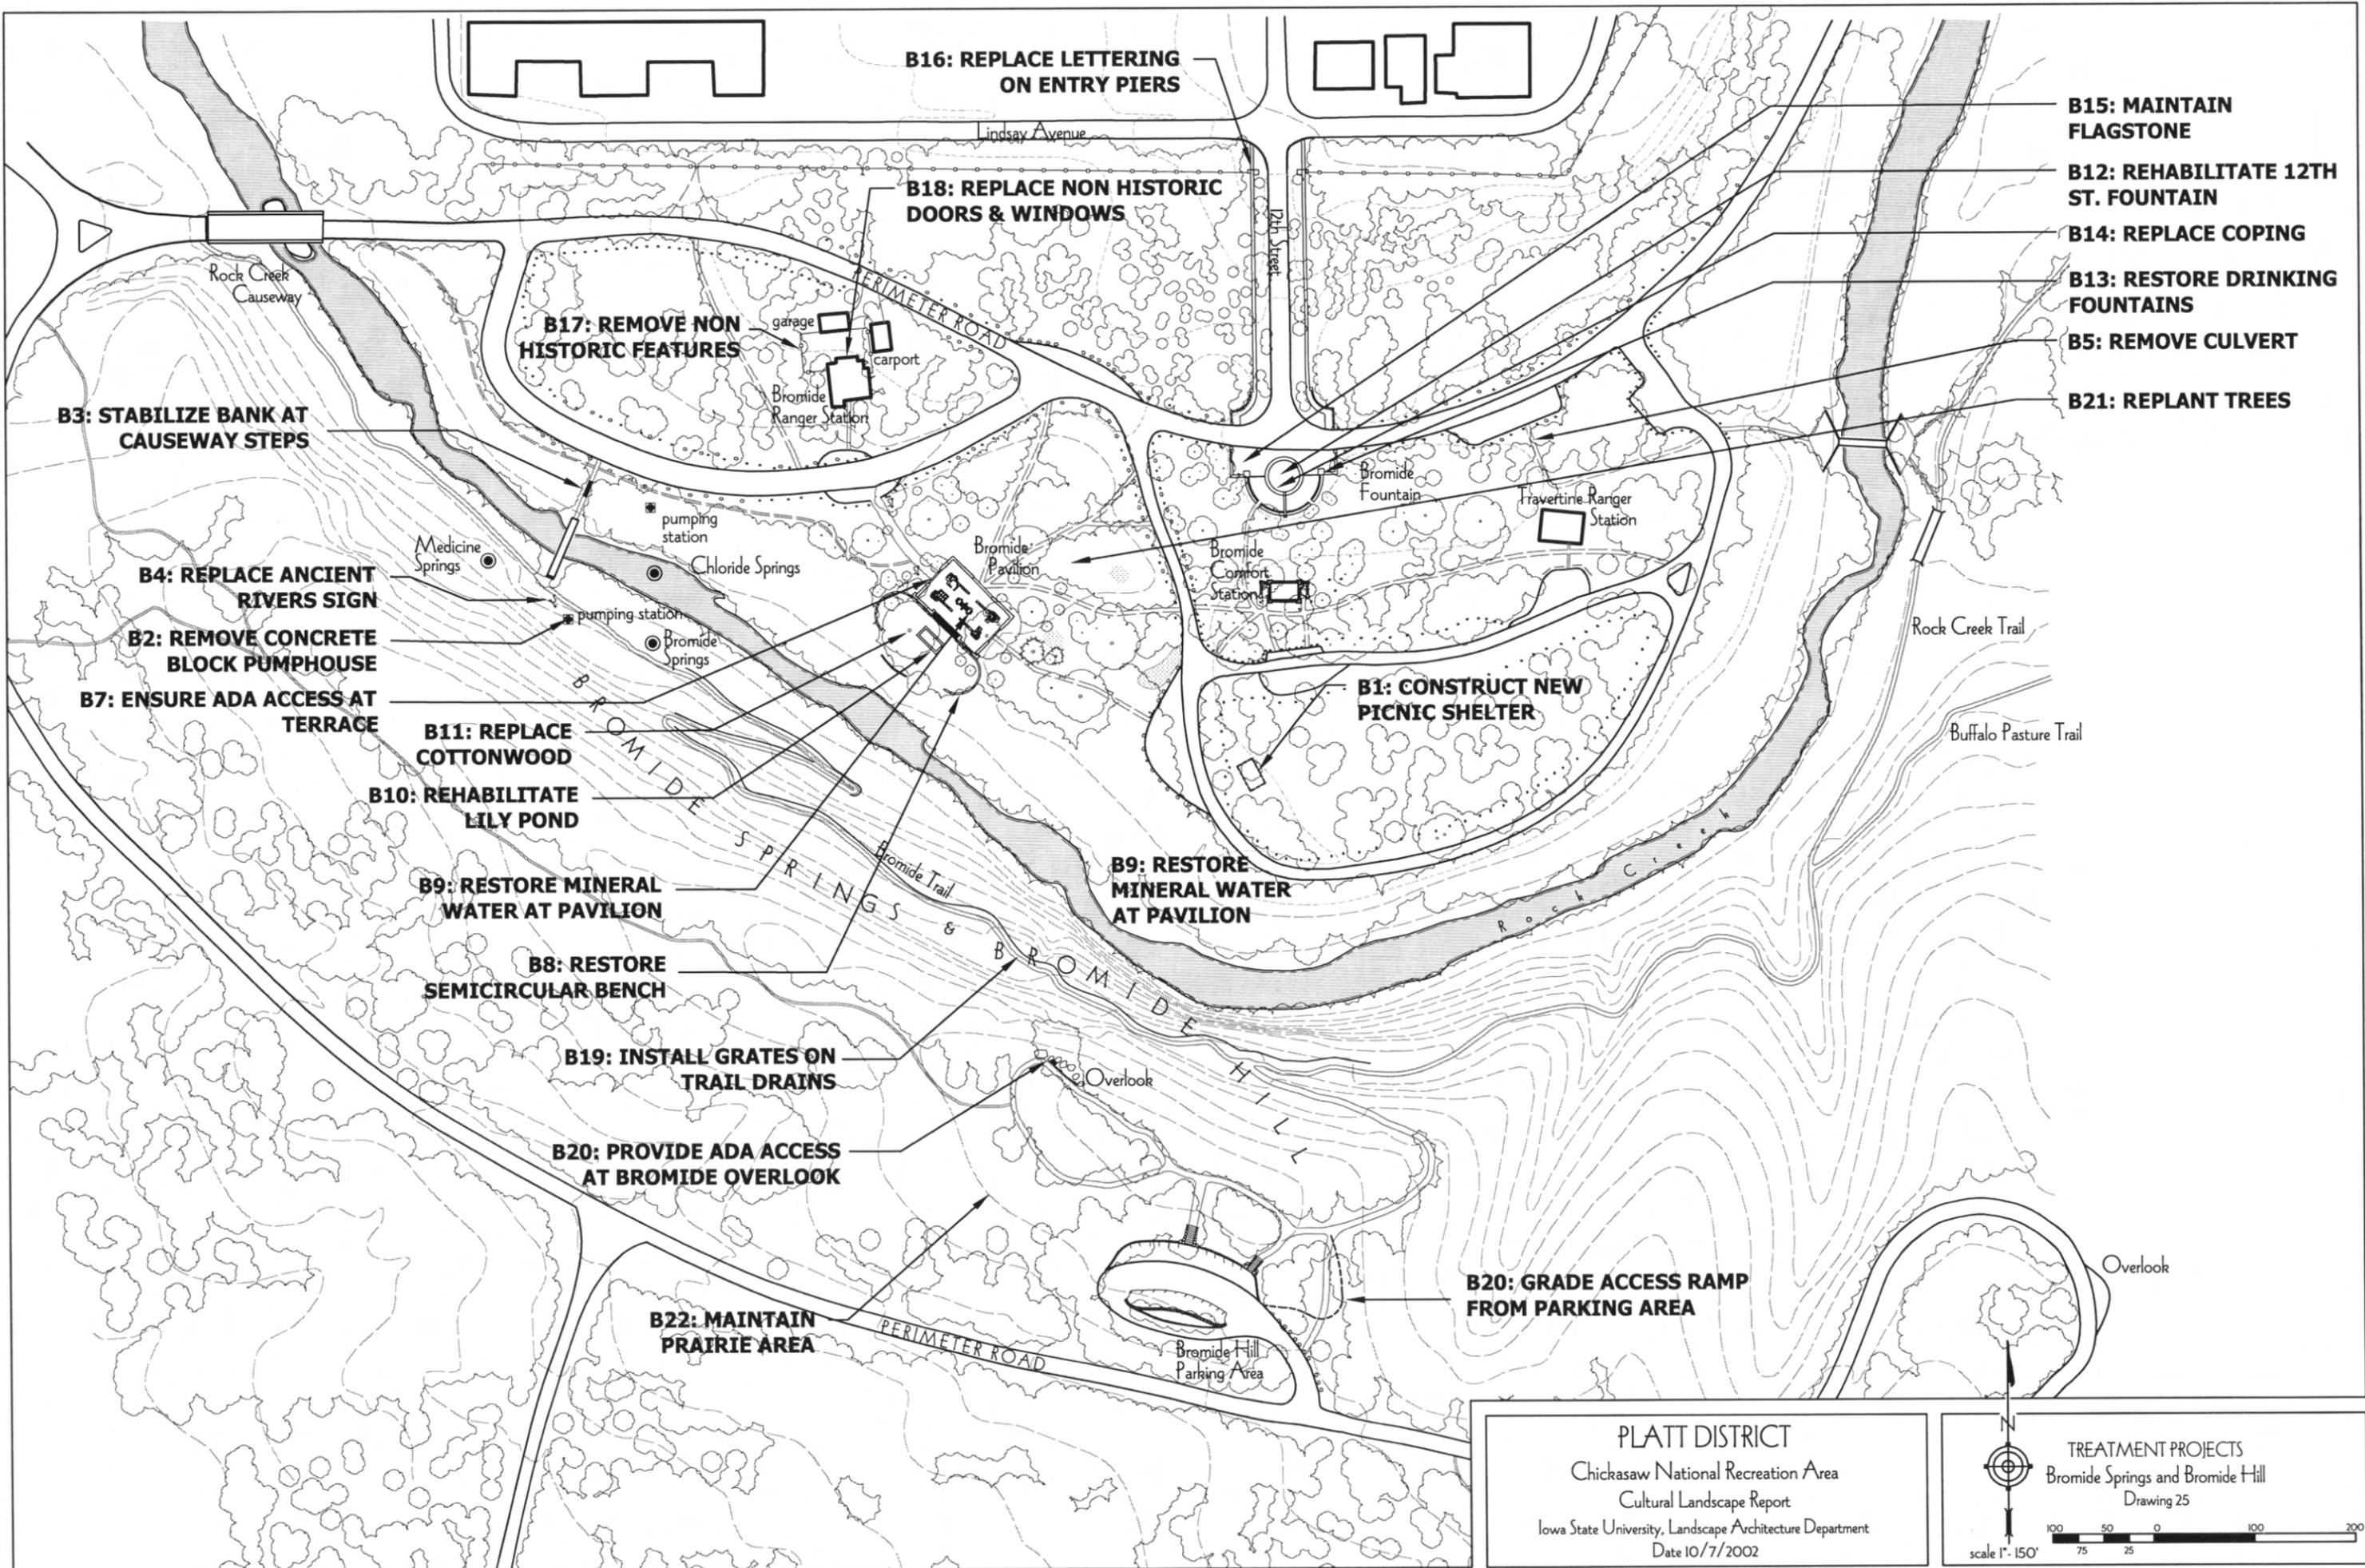

B16: REPLACE LETTERING ON ENTRY PIERS

B18: REPLACE NON HISTORIC DOORS & WINDOWS

B17: REMOVE NON HISTORIC FEATURES

B3: STABILIZE BANK AT CAUSEWAY STEPS

B4: REPLACE ANCIENT RIVERS SIGN

B2: REMOVE CONCRETE BLOCK PUMPHOUSE

B7: ENSURE ADA ACCESS AT TERRACE

B11: REPLACE COTTONWOOD

B10: REHABILITATE LILY POND

B9: RESTORE MINERAL WATER AT PAVILION

B8: RESTORE SEMICIRCULAR BENCH

B19: INSTALL GRATES ON TRAIL DRAINS

B20: PROVIDE ADA ACCESS AT BROMIDE OVERLOOK

B22: MAINTAIN PRAIRIE AREA

B9: RESTORE MINERAL WATER AT PAVILION

B1: CONSTRUCT NEW PICNIC SHELTER

B20: GRADE ACCESS RAMP FROM PARKING AREA

B15: MAINTAIN FLAGSTONE

B12: REHABILITATE 12TH ST. FOUNTAIN


B14: REPLACE COPING


B13: RESTORE DRINKING FOUNTAINS

B5: REMOVE CULVERT

B21: REPLANT TREES

PLATT DISTRICT
 Chickasaw National Recreation Area
 Cultural Landscape Report
 Iowa State University, Landscape Architecture Department
 Date 10/7/2002

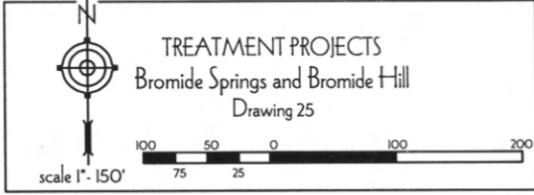

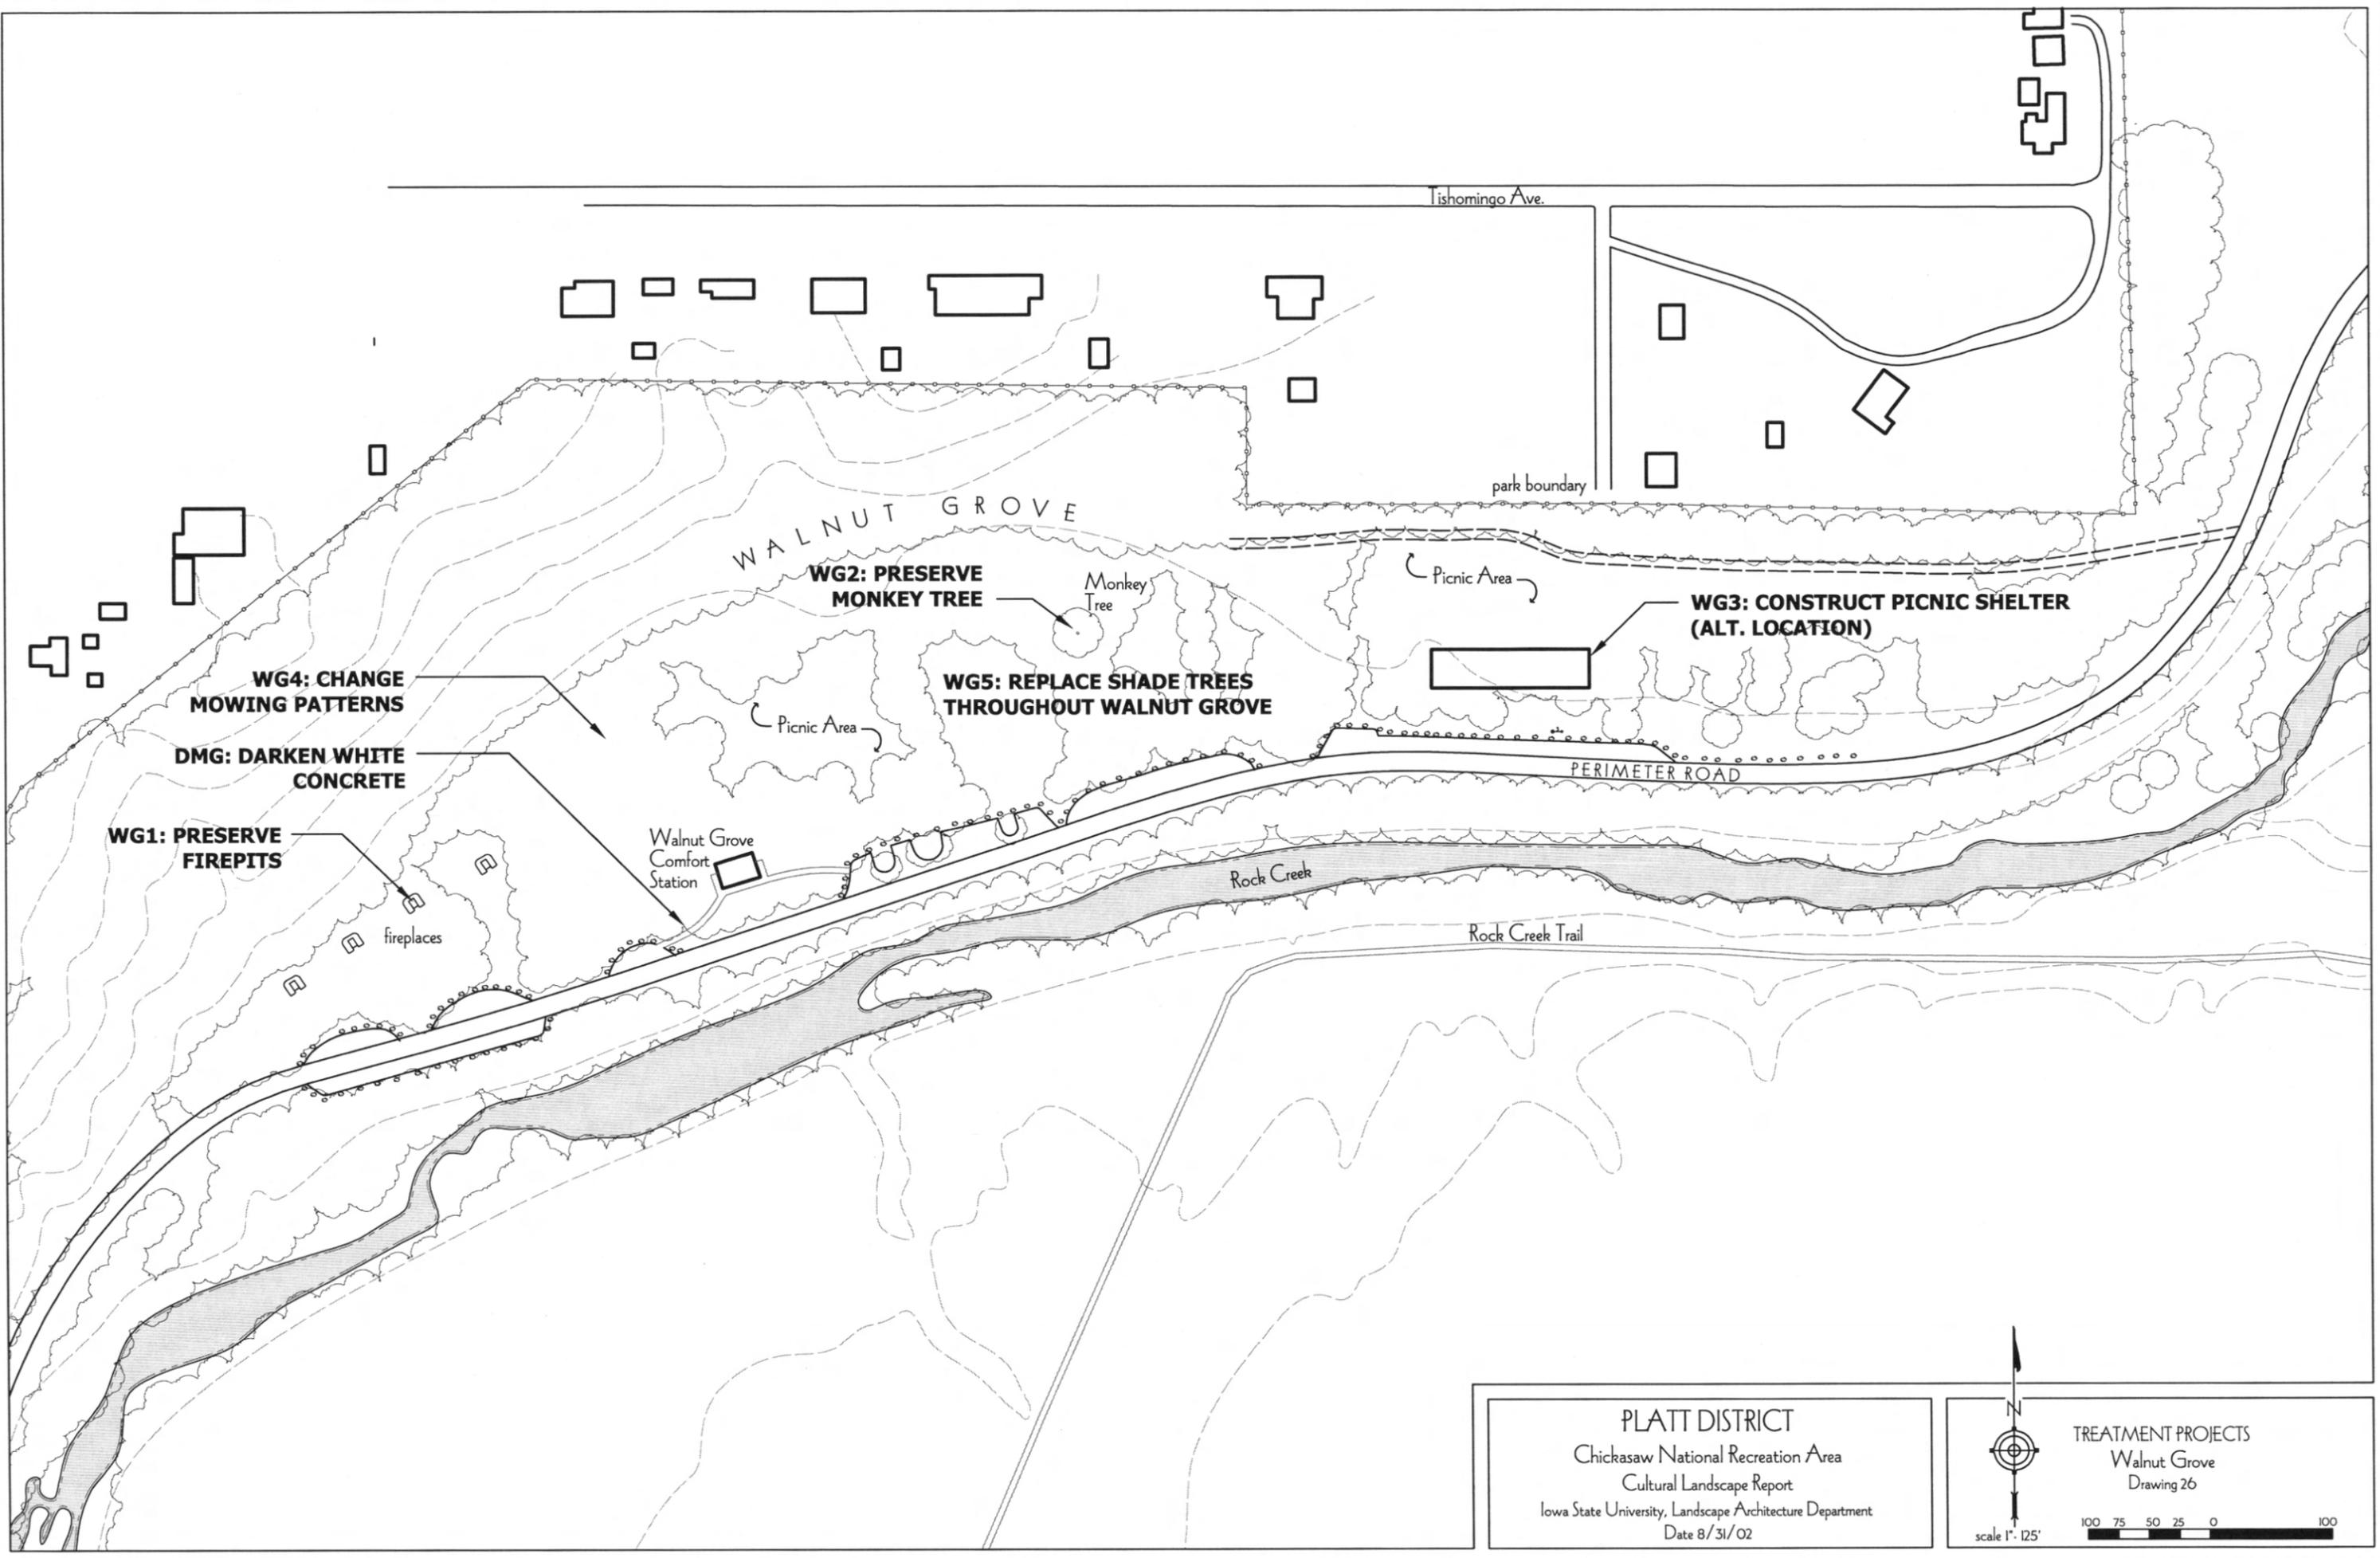

**WG1: PRESERVE
FIREPITS**

**DMG: DARKEN WHITE
CONCRETE**

**WG4: CHANGE
MOWING PATTERNS**

**WG2: PRESERVE
MONKEY TREE**

**WG5: REPLACE SHADE TREES
THROUGHOUT WALNUT GROVE**

**WG3: CONSTRUCT PICNIC SHELTER
(ALT. LOCATION)**


PLATT DISTRICT
Chickasaw National Recreation Area
Cultural Landscape Report
Iowa State University, Landscape Architecture Department
Date 8/31/02



TREATMENT PROJECTS
Walnut Grove
Drawing 26

scale 1" = 125'

100 75 50 25 0 100

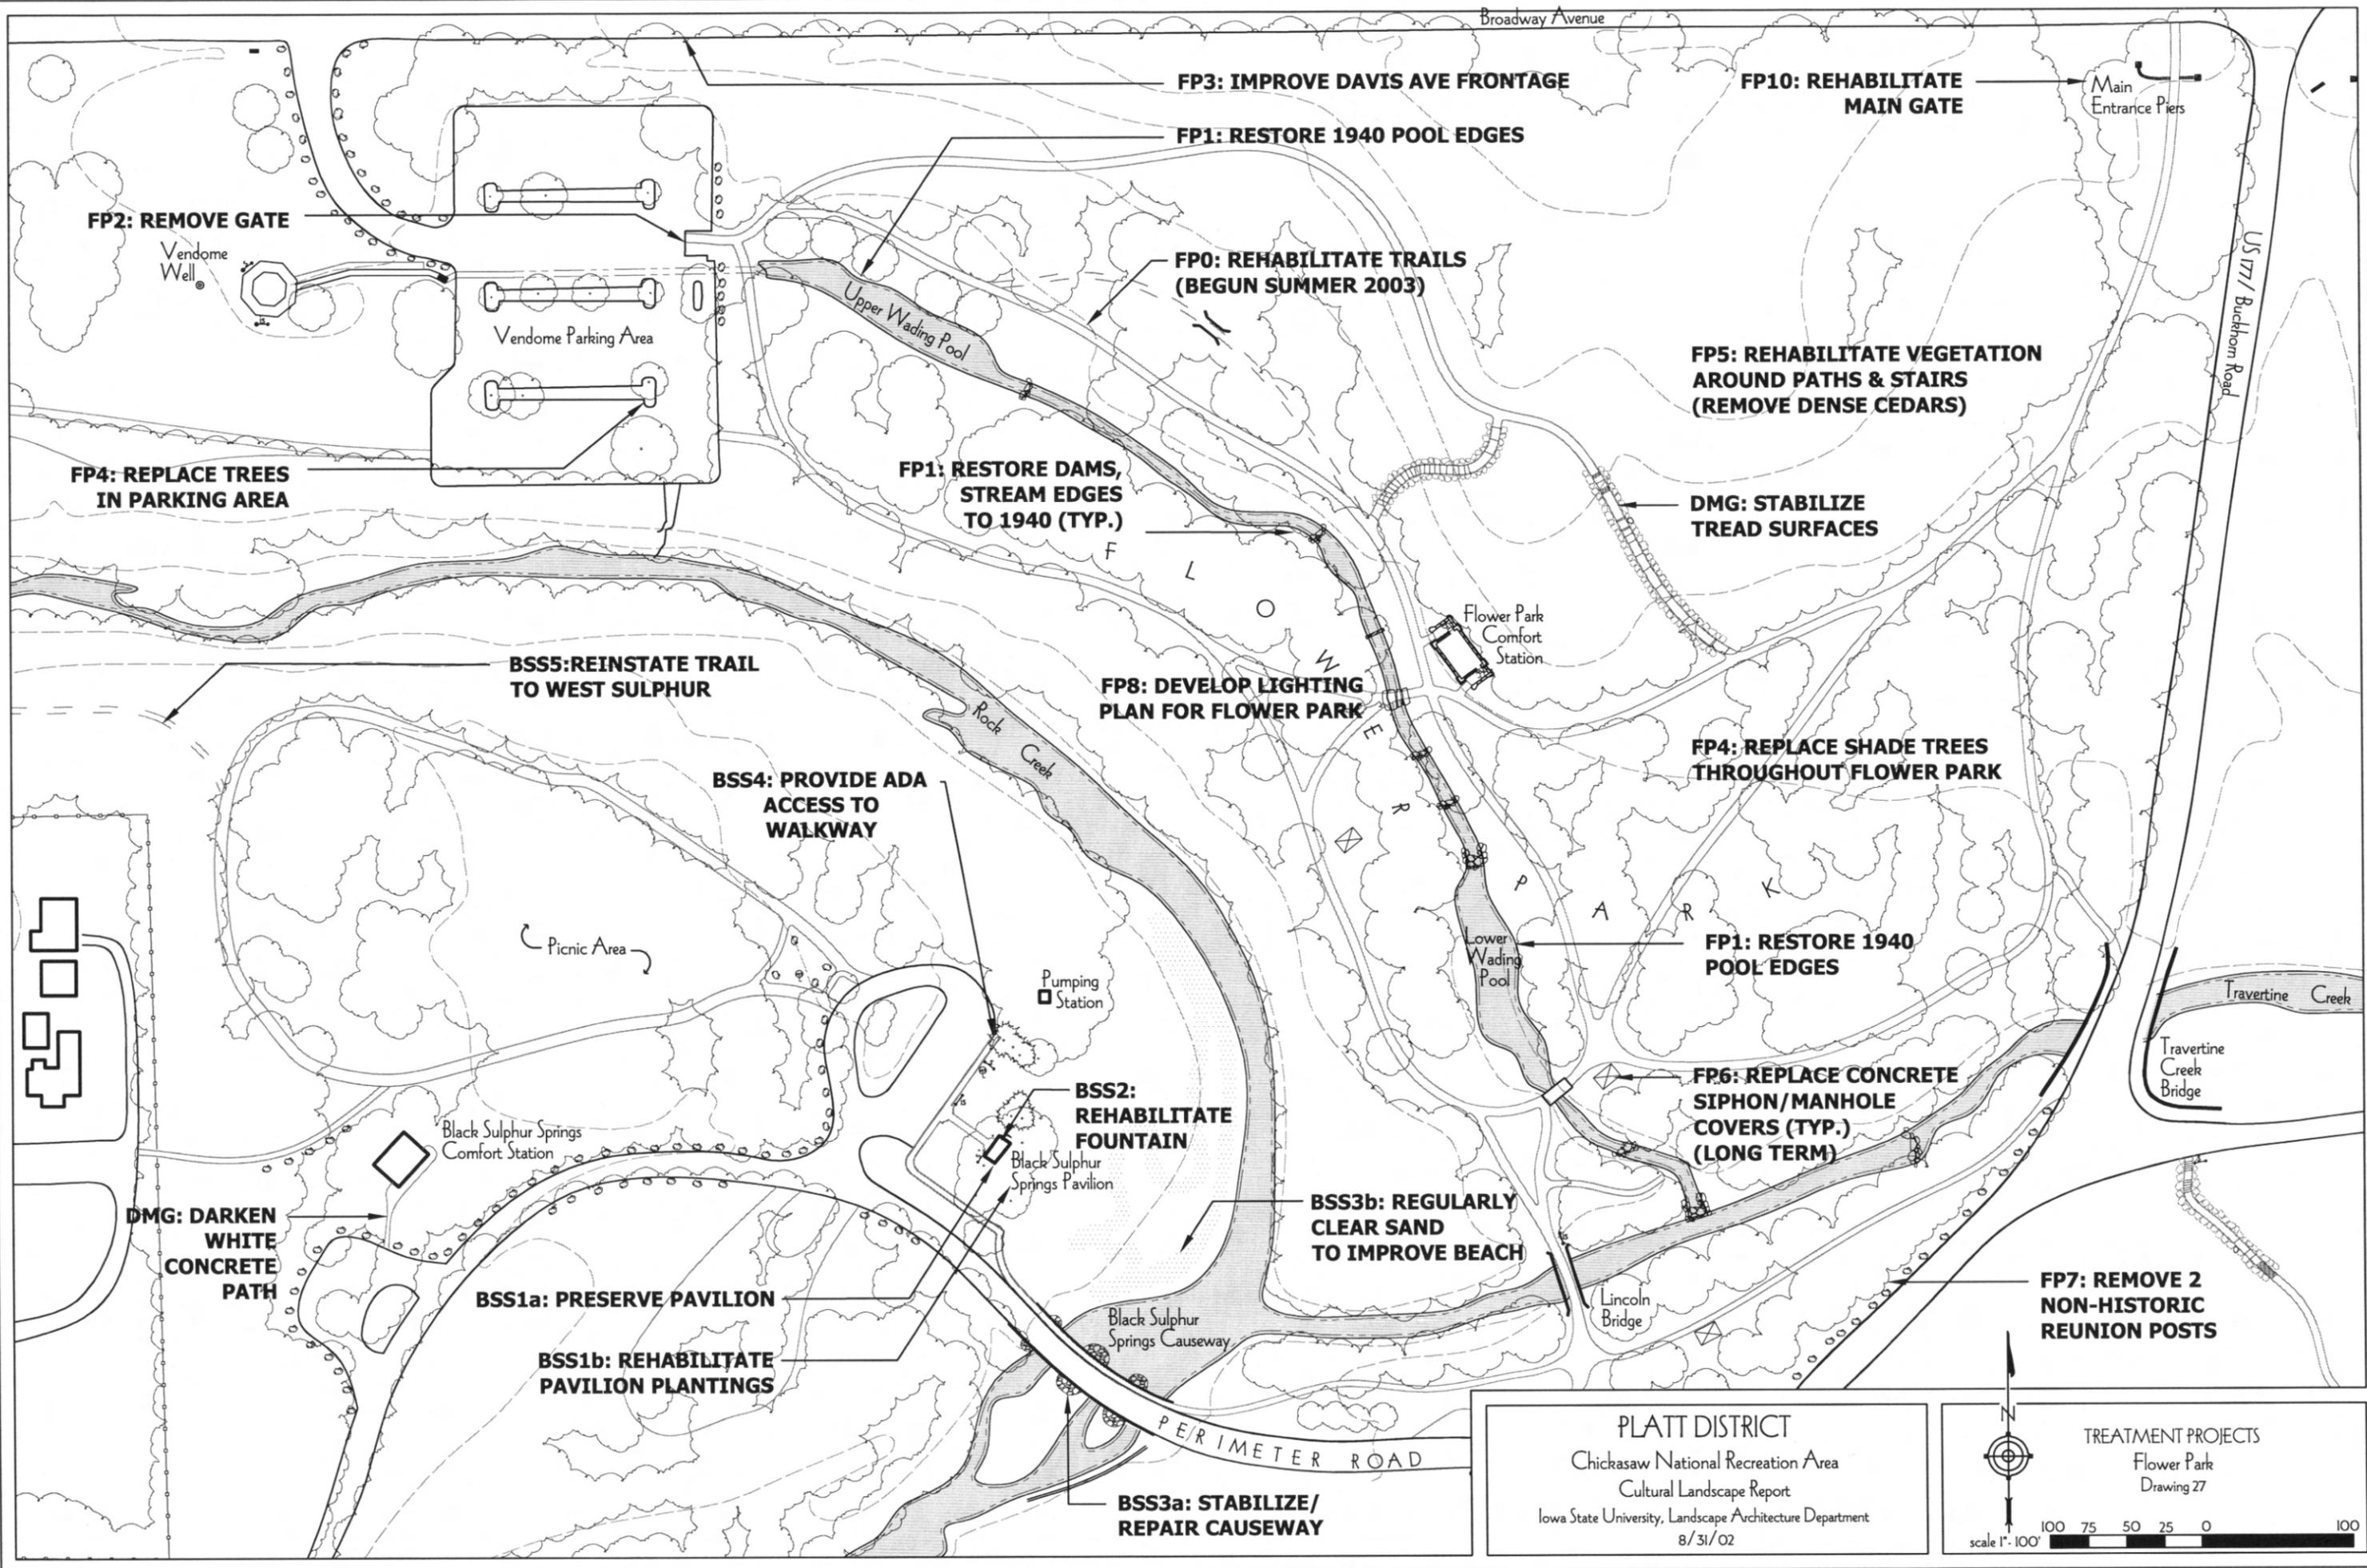

FP2: REMOVE GATE

FP4: REPLACE TREES IN PARKING AREA

BSS5: REINSTATE TRAIL TO WEST SULPHUR

DMG: DARKEN WHITE CONCRETE PATH

BSS1a: PRESERVE PAVILION

BSS1b: REHABILITATE PAVILION PLANTINGS

FP3: IMPROVE DAVIS AVE FRONTAGE

FP1: RESTORE 1940 POOL EDGES

FP1: RESTORE DAMS, STREAM EDGES TO 1940 (TYP.)

FP8: DEVELOP LIGHTING PLAN FOR FLOWER PARK

BSS2: REHABILITATE FOUNTAIN

BSS3b: REGULARLY CLEAR SAND TO IMPROVE BEACH

BSS3a: STABILIZE/REPAIR CAUSEWAY

FP10: REHABILITATE MAIN GATE

FP5: REHABILITATE VEGETATION AROUND PATHS & STAIRS (REMOVE DENSE CEDARS)

DMG: STABILIZE TREAD SURFACES


FP4: REPLACE SHADE TREES THROUGHOUT FLOWER PARK

FP1: RESTORE 1940 POOL EDGES


FP6: REPLACE CONCRETE SIPHON/MANHOLE COVERS (TYP.) (LONG TERM)

FP7: REMOVE 2 NON-HISTORIC REUNION POSTS

PLATT DISTRICT
 Chickasaw National Recreation Area
 Cultural Landscape Report
 Iowa State University, Landscape Architecture Department
 8/31/02

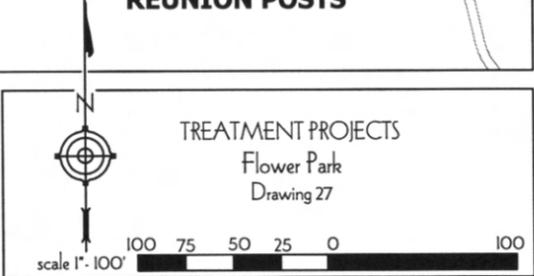

See drawing 19

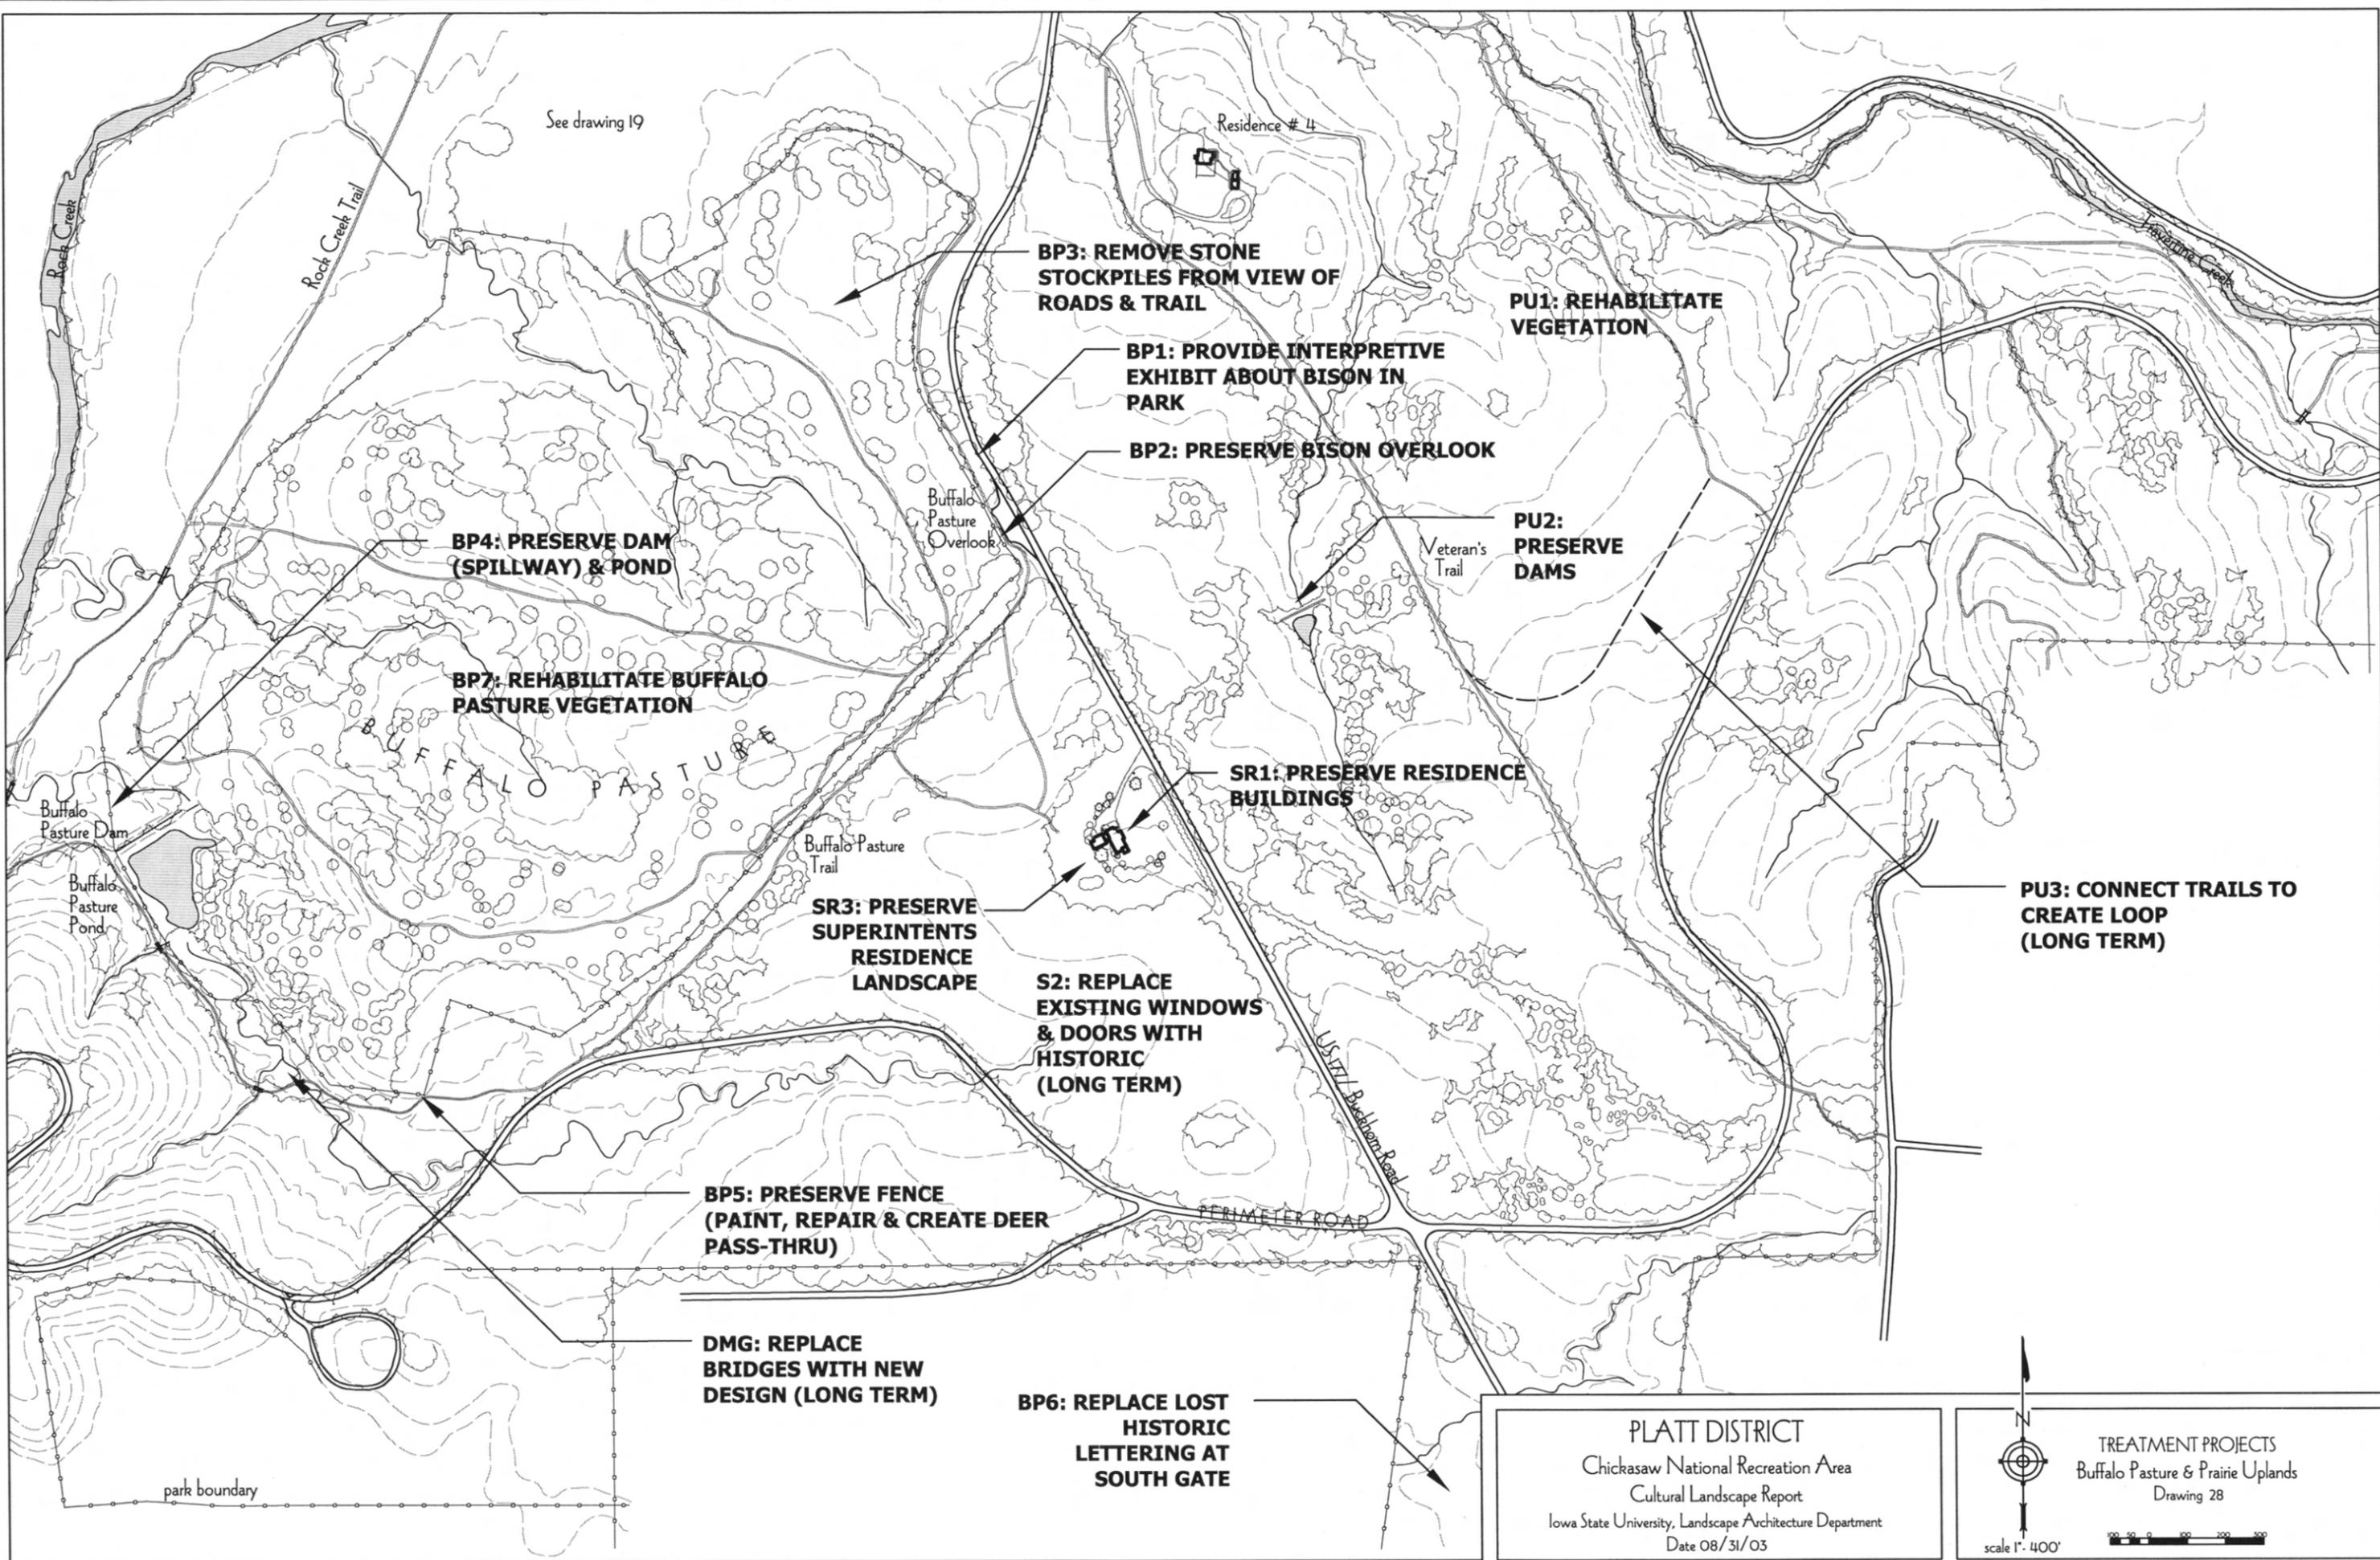

BP3: REMOVE STONE STOCKPILES FROM VIEW OF ROADS & TRAIL

PU1: REHABILITATE VEGETATION

BP1: PROVIDE INTERPRETIVE EXHIBIT ABOUT BISON IN PARK

BP2: PRESERVE BISON OVERLOOK

BP4: PRESERVE DAM (SPILLWAY) & POND

PU2: PRESERVE DAMS

BP7: REHABILITATE BUFFALO PASTURE VEGETATION

SR1: PRESERVE RESIDENCE BUILDINGS

PU3: CONNECT TRAILS TO CREATE LOOP (LONG TERM)

SR3: PRESERVE SUPERINTENDENTS RESIDENCE LANDSCAPE

S2: REPLACE EXISTING WINDOWS & DOORS WITH HISTORIC (LONG TERM)

BP5: PRESERVE FENCE (PAINT, REPAIR & CREATE DEER PASS-THRU)


DMG: REPLACE BRIDGES WITH NEW DESIGN (LONG TERM)

BP6: REPLACE LOST HISTORIC LETTERING AT SOUTH GATE

PLATT DISTRICT
 Chickasaw National Recreation Area
 Cultural Landscape Report
 Iowa State University, Landscape Architecture Department
 Date 08/31/03

TREATMENT PROJECTS
 Buffalo Pasture & Prairie Uplands
 Drawing 28

scale 1" = 400'

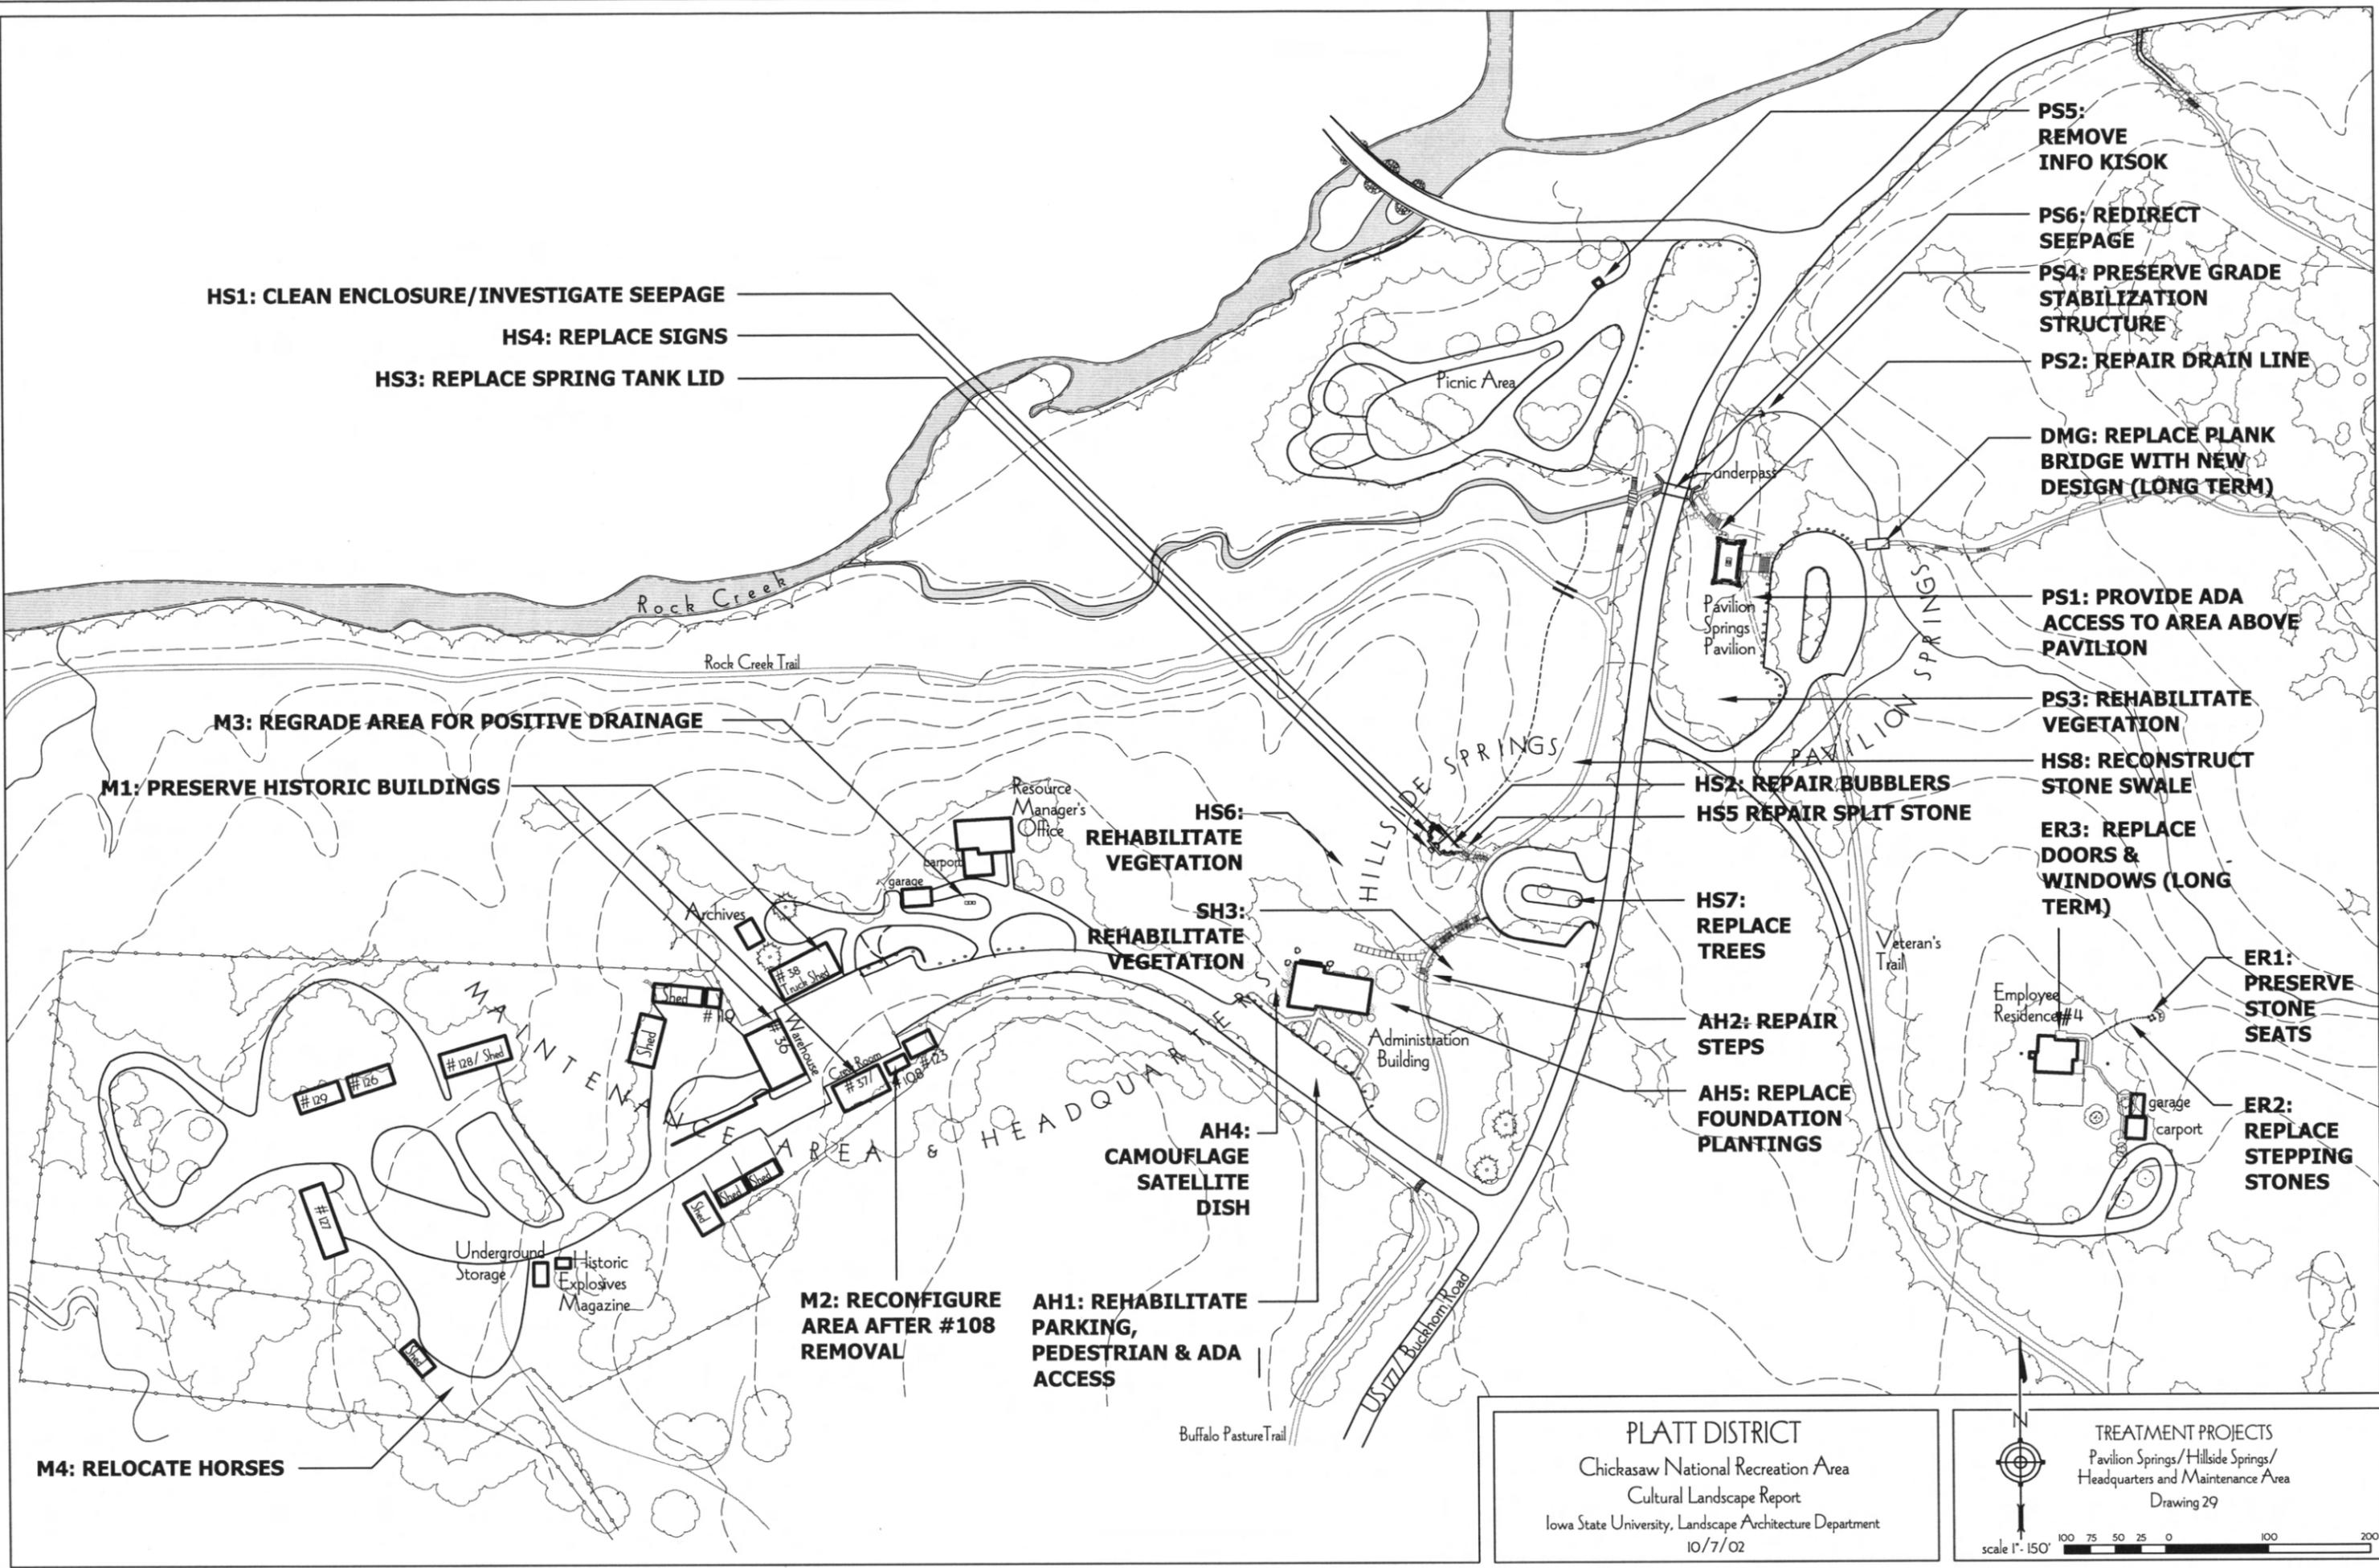

HS1: CLEAN ENCLOSURE/INVESTIGATE SEEPAGE
HS4: REPLACE SIGNS
HS3: REPLACE SPRING TANK LID

PS5: REMOVE INFO KISOK
PS6: REDIRECT SEEPAGE
PS4: PRESERVE GRADE STABILIZATION STRUCTURE
PS2: REPAIR DRAIN LINE
DMG: REPLACE PLANK BRIDGE WITH NEW DESIGN (LONG TERM)

PS1: PROVIDE ADA ACCESS TO AREA ABOVE PAVILION

PS3: REHABILITATE VEGETATION
HS8: RECONSTRUCT STONE SWALE

ER3: REPLACE DOORS & WINDOWS (LONG TERM)

ER1: PRESERVE STONE SEATS

ER2: REPLACE STEPPING STONES

M3: REGRADE AREA FOR POSITIVE DRAINAGE
M1: PRESERVE HISTORIC BUILDINGS

HS6: REHABILITATE VEGETATION

SH3: REHABILITATE VEGETATION

AH4: CAMOUFLAGE SATELLITE DISH

M2: RECONFIGURE AREA AFTER #108 REMOVAL

AH1: REHABILITATE PARKING, PEDESTRIAN & ADA ACCESS

HS2: REPAIR BUBBLERS
HS5 REPAIR SPLIT STONE

HS7: REPLACE TREES

AH2: REPAIR STEPS


AH5: REPLACE FOUNDATION PLANTINGS

M4: RELOCATE HORSES


PLATT DISTRICT
 Chickasaw National Recreation Area
 Cultural Landscape Report
 Iowa State University, Landscape Architecture Department
 10/7/02


TREATMENT PROJECTS
 Pavilion Springs/Hillside Springs/
 Headquarters and Maintenance Area
 Drawing 29

scale 1" = 150'

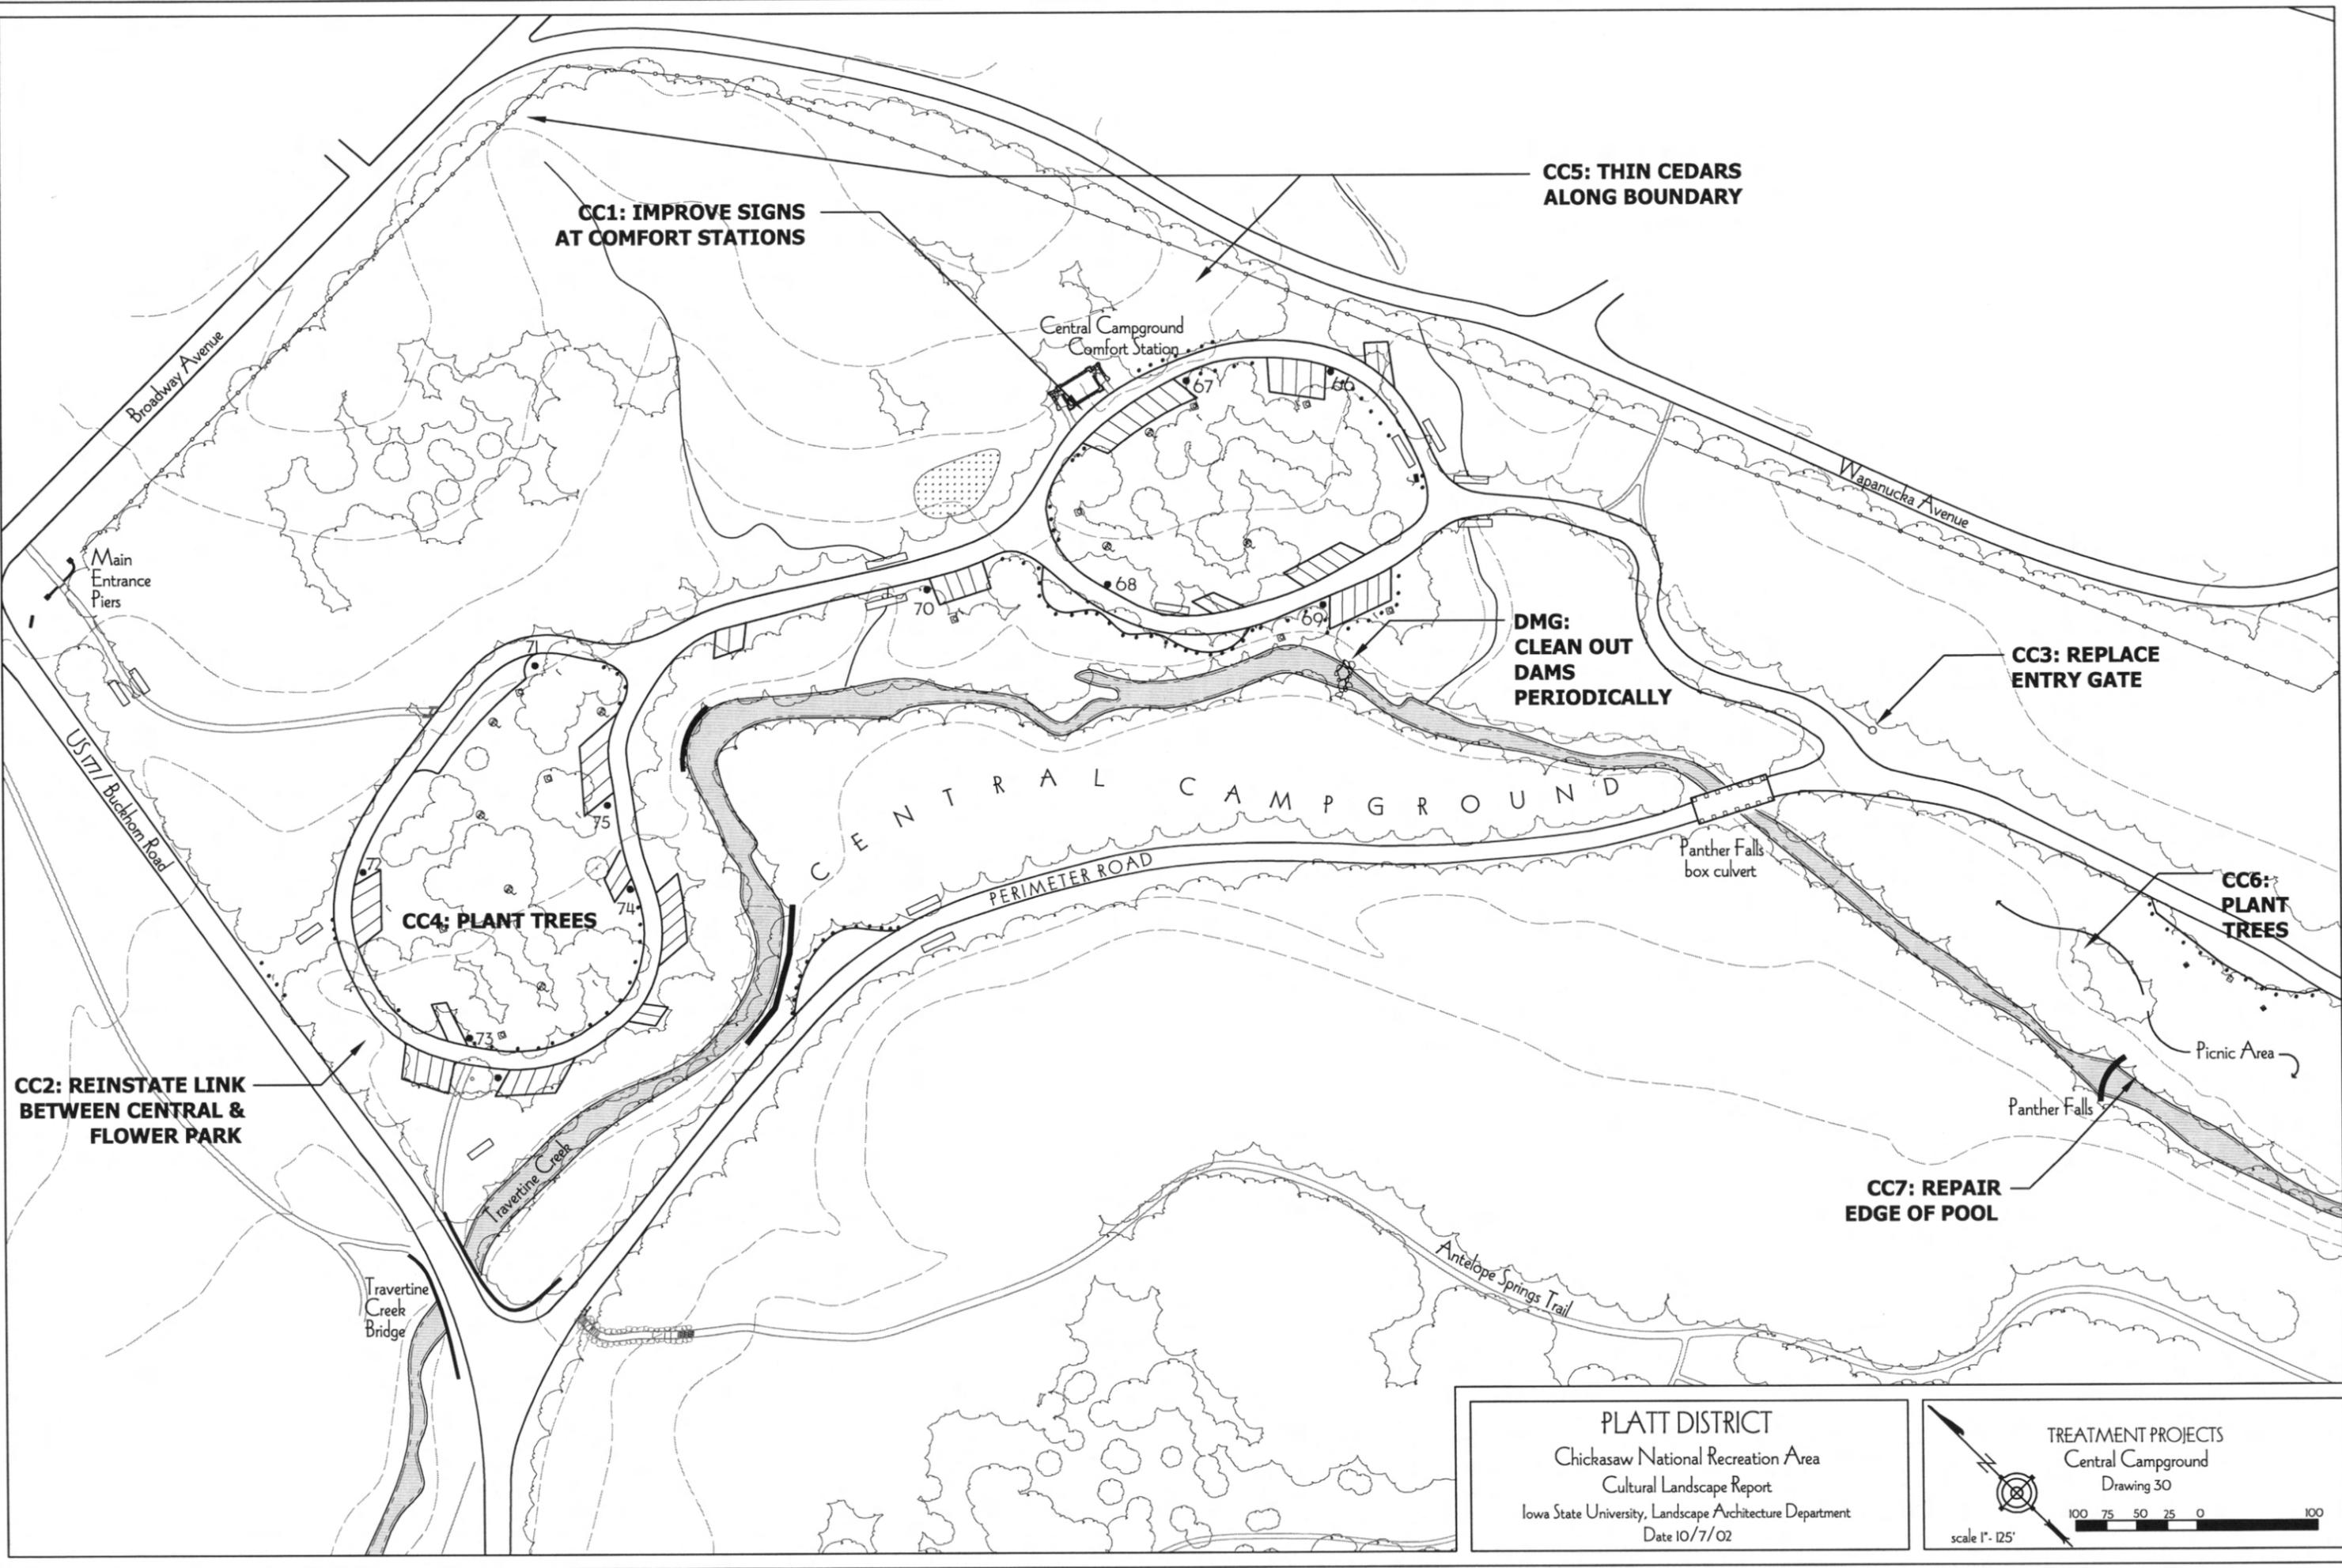

PLATT DISTRICT
 Chickasaw National Recreation Area
 Cultural Landscape Report
 Iowa State University, Landscape Architecture Department
 Date 10/7/02

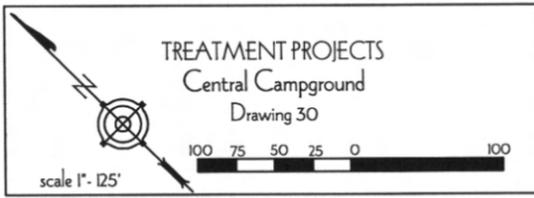

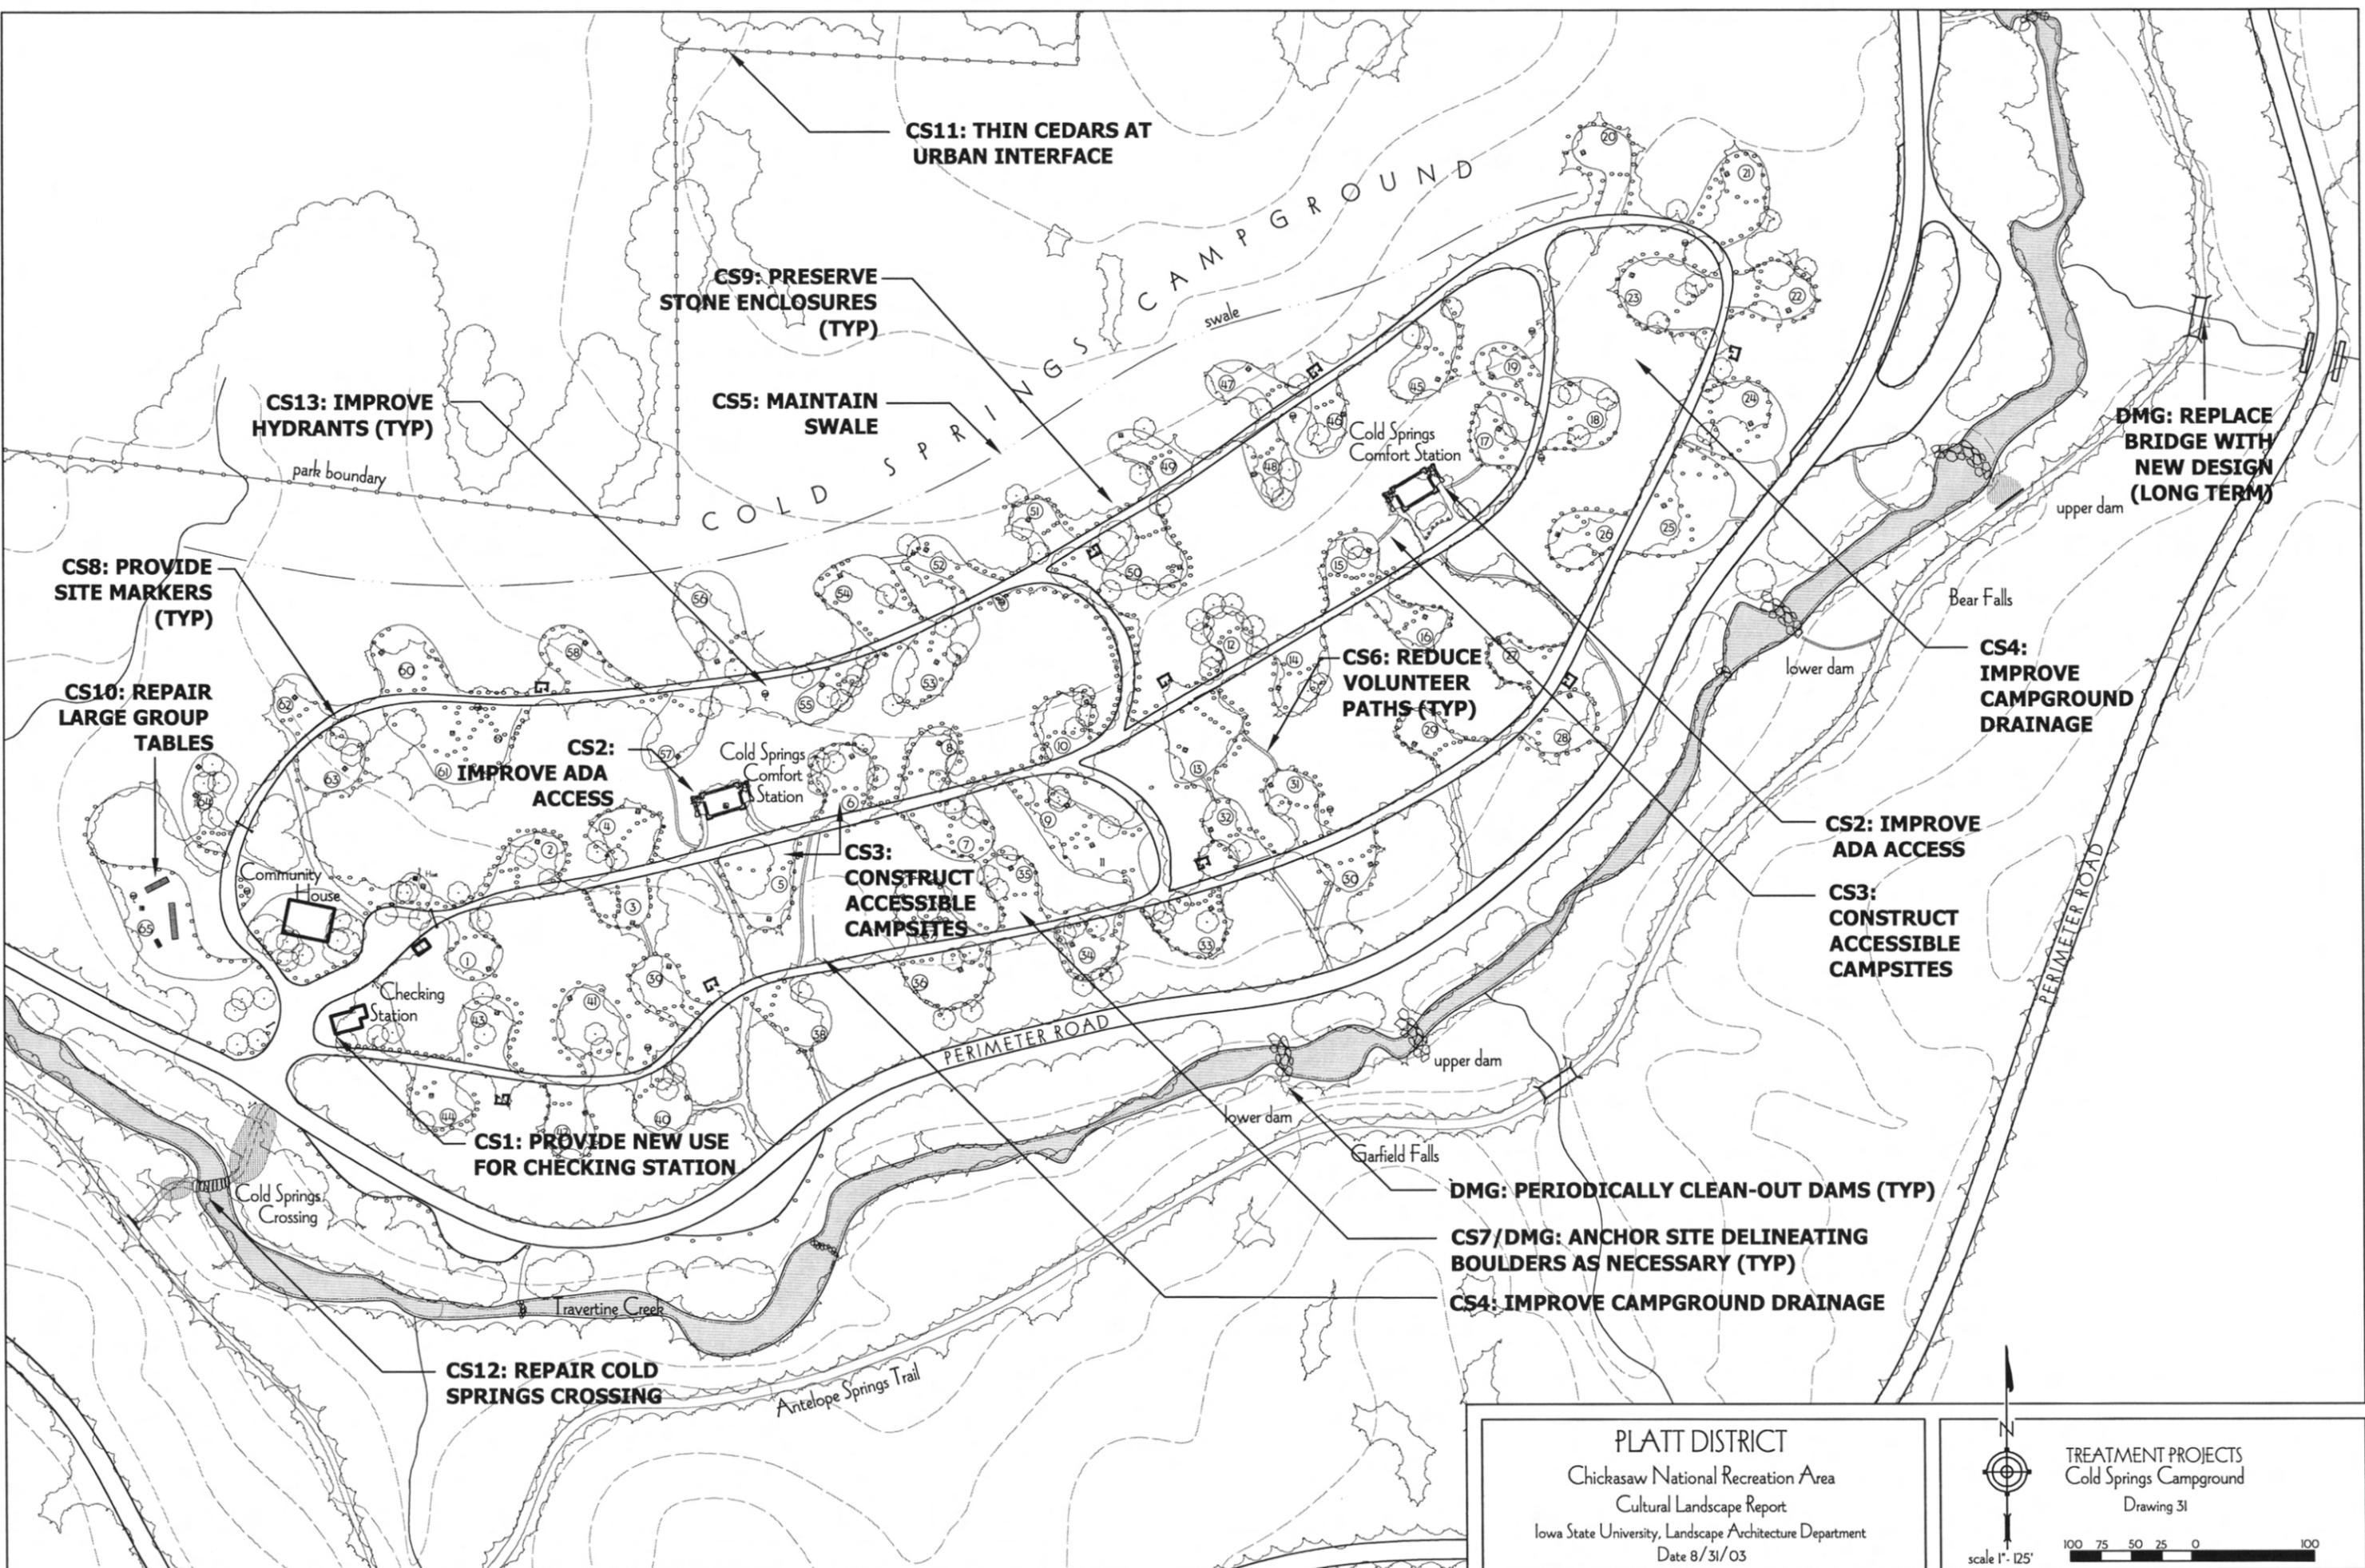

CS11: THIN CEDARS AT URBAN INTERFACE

CS9: PRESERVE STONE ENCLOSURES (TYP)

CS13: IMPROVE HYDRANTS (TYP)

CS5: MAINTAIN SWALE

CS8: PROVIDE SITE MARKERS (TYP)

CS10: REPAIR LARGE GROUP TABLES

CS2: IMPROVE ADA ACCESS

CS6: REDUCE VOLUNTEER PATHS (TYP)

DMG: REPLACE BRIDGE WITH NEW DESIGN (LONG TERM)

CS4: IMPROVE CAMPGROUND DRAINAGE

CS3: CONSTRUCT ACCESSIBLE CAMPSITES

CS2: IMPROVE ADA ACCESS

CS3: CONSTRUCT ACCESSIBLE CAMPSITES

CS1: PROVIDE NEW USE FOR CHECKING STATION

DMG: PERIODICALLY CLEAN-OUT DAMS (TYP)

CS7/DMG: ANCHOR SITE DELINEATING BOULDERS AS NECESSARY (TYP)


CS4: IMPROVE CAMPGROUND DRAINAGE

CS12: REPAIR COLD SPRINGS CROSSING

PLATT DISTRICT
 Chickasaw National Recreation Area
 Cultural Landscape Report
 Iowa State University, Landscape Architecture Department
 Date 8/31/03

TREATMENT PROJECTS
 Cold Springs Campground
 Drawing 31

scale 1" = 125'

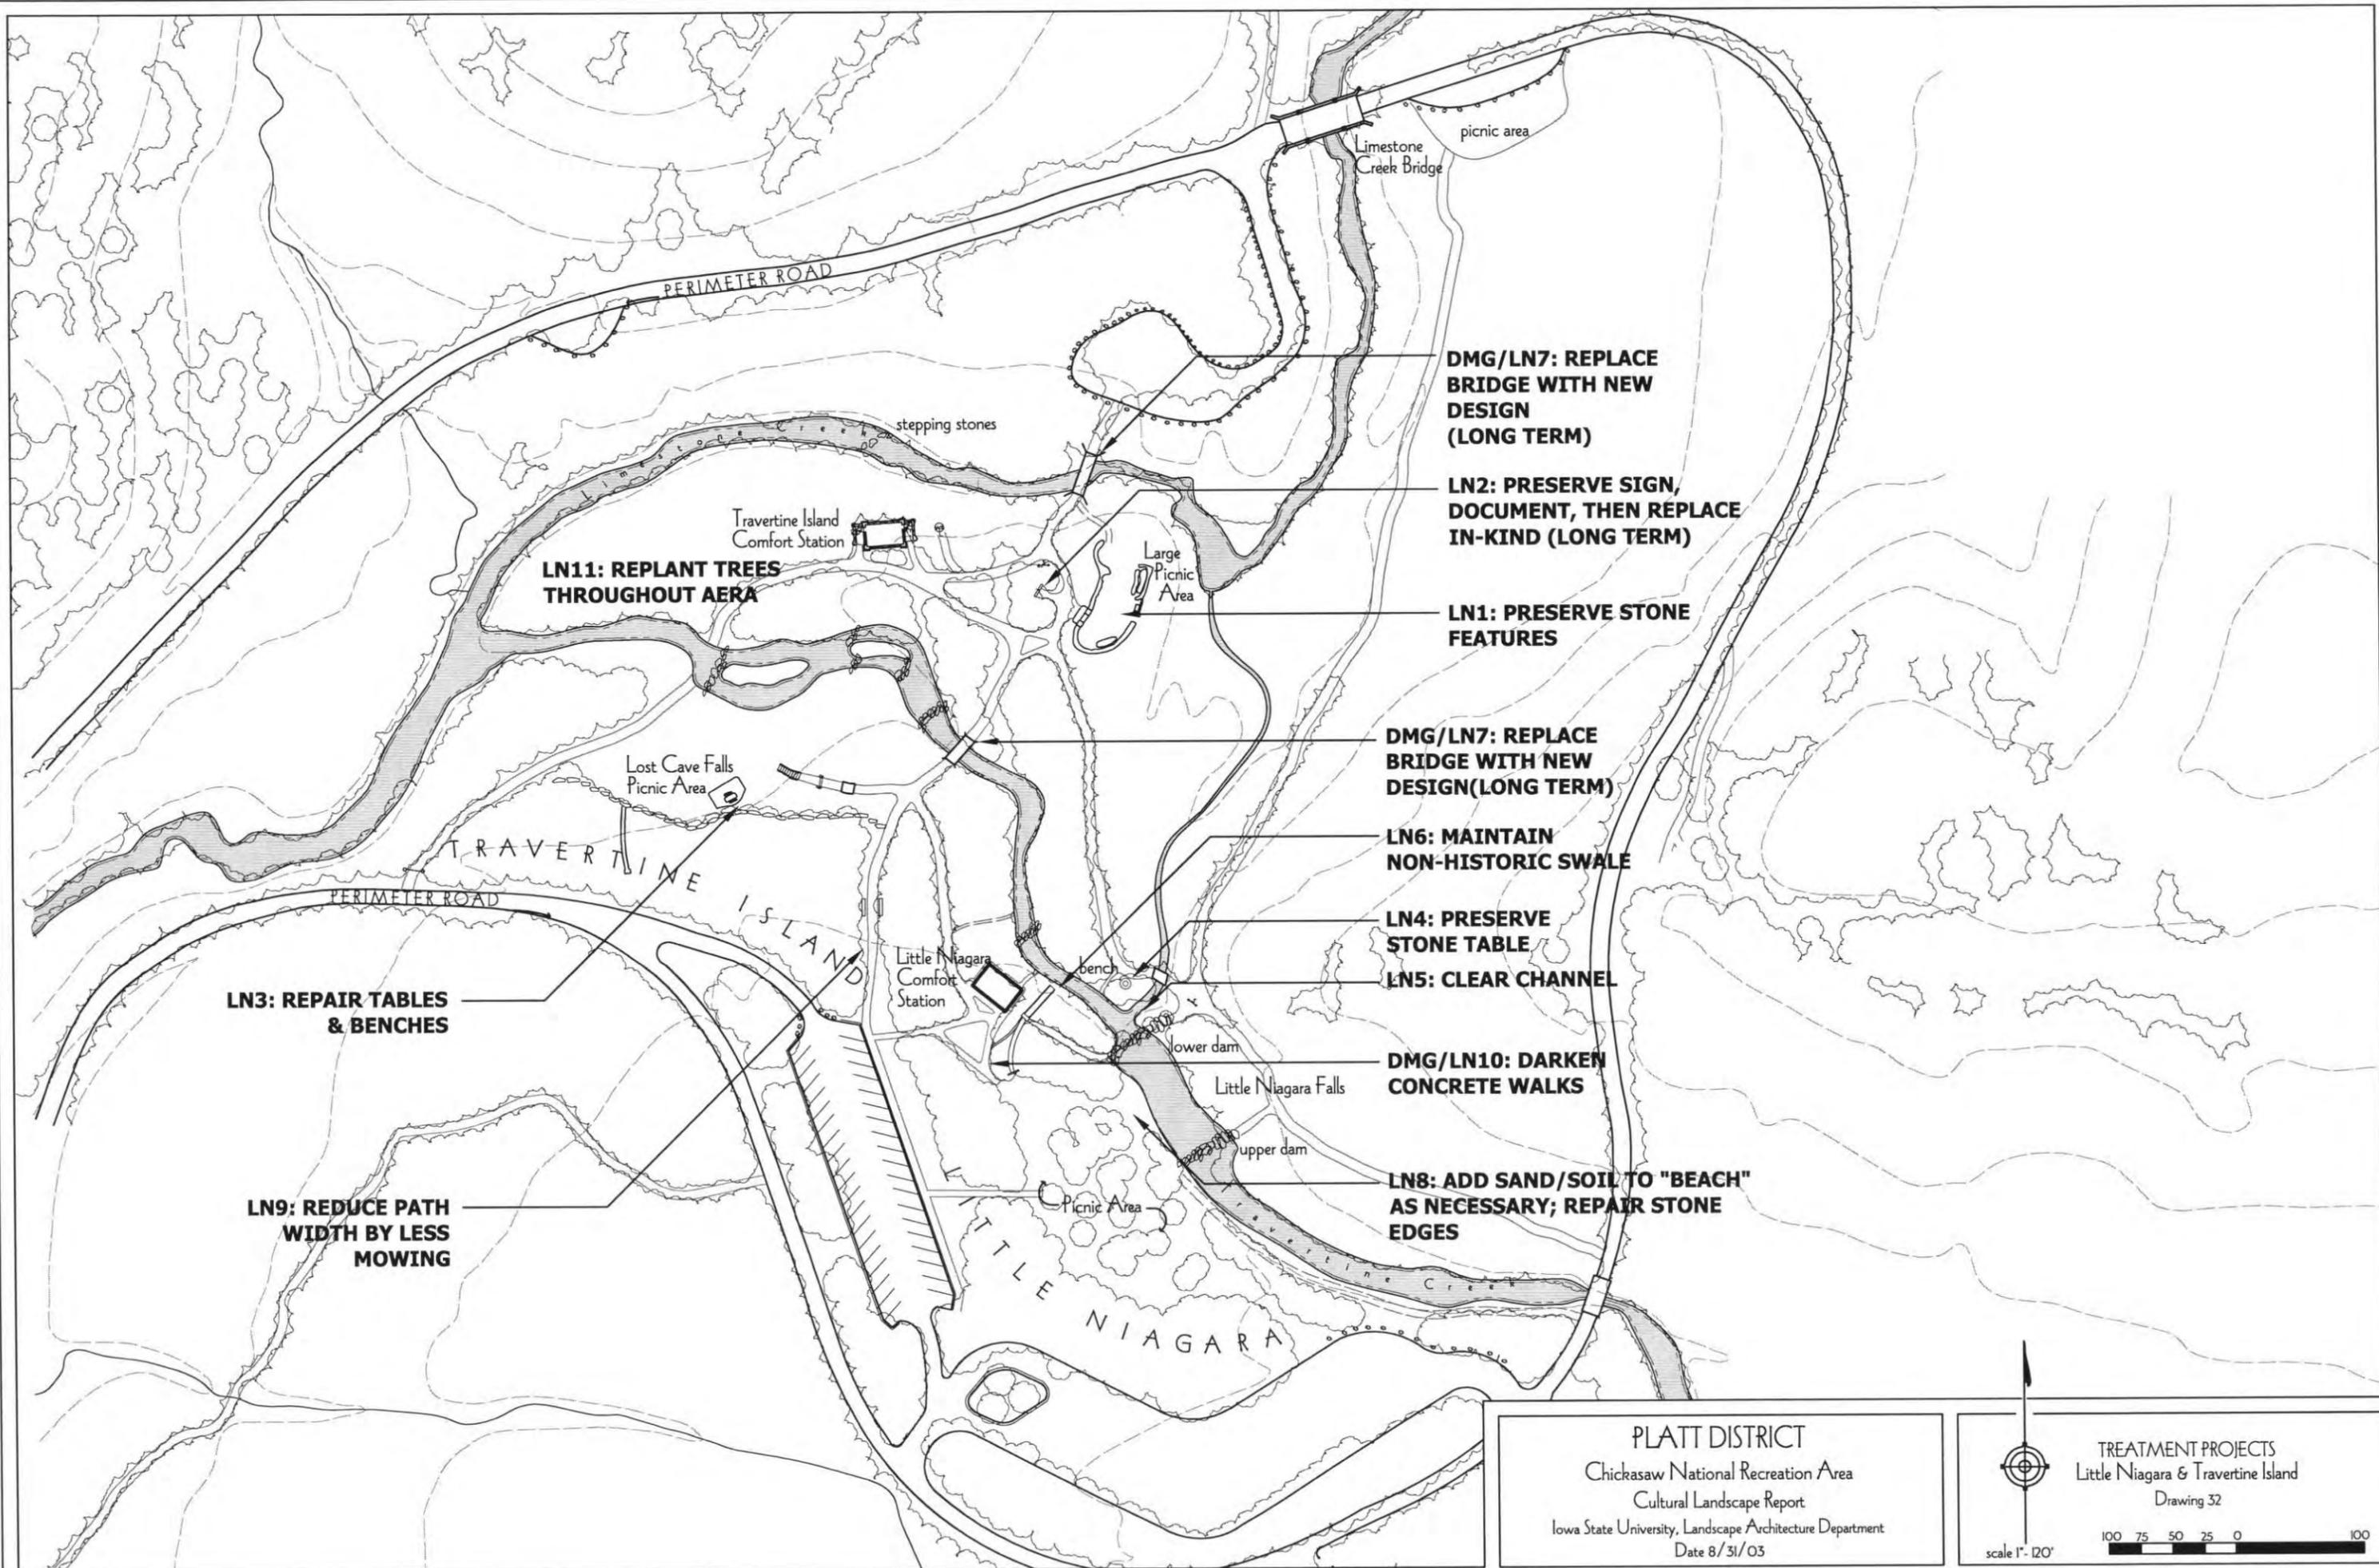

**LN11: REPLANT TREES
THROUGHOUT AREA**

**DMG/LN7: REPLACE
BRIDGE WITH NEW
DESIGN
(LONG TERM)**

**LN2: PRESERVE SIGN,
DOCUMENT, THEN REPLACE
IN-KIND (LONG TERM)**

**LN1: PRESERVE STONE
FEATURES**

**DMG/LN7: REPLACE
BRIDGE WITH NEW
DESIGN (LONG TERM)**

**LN6: MAINTAIN
NON-HISTORIC SWALE**

**LN4: PRESERVE
STONE TABLE**

LN5: CLEAR CHANNEL

**LN3: REPAIR TABLES
& BENCHES**

**DMG/LN10: DARKEN
CONCRETE WALKS**


**LN9: REDUCE PATH
WIDTH BY LESS
MOWING**

**LN8: ADD SAND/SOIL TO "BEACH"
AS NECESSARY; REPAIR STONE
EDGES**

PLATT DISTRICT
Chickasaw National Recreation Area
Cultural Landscape Report
Iowa State University, Landscape Architecture Department
Date 8/31/03

TREATMENT PROJECTS
Little Niagara & Travertine Island
Drawing 32

scale 1" = 120'

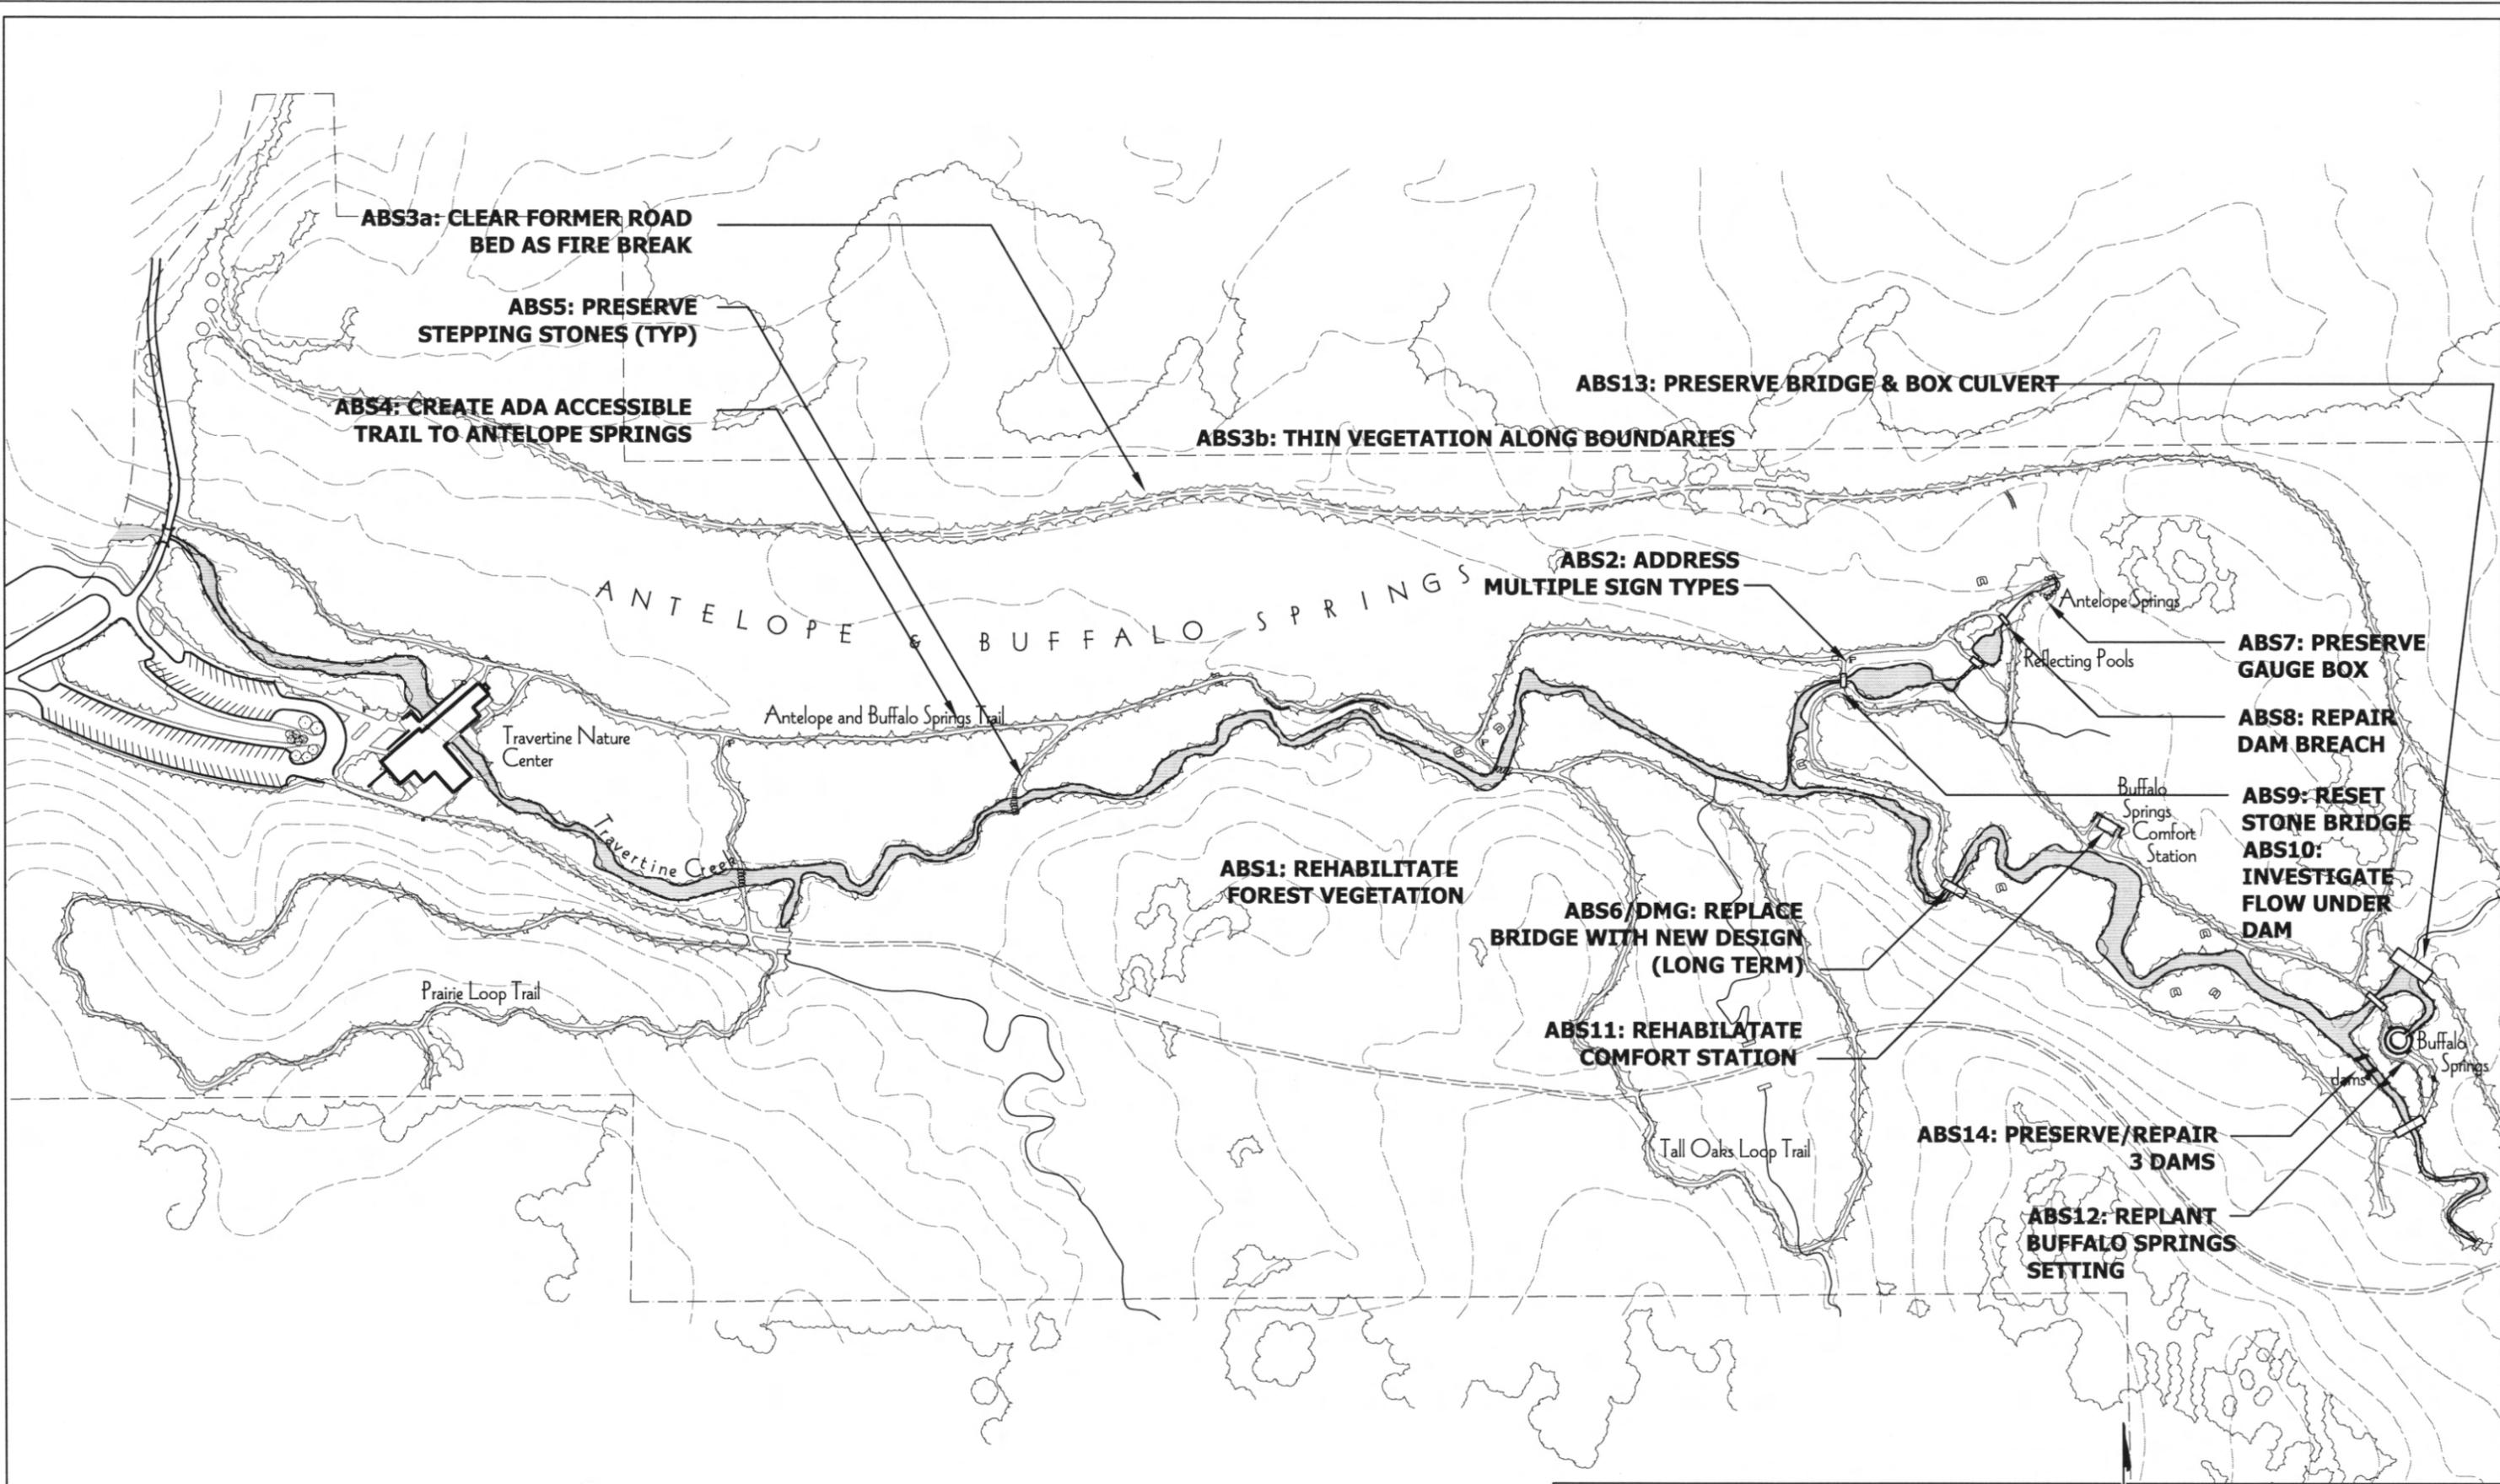

**ABS3a: CLEAR FORMER ROAD
BED AS FIRE BREAK**

**ABS5: PRESERVE
STEPPING STONES (TYP)**

**ABS4: CREATE ADA ACCESSIBLE
TRAIL TO ANTELOPE SPRINGS**

ABS3b: THIN VEGETATION ALONG BOUNDARIES

ABS13: PRESERVE BRIDGE & BOX CULVERT

**ABS2: ADDRESS
MULTIPLE SIGN TYPES**

**ABS7: PRESERVE
GAUGE BOX**

**ABS8: REPAIR
DAM BREACH**

**ABS9: RESET
STONE BRIDGE
ABS10:
INVESTIGATE
FLOW UNDER
DAM**

**ABS1: REHABILITATE
FOREST VEGETATION**

**ABS6/DMG: REPLACE
BRIDGE WITH NEW DESIGN
(LONG TERM)**

**ABS11: REHABILITATE
COMFORT STATION**


**ABS14: PRESERVE/REPAIR
3 DAMS**

**ABS12: REPLANT
BUFFALO SPRINGS
SETTING**

PLATT DISTRICT
Chickasaw National Recreation Area
Cultural Landscape Report
Iowa State University, Landscape Architecture Department
Date 8/31/03

TREATMENT PROJECTS
Antelope Springs & Buffalo Springs
Drawing 33

scale 1" = 250'

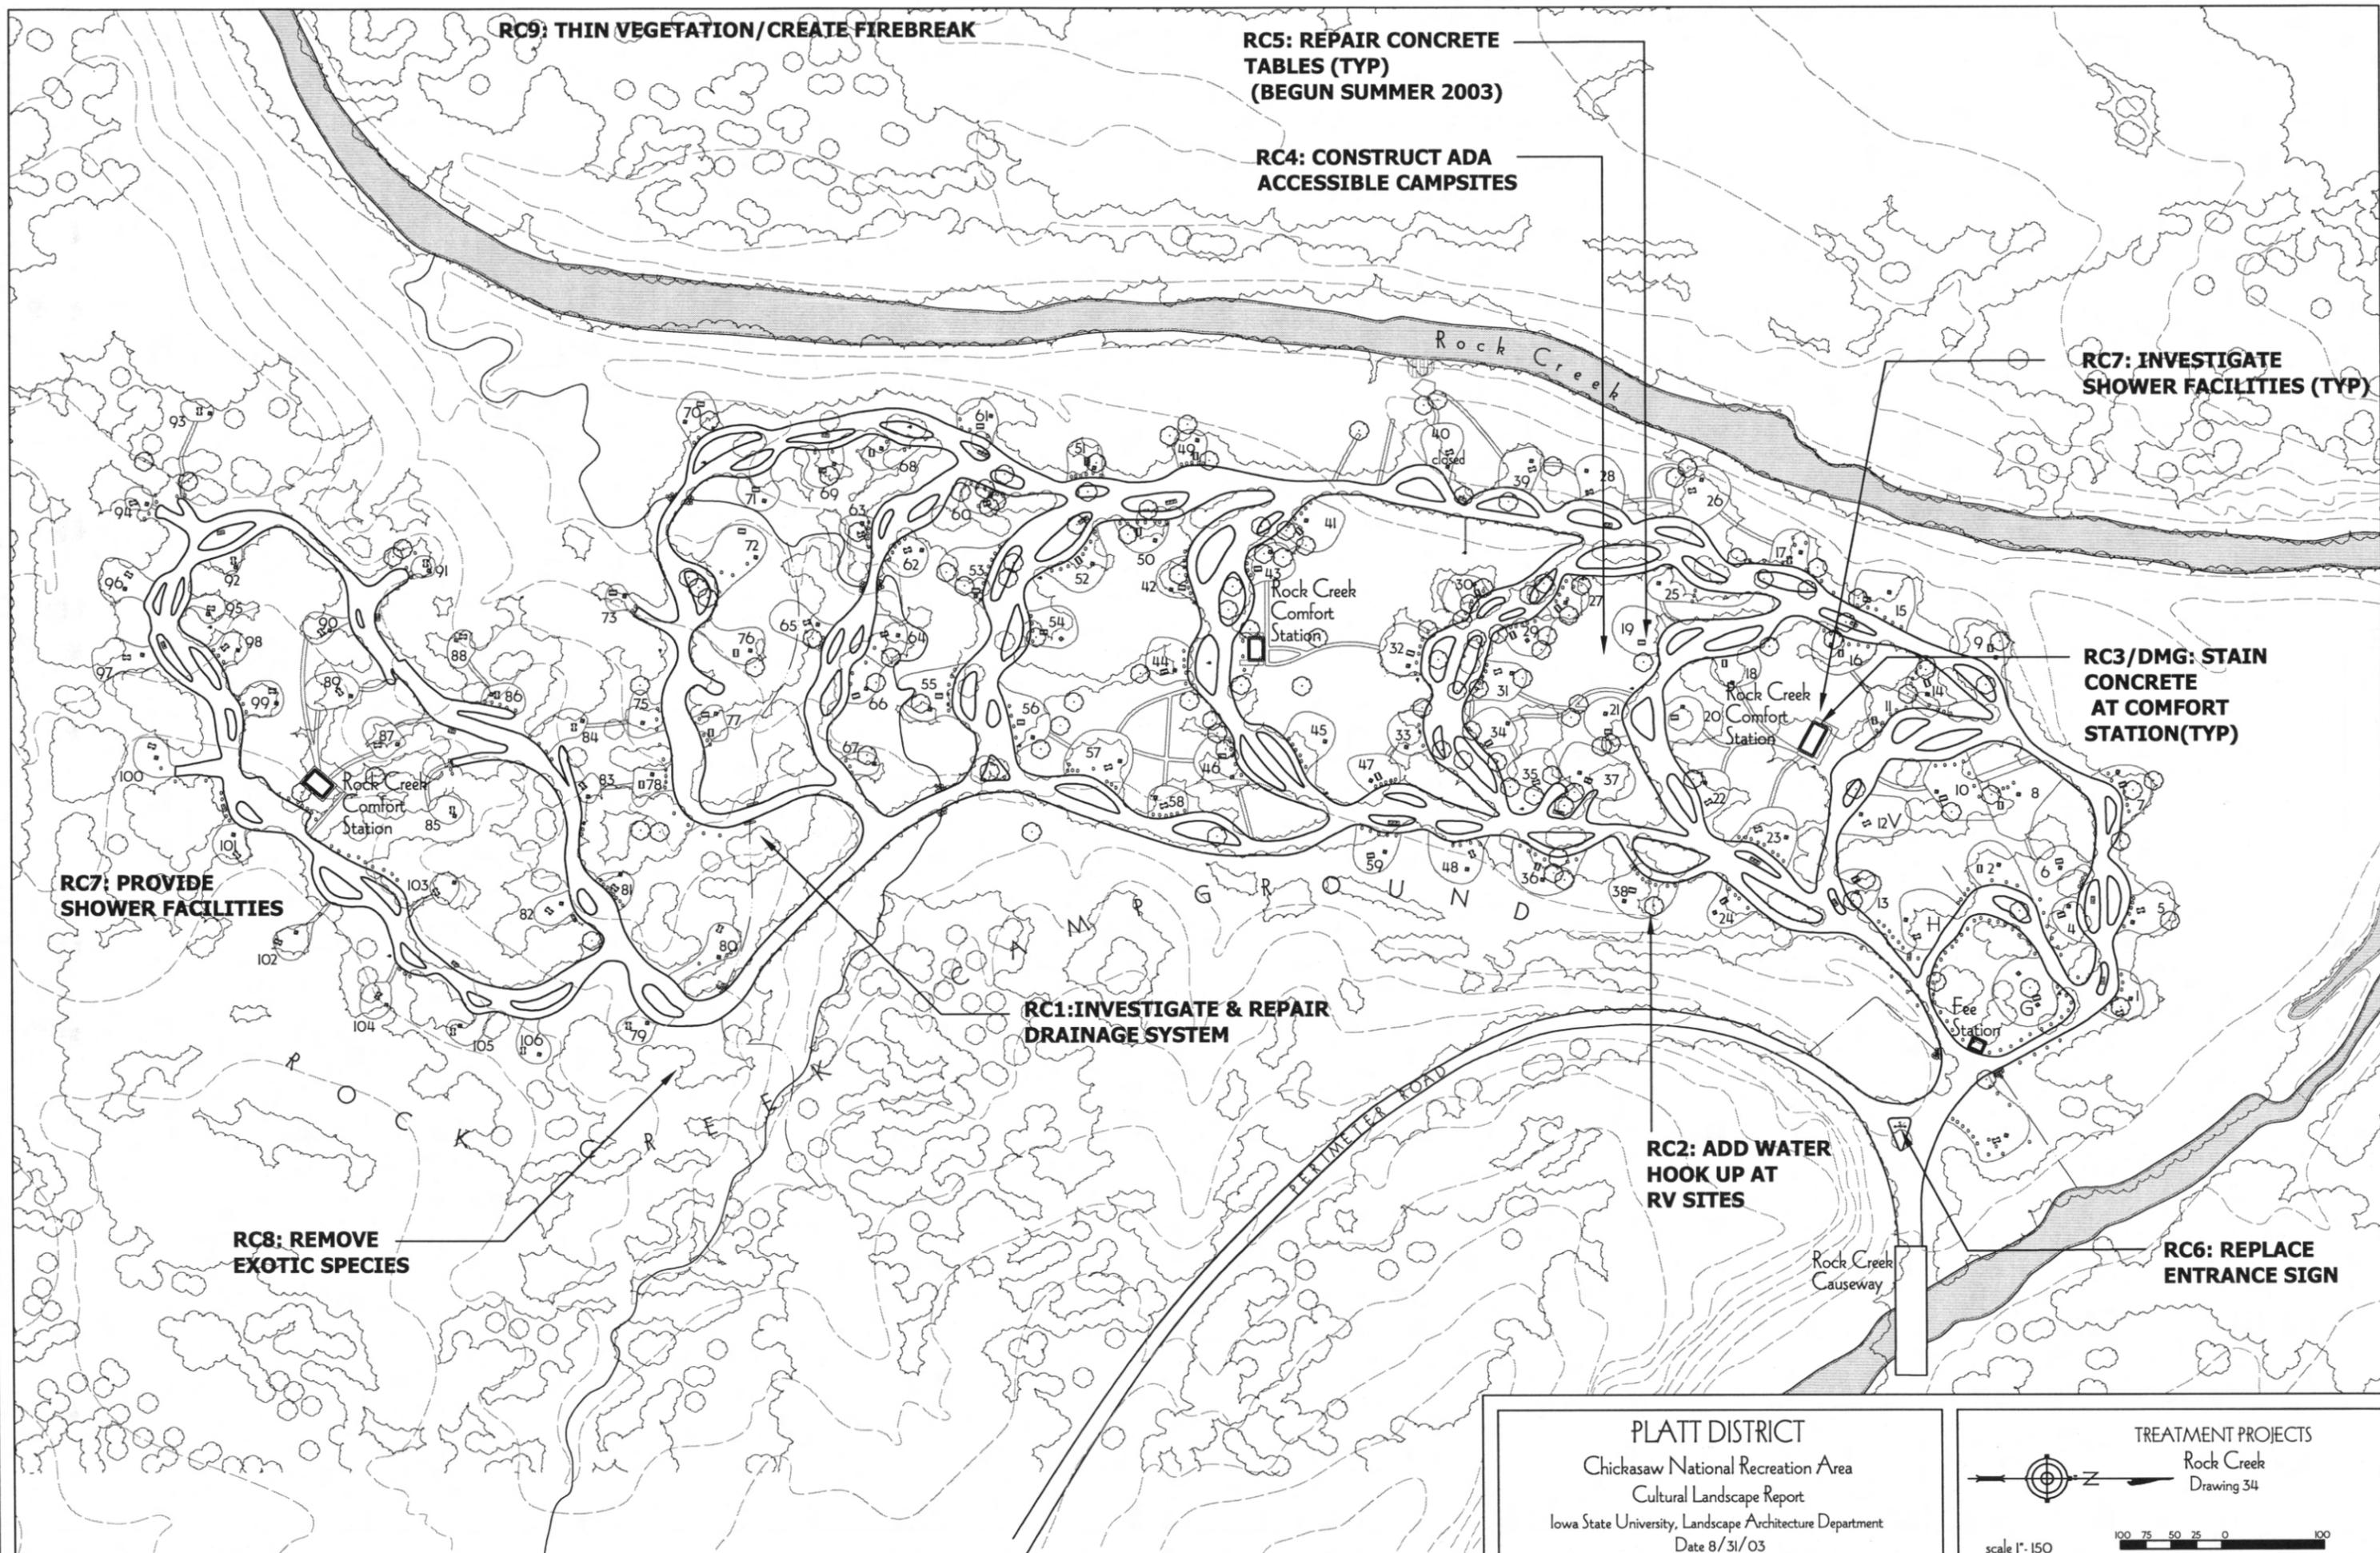

RC9: THIN VEGETATION/CREATE FIREBREAK

RC5: REPAIR CONCRETE TABLES (TYP) (BEGUN SUMMER 2003)

RC4: CONSTRUCT ADA ACCESSIBLE CAMPSITES

RC7: INVESTIGATE SHOWER FACILITIES (TYP)

RC3/DMG: STAIN CONCRETE AT COMFORT STATION(TYP)

RC7: PROVIDE SHOWER FACILITIES


RC1: INVESTIGATE & REPAIR DRAINAGE SYSTEM



RC2: ADD WATER HOOK UP AT RV SITES

RC8: REMOVE EXOTIC SPECIES


RC6: REPLACE ENTRANCE SIGN

 PLATT DISTRICT
 Chickasaw National Recreation Area
 Cultural Landscape Report
 Iowa State University, Landscape Architecture Department
 Date 8/31/03

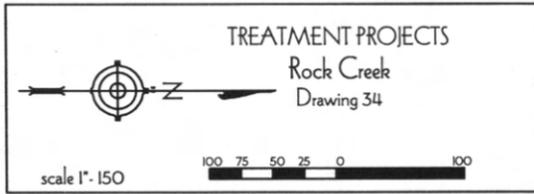

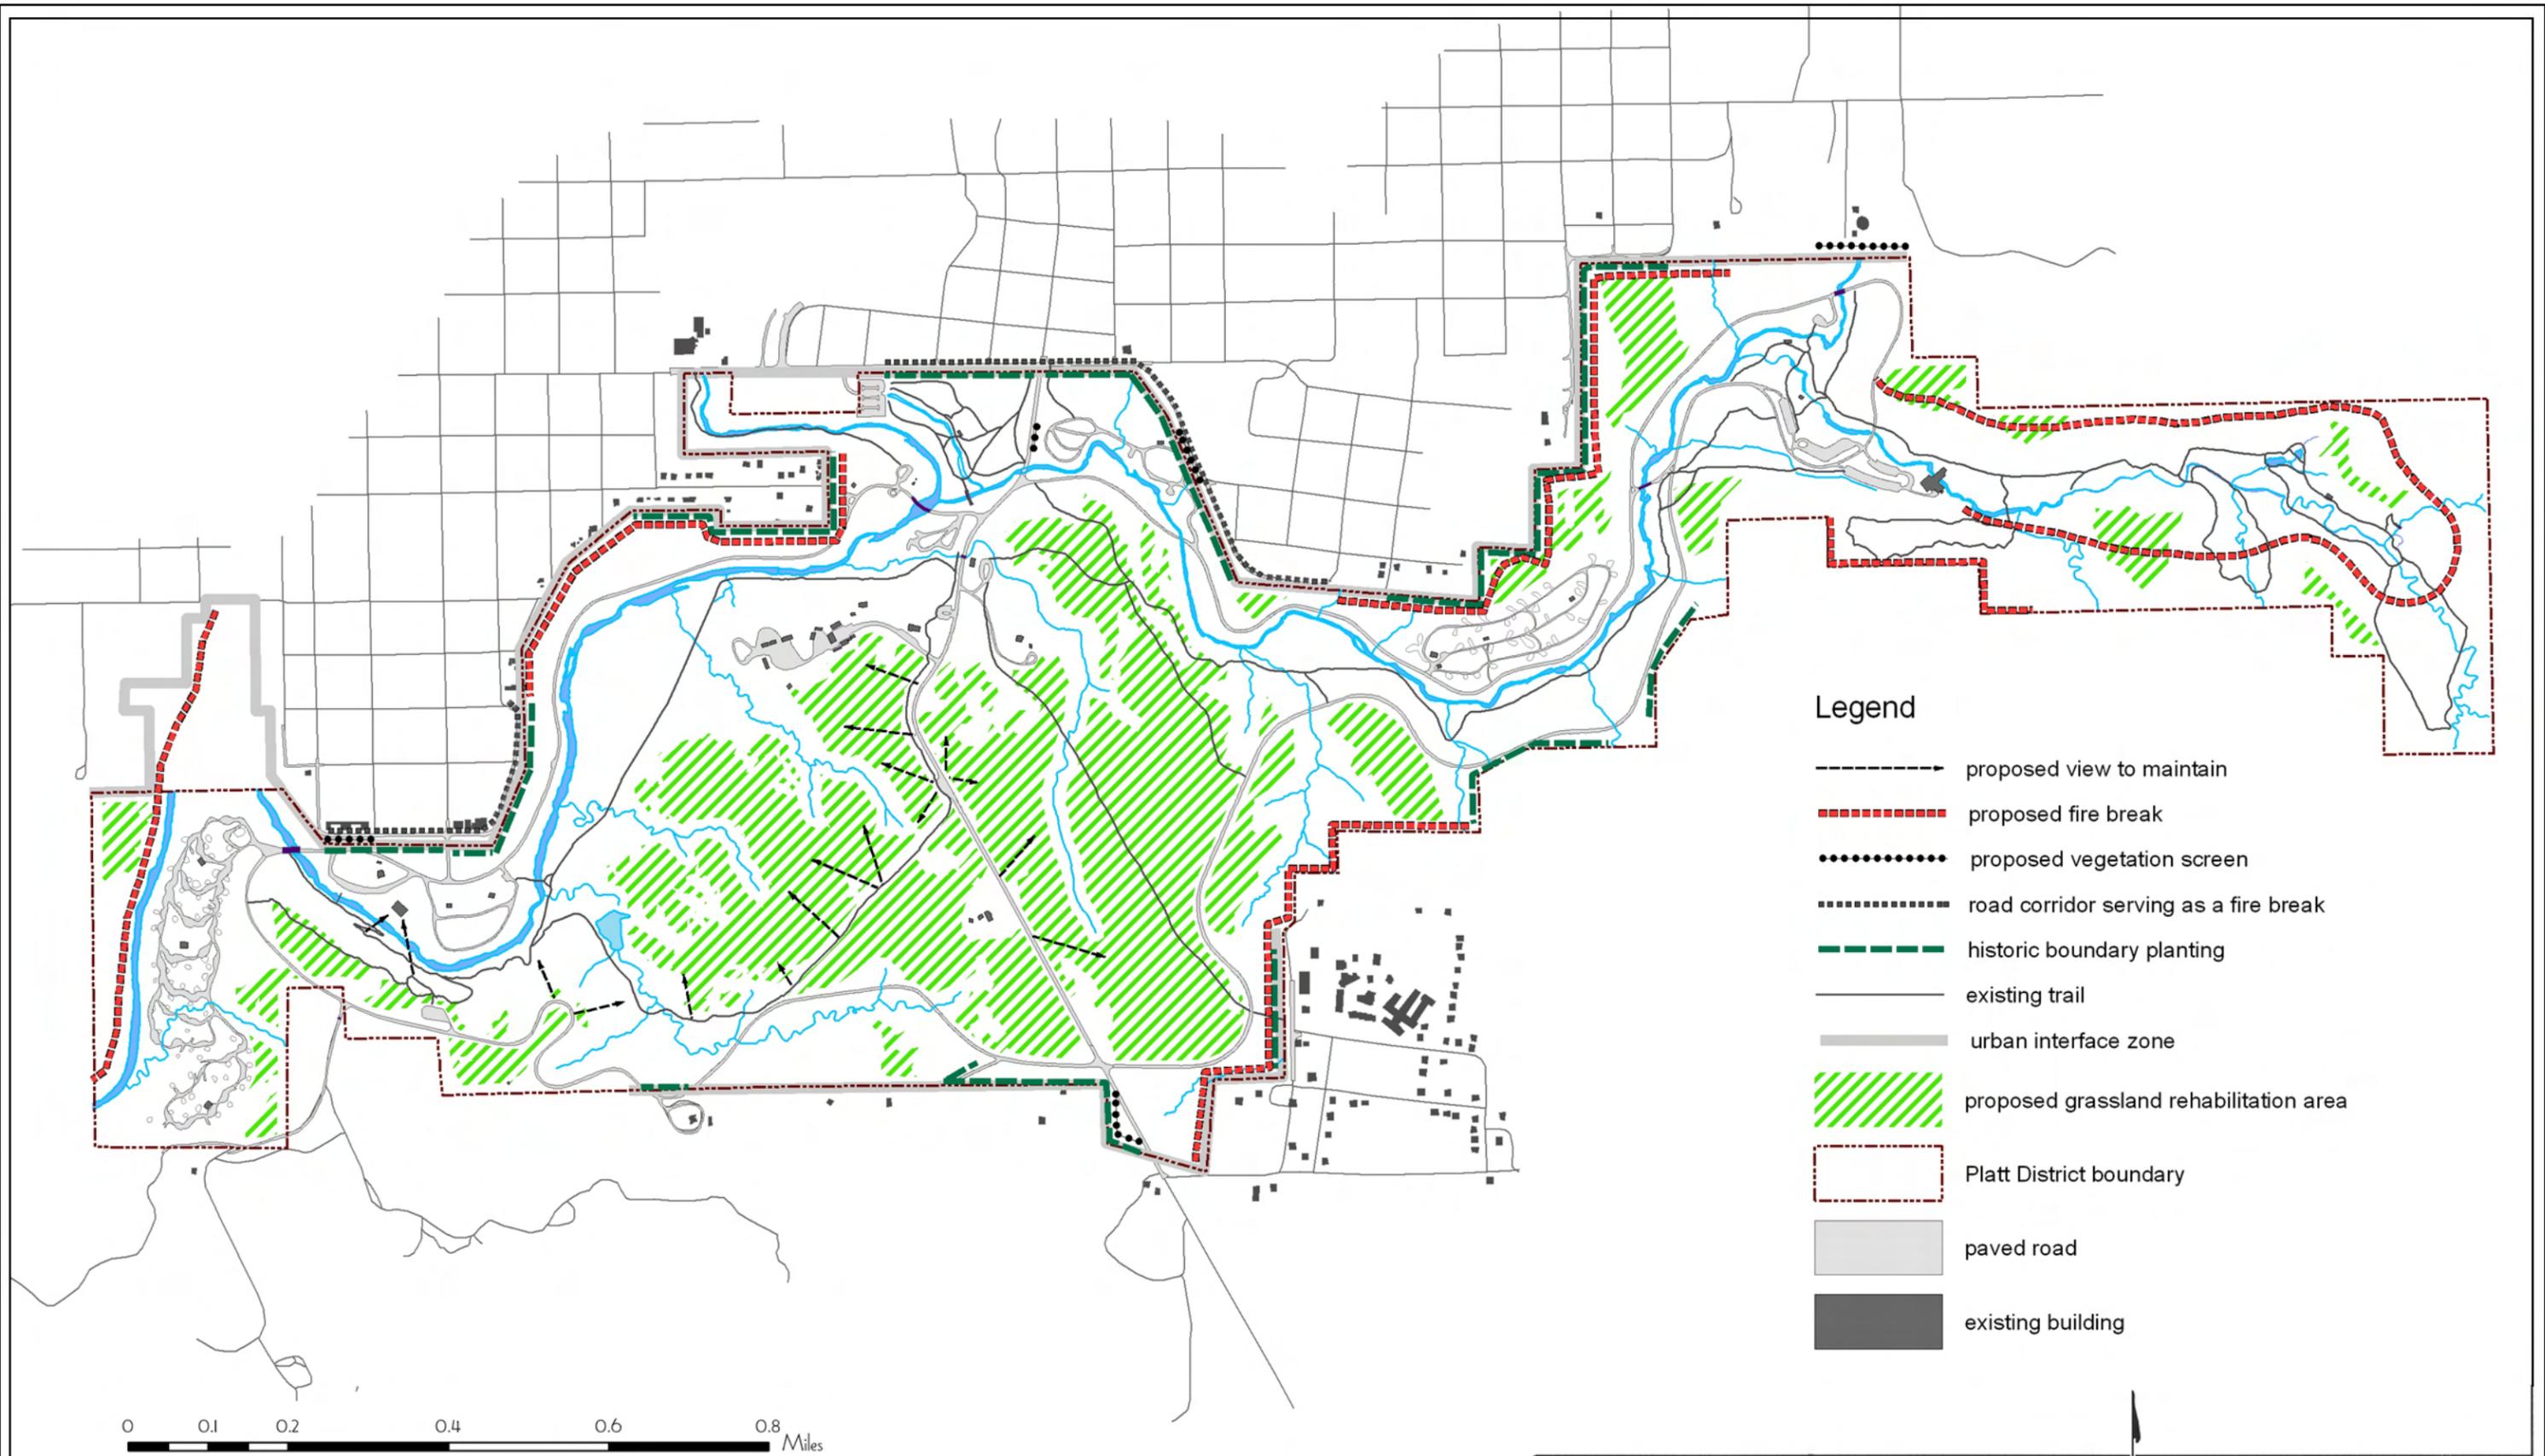

PLATT DISTRICT
 Chickasaw National Recreation Area
 Cultural Landscape Report
 Iowa State University, Landscape Architecture Department
 Date 08/31/03

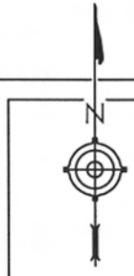

Proposed Overall
 Vegetation Management Plan
 Drawing 35